

OLD MEMORIAL

SITE ADDRESS	13600 Hixon Rd, Tampa, FL 33626														
SITE LOCATION MAP															
OWNER	HILLSBOROUGH GOLF DEV INC														
CONTRACTOR	TBD														
ARCHITECT	LAFATE WILSON 1030 ARLINGTON AVE N, ST PETERSBURG FL 33705														
MEP ENGINEER	Joseph Lawrence & Co 317 Riveredge Blvd, Suite 110 Cocoa, Florida 32922														
SCOPE NARRATIVE	BUILDING 2 IS BEING DEMOLISHED AND REPLACED. THIS BUILDING INCLUDES STORAGE, FUELING AND CART WASH. NEW ELECTRICAL AND PLUMBING WILL BE PROVIDED TO ACCOMMODATE THE NEW BUILDING LAYOUT. THERE IS NO HVAC SCOPE IN THIS BUILDING.														
SITE DATA	<table><tr><td>PARCEL ID</td><td>U-03-28-17-ZZZ-000000-26610.0</td></tr><tr><td>LEGAL DESCRIPTION</td><td>SW 1/4 OF NE 1/4 AND S 1/2 OF NW 1/4, NW 1/4 OF NW 1/4, W 1/2 OF SW 1/4 & NE 1/4 OF SW 1/4 & W 1/2 OF NW 1/4 OF SE 1/4</td></tr><tr><td>LOT SIZE</td><td>315 ACRES</td></tr><tr><td>FLOOD ZONE</td><td>X</td></tr><tr><td>PERMITTING JURISDICTION</td><td>HILLSBOROUGH COUNTY</td></tr><tr><td>ZONING DISTRICT</td><td>AS-1 AGRICULTURAL, SINGLE-FAMILY</td></tr><tr><td>BUILDING CODE EDITIONS</td><td>8TH EDITION 2023 FBC - BUILDING 8TH EDITION 2023 FBC - ENERGY 8TH EDITION 2023 FBC - TEST PROTOCOL 8TH EDITION 2023 FBC - PLUMBING 8TH EDITION 2023 FBC - MECHANICAL 8TH EDITION 2023 FBC - FUEL GAS 8TH EDITION 2023 FBC - ACCESSIBILITY 8TH EDITION 2023 FLORIDA FIRE PREVENTION CODE NEC 2020 NATIONAL ELECTRICAL CODE - NFPA 70</td></tr></table>	PARCEL ID	U-03-28-17-ZZZ-000000-26610.0	LEGAL DESCRIPTION	SW 1/4 OF NE 1/4 AND S 1/2 OF NW 1/4, NW 1/4 OF NW 1/4, W 1/2 OF SW 1/4 & NE 1/4 OF SW 1/4 & W 1/2 OF NW 1/4 OF SE 1/4	LOT SIZE	315 ACRES	FLOOD ZONE	X	PERMITTING JURISDICTION	HILLSBOROUGH COUNTY	ZONING DISTRICT	AS-1 AGRICULTURAL, SINGLE-FAMILY	BUILDING CODE EDITIONS	8TH EDITION 2023 FBC - BUILDING 8TH EDITION 2023 FBC - ENERGY 8TH EDITION 2023 FBC - TEST PROTOCOL 8TH EDITION 2023 FBC - PLUMBING 8TH EDITION 2023 FBC - MECHANICAL 8TH EDITION 2023 FBC - FUEL GAS 8TH EDITION 2023 FBC - ACCESSIBILITY 8TH EDITION 2023 FLORIDA FIRE PREVENTION CODE NEC 2020 NATIONAL ELECTRICAL CODE - NFPA 70
PARCEL ID	U-03-28-17-ZZZ-000000-26610.0														
LEGAL DESCRIPTION	SW 1/4 OF NE 1/4 AND S 1/2 OF NW 1/4, NW 1/4 OF NW 1/4, W 1/2 OF SW 1/4 & NE 1/4 OF SW 1/4 & W 1/2 OF NW 1/4 OF SE 1/4														
LOT SIZE	315 ACRES														
FLOOD ZONE	X														
PERMITTING JURISDICTION	HILLSBOROUGH COUNTY														
ZONING DISTRICT	AS-1 AGRICULTURAL, SINGLE-FAMILY														
BUILDING CODE EDITIONS	8TH EDITION 2023 FBC - BUILDING 8TH EDITION 2023 FBC - ENERGY 8TH EDITION 2023 FBC - TEST PROTOCOL 8TH EDITION 2023 FBC - PLUMBING 8TH EDITION 2023 FBC - MECHANICAL 8TH EDITION 2023 FBC - FUEL GAS 8TH EDITION 2023 FBC - ACCESSIBILITY 8TH EDITION 2023 FLORIDA FIRE PREVENTION CODE NEC 2020 NATIONAL ELECTRICAL CODE - NFPA 70														

BUILDING 2	
GROUND FLOOR (UNDER ROOF)	3,555 SF
TOTAL BUILDING AREA	3,555 SF
1 STORIES PROVIDED	
BUILDING HEIGHT = 20'-10" TO TOP OF ROOF	

BUILDING CODE DATA															
OCCUPANCY	S-1 (BUSINESS ACCESSORY USE)														
CONSTRUCTION TYPE	2B UNSPRINKLERED														
ALLOWABLE BUILDING HEIGHT	55'														
ALLOWABLE STORIES	2 STORIES														
ALLOWABLE BUILDING AREA	17,500 SF														
FIRE RESISTANCE RATING	<table><tr><th></th><th>WALLS & PARTITIONS</th></tr><tr><td>PRIMARY STRUCTURAL FRAME</td><td>0 HR</td></tr><tr><td>EXTERIOR BEARING WALLS</td><td>0 HR</td></tr><tr><td>INTERIOR BEARING WALLS</td><td>0 HR</td></tr><tr><td>INTERIOR NON-BEARING WALLS</td><td>0 HR</td></tr><tr><td>FLOOR / CEILING CONSTRUCTION</td><td>0 HR</td></tr><tr><td>ROOF CONSTRUCTION</td><td>0 HR</td></tr></table>		WALLS & PARTITIONS	PRIMARY STRUCTURAL FRAME	0 HR	EXTERIOR BEARING WALLS	0 HR	INTERIOR BEARING WALLS	0 HR	INTERIOR NON-BEARING WALLS	0 HR	FLOOR / CEILING CONSTRUCTION	0 HR	ROOF CONSTRUCTION	0 HR
	WALLS & PARTITIONS														
PRIMARY STRUCTURAL FRAME	0 HR														
EXTERIOR BEARING WALLS	0 HR														
INTERIOR BEARING WALLS	0 HR														
INTERIOR NON-BEARING WALLS	0 HR														
FLOOR / CEILING CONSTRUCTION	0 HR														
ROOF CONSTRUCTION	0 HR														
SPRINKLER SYSTEM	NOT REQUIRED														
FIRE EXTINGUISHERS	TYPE 2-A 10-B-C, 75' MAX TRAVEL DISTANCE TO EXTINGUISHER														
INTERIOR WALL & CEILING FINISHES CLASSIFICATION	ROOMS AND ENCLOSED SPACES - CLASS C CORRIDORS AND ENCLOSURE FOR EXIT - CLASS B														
EXIT ACCESS TRAVEL DISTANCE	200 FEET														
MAX COMMON PATH OF TAVEL	100 FEET FOR OCC LOAD LESS THAN OR EQUAL TO 30 PEOPLE 75 FEET FOR OCC LOAD GREATER THAN 30 PEOPLE														
FIRE ALARM SYSTEM	NOT REQUIRED														

 
 
 
 
 
FLORIDA PRODUCT APPROVAL

SECTIONAL DOOR		
OVERHEAD DOOR CORPORATION	EXTERIOR DOOR	FL11734-R10
SINGLE AND DOUBLE SWING DOOR		
NET DOOR COMPANY	EXTERIOR DOOR	FL12648-R7

GENERAL NOTES

- EXISTING ITEMS AND CONDITIONS ARE DEPICTED AND DESCRIBED ON THESE DRAWINGS ACCORDING TO THE BEST AVAILABLE INFORMATION AND SURVEYS. THE ARCHITECT PROVIDES NO ASSURANCE AS TO, AND ASSUMES NO RESPONSIBILITY FOR THE ACCURACY OF THESE DEPICTIONS AND DESCRIPTIONS. FIELD VERIFY AND DETERMINE, BY ANY MEANS NECESSARY, THE ACTUAL LOCATION, CONFIGURATION AND CONDITION OF ALL PERTINENT ITEMS, INCLUDING THOSE THAT MAY BE IN CONCEALED LOCATIONS. IF INVESTIGATION DISCOVERS THAT ACTUAL CONDITIONS DIFFER FROM WHAT IS DEPICTED OR DESCRIBED ON THESE DRAWINGS OR IF THE ITEMS AND CONDITIONS THAT ARE TO REMAIN AS PART OF THE FINISHED WORK ARE UNSUITABLE TO SUPPORT OR ACCOMMODATE THE WORK REQUIRED FOR THIS PROJECT, OR DO NOT COMPLY WITH BUILDING CODE REQUIREMENTS OR MEET CONSTRUCTION INDUSTRY STANDARDS, IMMEDIATELY NOTIFY THE ARCHITECT BY RFI AND DO NOT PROCEED WITH THE WORK UNTIL RECEIPT OF SUPPLEMENTAL INSTRUCTIONS FROM THE ARCHITECT.
- DO NOT SCALE DRAWINGS. THE DIMENSIONS ON THE DRAWINGS GOVERN. WRITTEN NOTES REFERRING AN ITEM WITH THE WORD "TYPICAL" (TYP) APPLY TO ALL IDENTICAL ITEMS OR FEATURES INDICATED ELSEWHERE ON THE DRAWINGS.
- ESTABLISH AREAS AND LIMITS OF CONSTRUCTION ACTIVITY ACCEPTABLE TO THE OWNER AND PROVIDE THE TEMPORARY FACILITIES REQUIRED TO ACCOMPLISH THE WORK INCLUDING: FIELD OFFICE, TOILETS, ELECTRIC SERVICE, SITE ACCESS, PARKING, STORAGE AND CONSTRUCTION STAGING AREAS. PROVIDE TEMPORARY WALKWAYS, DRIVEWAYS, BARRIERS, SIGNS AND ILLUMINATION TO SEPARATE AND PROTECT THE GENERAL PUBLIC FROM THE WORK RELATED ACTIVITIES. PROVIDE ACCESS ROUTES TO AND FROM AREAS OF CONSTRUCTION ACTIVITY FOR CONSTRUCTION PERSONNEL THAT COMPLY WITH ALL OSHA AND OTHER GOVERNMENT SAFETY AND ACCESSIBILITY REQUIREMENTS. ASSUME FULL LIABILITY FOR ANY DAMAGE TO ADJACENT PROPERTIES, DAMAGE TO PERSONAL PROPERTY, INJURY TO PERSONS, ETC., CAUSED BY WORK RELATED ACTIVITIES OR NEGLIGENCE.
- PROVIDE TEMPORARY SHORING AS REQUIRED TO ADEQUATELY SUPPORT AND RETAIN EXISTING MATERIALS AND CONSTRUCTION AFFECTED BY THE WORK. PROTECT THOSE ITEMS, MATERIALS & FINISHES TO REMAIN. REMOVE ONLY THOSE ITEMS AND MATERIALS NECESSARY TO ACCOMMODATE THE WORK WITH CLEAN, UNIFORM CUTS. FILL AND PATCH REMAINING CONSTRUCTION AS REQUIRED WITH MATERIALS MATCHING THE ADJACENT MATERIALS IN KIND, STRENGTH, AND APPEARANCE SO AS TO FINISH UNIFORMLY WITHOUT TELEGRAPHING DIFFERENCES BETWEEN THE PATCHES AND THE ADJACENT CONSTRUCTION. REPAIR OR REPLACE ANY ITEMS, MATERIALS OR FINISHES DAMAGED BY THE WORK AT NO COST TO THE OWNER.
- PROVIDE THE ITEMS, PRODUCTS AND FEATURES AS DEPICTED, DESCRIBED AND SPECIFIED ON THE DRAWINGS. IF DISCREPANCIES ARE DISCOVERED ON THE DRAWINGS, NOTIFY THE ARCHITECT BY RFI AND DO NOT PROCEED WITH WORK RELATED TO ITEMS IN QUESTION UNTIL RECEIPT OF SUPPLEMENTAL INSTRUCTIONS FROM THE ARCHITECT. REQUESTS FOR SUBSTITUTIONS MAY BE SUBMITTED TO THE ARCHITECT FOR CONSIDERATION. DO NOT MAKE SUBSTITUTIONS WITHOUT THE APPROVAL OF THE ARCHITECT. WHERE A "BASIS-OF-DESIGN" PRODUCT IS SPECIFIED, A COMPARABLE PRODUCT MAY BE PROVIDED, SUBJECT TO COMPLIANCE WITH THE REQUIREMENTS OF THE CONTRACT DOCUMENTS.
- SUBMIT SHOP DRAWINGS, PRODUCT DATA AND SAMPLES TO THE ARCHITECT FOR REVIEW AS REQUIRED BY THE CONTRACT DOCUMENTS. DO NOT PROCEED WITH WORK RELATED TO SUBMITTALS MARKED "REJECTED" OR "REVISE AND RESUBMIT" BY THE ARCHITECT OR THE ARCHITECT'S CONSULTANTS. SUBMITTALS MARKED "APPROVED," "NO EXCEPTION TAKEN" OR "MAKE CORRECTIONS NOTED" DO NOT SUPERSEDE THE NEED TO COMPLY WITH THE REQUIREMENTS OF THE CONTRACT DOCUMENTS. SHOP DRAWINGS/SUBMITTALS ARE REQUIRED FOR BUT NOT LIMITED TO THE FOLLOWING: MILLWORK, STRUCTURAL/MISCELLANEOUS STEEL, HARDWARE, WOOD AND METAL DOORS, AND EQUIPMENT. SHOP DRAWINGS SHOULD INCLUDE DETAILED FABRICATION AND ERECTION DRAWINGS, SETTING DRAWINGS, AND MATERIAL SCHEDULES. FABRICATION SHALL BEGIN ONLY AFTER ARCHITECT'S REVIEW AND APPROVAL OF SHOP DRAWINGS.
- PROVIDE A FLORIDA PRODUCT APPROVAL ISSUED BY THE FLORIDA DEPARTMENT OF BUSINESS & PROFESSIONAL REGULATION OR A MIAMI-DADE NOTICE OF ACCEPTANCE (NOA) ISSUED BY THE MIAMI-DADE COUNTY GOVERNMENT FOR EACH EXTERIOR COMPONENT AND CLADDING ASSEMBLY CERTIFYING THAT APPROVED TESTING HAS SUFFICIENTLY DEMONSTRATED THAT THE ASSEMBLY AND ITS COMPONENTS, AS DESIGNED AND MANUFACTURED, WILL WITHSTAND THE WIND LOADS AND WIND-BORNE MISSILE IMPACTS IN COMPLIANCE WITH ALL CODE AND JURISDICTIONAL REQUIREMENTS FOR THE PROJECT LOCATION WHEN INSTALLED ACCORDING TO THE MANUFACTURER'S INSTRUCTIONS INCLUDING INSTRUCTIONS THAT MAY BE PROVIDED WITH THE FLORIDA PRODUCT APPROVAL OR NOA DOCUMENTS. PROVIDE THESE DOCUMENTS AS PART OF THE SUBMITTAL FOR EACH OF THESE ITEMS AND ASSEMBLIES FOR BCA APPROVAL.
- PROVIDE ALL ITEMS AND FEATURES DEPICTED AND DESCRIBED ON THESE DRAWINGS AND OTHER CONTRACT DOCUMENTS SO THEY ARE PROPERLY PLACED, ALIGNED, PLUMB, SECURED, FINISHED AND FUNCTIONING AS INTENDED. PROVIDE FINISHED WORK THAT MEETS OR EXCEEDS CURRENT INDUSTRY STANDARDS FOR QUALITY AND PERFORMANCE. ARRANGE AND CONDUCT INSPECTIONS OF THE FINISHED WORK WITH THE OWNER, THE ARCHITECT, AND THE AUTHORITY HAVING JURISDICTION. APPROVAL OF THE WORK BY THESE OR ANY OTHER PARTY OR AGENCY DOES NOT SUPERSEDE THE NEED TO COMPLY WITH THE REQUIREMENTS OF THE CONTRACT DOCUMENTS.
- REMOVE CONSTRUCTION DEBRIS, INCLUDING DEMOLISHED MATERIALS, FROM THE SITE AS REQUIRED TO PREVENT ACCUMULATION. TRANSPORT THESE MATERIALS OFF THE SITE IN A MANNER THAT WILL PREVENT SPILLAGE AND LEGALLY DISPOSE OF THESE MATERIALS AT AN EPA APPROVED DISPOSAL OR RECYCLING FACILITY.
- KEEP COMPLETE AND LEGIBLE SETS OF CONSTRUCTION DOCUMENTS, ADDENDA, SUPPLEMENTAL INSTRUCTIONS, SUPPLEMENTAL DRAWINGS, MEETING NOTES, ETC. TOGETHER AND READILY AVAILABLE IN AN APPROPRIATE LOCATION ON SITE.
- CONCEAL CONDUIT, PIPING, ETC. WITHOUT EXCEPTION. PROVIDE ACCESSIBLE JUNCTION BOXES, VALVES, CLEANOUTS, ETC., AS REQUIRED BY CODE.
- WHERE POSSIBLE AND BEST PRACTICE, ALIGN THE SEAMS AND EDGES OF BREAK METAL AND FLASHING WITH ADJACENT REVEALS, EDGES OF MATERIAL TRANSITIONS, OR WITH BUILDING DESIGN FEATURES. CONSULT WITH ARCHITECT AS REQUIRED.
- PER OWNER - CONTRACTOR AGREEMENT, PROJECT TO FOLLOW ALL OSHA STANDARDS AND REQUIREMENTS. INCLUDE OCCUPATIONAL SAFETY AND HEALTH ADMINISTRATION (OSHA) EXCAVATION SAFETY STANDARD 29 C.F.R., SECTION 1926.630 SUBPART F, WHICH ARE INCORPORATED AS THE STATE STANDARD.

TAG LEGENED

	REVISION MARKER		SECTION MARK
	REVISION CLOUD		EXTERIOR ELEVATION
	NORTH ARROW		INTERIOR ELEVATION
	VIEW CALLOUT		

ABBREVIATIONS

A/C	AIR CONDITIONING	MAX	MAXIMUM
AD	AREA DRAIN	MECH	MECHANICAL
ADA	AMERICANS WITH DISABILITIES ACT	MEP	MECHANICAL, ELECTRICAL, PLUMBING
ADD	ADDITIONAL	MFR	MANUFACTURER
ADJ	ADJUSTABLE	MISC	MISCELLANEOUS
AFF	ABOVE FINISH FLOOR	MTD	MOUNTED
ALT	ALTERNATE	MTL	METAL
AL	ALUMINUM	MULL	MULLION
ARCH	ARCHITECTURAL	N/A	NOT APPLICABLE
A/V	AUDIO VISUAL	NC	NOISE CRITERIA
BLDG	BUILDING	NIC	NOT IN CONTRACT
CMF	COLD FORM METAL FRAMING	NOM	NOMINAL
CJ	CONTROL JOINT / CONSTRUCTION JOINT	NRC	NOISE REDUCTION COEFFICIENT
CL	CENTER LINE	NTS	NOT TO SCALE
CLG	CEILING	OC	ON CENTER
CLR	CLEAR	OH	OVER HEAD
CMU	CONCRETE MASONRY UNIT	PLAM	PLASTIC LAMINATE
CO	CLEANOUT	PLBG	PLUMBING
COL	COLUMN	PREFAB	PREFABRICATED
CONC	CONCRETE	PT	PRESSURE TREATED
CTR	CENTER	PTD	PAINTED
DBL	DOUBLE	PTN	PARTITION
DEMO	DEMOLITION	PTxx	PAINT
DEPT	DEPARTMENT	QC	QUALITY CONTROL
DF	DRINKING FOUNTAIN	QTY	QUANTITY
DIA	DIAMETER	R	RADIUS
DIFF	DIFFUSER	RCF	REFLECTED CEILING PLAN
DIM	DIMENSION	RD	ROOF DRAIN
DN	DOWN	REC	RECESSED
DWG	DRAWING	REF	REFERENCE
EA	EACH	REQ	REQUIRE / REQUIRED
EJ	EXPANSION JOINT	REV	REVISION / REVISED
ELEV	ELEVATION	RM	ROOM
ELEC	ELECTRICAL	SCHED	SCHEDULE
EQ	EQUAL	SD	STORM DRAIN
EQUIP	EQUIPMENT	SECT	SECTION
EWC	ELECTRICAL WATER COOLER	SF	SQUARE FEET/FOOT
EXIST	EXISTING	SHT	SHEET
EXP	EXPANSION	SIM	SIMILAR
EXT	EXTERIOR	SPEC	SPECIFICATION
FA	FIRE ALARM	SPKR	SPEAKER
FACP	FIRE ALARM CONTROL PANEL	SPR	SPRINKLER
FD	FLOOR DRAIN	SS	STAINLESS STEEL
FDC	FIRE DEPARTMENT CONNECTION	SSK	SERVICE SINK
FEC	FIRE EXTINGUISHER CABINET	STD	STANDARD
FEK	FIRE EXTINGUISHER	STL	STEEL
FF	FINISH FLOOR	STOR	STORAGE
FF&E	FURNITURE, FINISHES & EQUIPMENT	STRL	STRUCTURAL
FIN	FINISH	SUSP	SUSPENDED
FKT	FIXTURE	SYMM	SYMMETRICAL
FT	FEET	TEL	TELEPHONE OR TELECOM
FURN	FURNITURE / FURNISHED	THK	THICKNESS
GC	GENERAL CONTRACT/OR	THRU	THROUGH
GWB	GYP/SIM WALLBOARD	TV	TELEVISION
HB	HOSE BOB	TYP	TYPICAL
HDW	HARDWARE	UL	UNDERWRITERS LABORATORY
HM	HOLLOW METAL	UNFIN	UNFINISHED
HSS	HOLLOW STRUCTURAL SECTION	U.N.O.	UNLESS NOTED OTHERWISE
HT	HEIGHT	UR	URINAL
HVAC	HEATING, VENTILATING, AIR CONDITIONING	VCT	VINYL COMPOSITION TILE
HW	HOT WATER	VERT	VERTICAL
IN	INCH	VEST	VESTIBULE
LAV	LAVATORY	VIF	VERIFY IN FIELD
		W	WIDE, WIDTH
		W/	WITH
		W/O	WITHOUT
		WC	WATER CLOSET
		WD	WOOD
		XTR	EXISTING TO REMAIN

Electrical Review - Roger Sanders PX651 - Reviewed - 7/14/2026

Mechanical Review - Roger Sanders PX651 - Reviewed - 7/14/2026

Plumbing Review - Roger Sanders PX651 - Reviewed - 7/14/2026

Fire Review - Jay Traina - NA to Private Provider - 7/16/2026

Building Review - Roger Sanders PX651 - Reviewed - 7/14/2026

SHEET #	SHEET NAME
A2-000	COVER SHEET
A2-100	LIFESAFETY PLAN
A2-101	FLOOR PLAN
A2-102	CEILING PLAN
A2-103	ROOF PLAN
A2-104	ELEVATIONS
A-002	ARCHITECTURAL SITE PLAN

LAFATE WILSON

a r c h i t e c t s

1030 arlington ave n, st petersburg fl 33705
(727) 490-9483
studio@lafatewilson.com

THE ARCHITECT'S COMMON LAW COPYRIGHT AND OTHER PROPERTY RIGHTS ARE HEREBY RESERVED IN THE IDEAS, DESIGNS, PLANS, DRAWINGS, AND SPECIFICATIONS SHALL NOT BE REPRODUCED OR CONVEYED IN ANY MANNER NOR ASSIGNED TO ANY THIRD PARTY WITHOUT FIRST OBTAINING THE EXPRESS WRITTEN PERMISSION OF THE ARCHITECT.

OLD MEMORIAL


13600 National Golf Dr
Tampa, FL 33626

no.	description	date
	PERMIT SET	04.24.26

A2-000

COVER SHEET

Electrical Review - Roger Sanders PX651 - Reviewed - 7/14/2026
Mechanical Review - Roger Sanders PX651 - Reviewed - 7/14/2026
Plumbing Review - Roger Sanders PX651 - Reviewed - 7/14/2026
Fire Review - Jay Traina - NA to Private Provider - 7/16/2026
Building Review - Roger Sanders PX651 - Reviewed - 7/14/2026

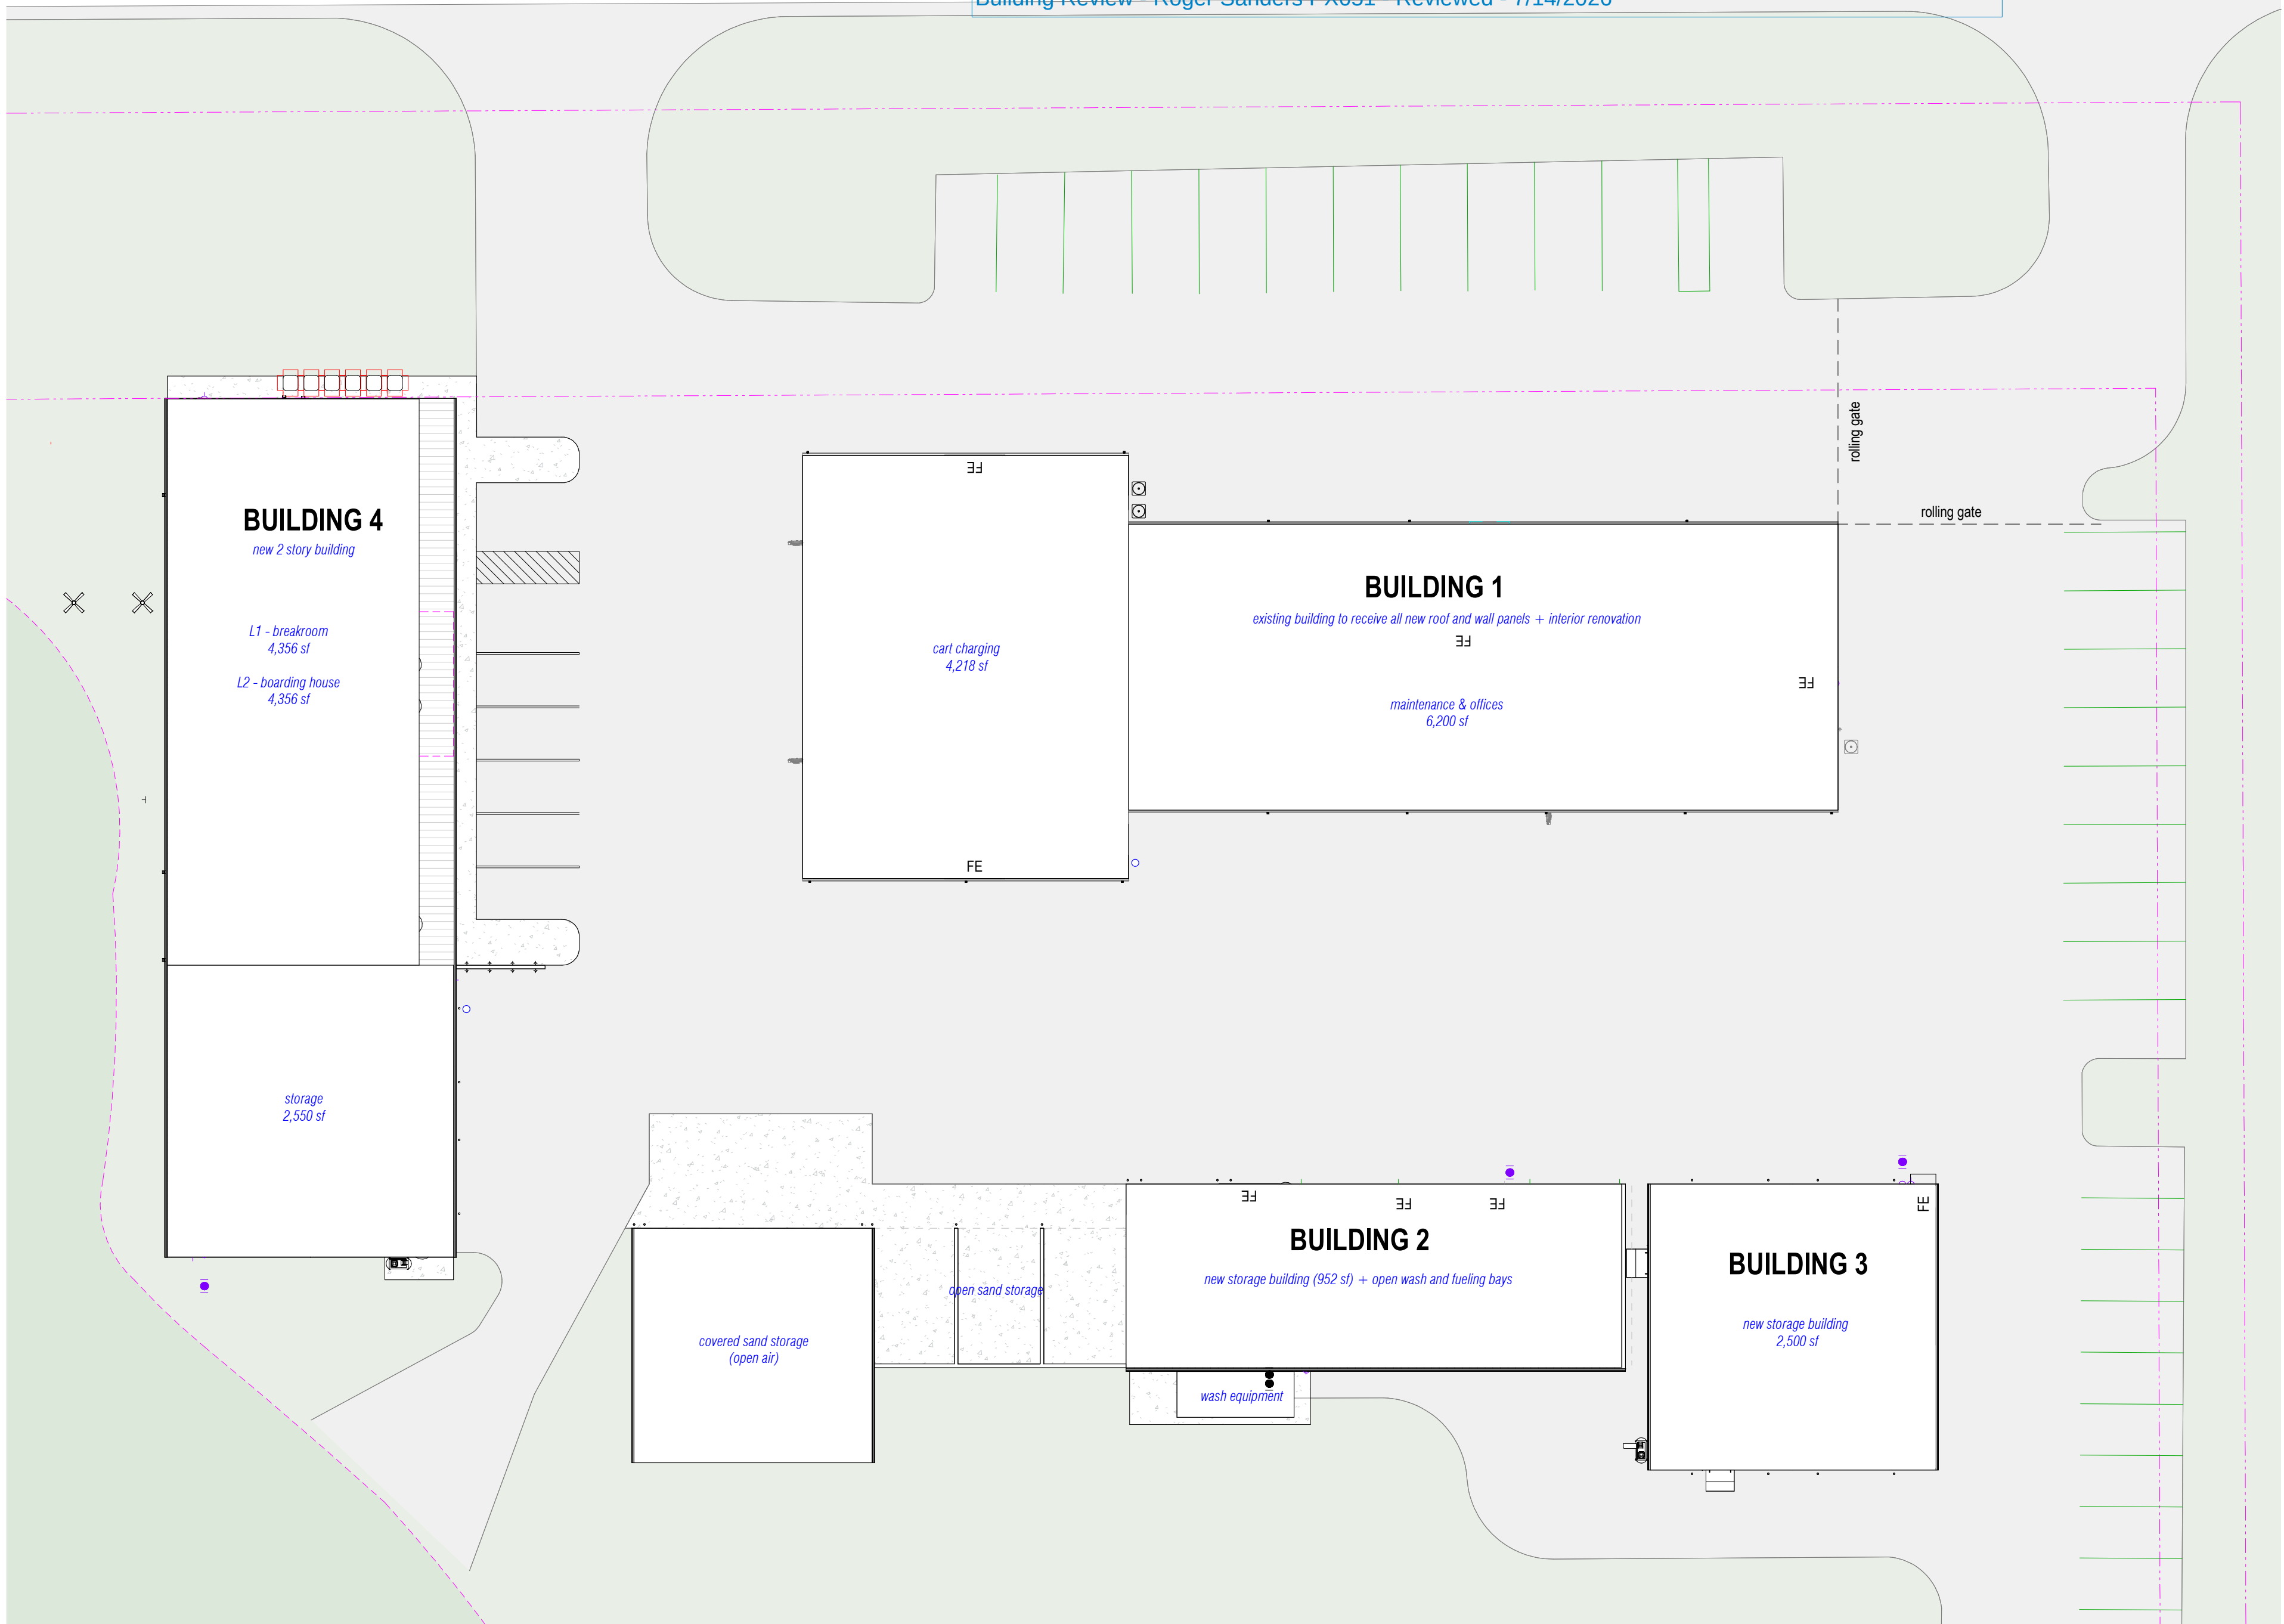

 1 | SITE PLAN
1" = 20'-0"

ARCHITECTURAL SITE PLAN FOR BUILDING LOCATION REFERENCE ONLY. REFER TO CIVIL PLANS FOR SITE LAYOUT AND DETAILS.

LAFATE WILSON

architects

1030 arlington ave n, st petersburg fl 33705
(727) 490-9483
studio@lafatewilson.com

THE ARCHITECT'S COMMON LAW COPYRIGHT AND OTHER
PROPERTY RIGHTS ARE HEREBY RESERVED IN THE IDEAS, DESIGNS,
PLANS, DRAWINGS, AND SPECIFICATIONS SHALL NOT BE
REPRODUCED OR CONVEYED IN ANY MANNER NOR ASSIGNED TO
ANY THIRD PARTY WITHOUT FIRST OBTAINING THE EXPRESS
WRITTEN PERMISSION OF THE ARCHITECT.

OLD MEMORIAL

13600 National Golf Dr
Tampa, FL 33626

no.	description	date
	PERMIT SET	04.24.26

A-002

ARCHITECTURAL
SITE PLAN



Product iQ®

Design/System/Construction/Assembly Usage Disclaimer

- Authorities Having Jurisdiction should be consulted in all cases as to the particular requirements covering the installation and use of UL Certified products, equipment, system, devices, and materials.
- Authorities Having Jurisdiction should be consulted before construction.
- Fire resistance assemblies and products are developed by the design submitter and have been investigated by UL for compliance with applicable requirements. The published information cannot always address every construction nuance encountered in the field.
- When field issues arise, it is recommended the first contact for assistance be the technical service staff provided by the product manufacturer noted for the design. Users of fire resistance assemblies are advised to consult the general Guide Information for each product category and each group of assemblies. The Guide Information includes specifics concerning alternate materials and alternate methods of construction.
- Only products which bear UL's Mark are considered Certified.

BXUV - Fire Resistance Ratings - ANSI/UL 263 Certified for United States
BXUV7 - Fire Resistance Ratings - CAN/ULC-S101 Certified for Canada
[See General Information for Fire-Resistance Ratings - ANSI/UL 263 Certified for United States Design Criteria and Allowable Variances](#)



[See General Information for Fire Resistance Ratings - CAN/ULC-S101 Certified for Canada Design Criteria and Allowable Variances](#)

Design No. **U906**

January 14, 2026

Bearing Wall Rating — 2 HR.
Nonbearing Wall Rating — 2 HR.
This design was evaluated using a load design method other than the Limit States Design Method (e.g., Working Stress Design Method). For jurisdictions employing the Limit States Design Method, such as Canada, a load restriction factor shall be used — See Guide [BXUV](#) or [BXUV7](#)

* Indicates such products shall bear the UL or cUL Certification Mark for jurisdictions employing the UL or cUL Certification (such as Canada), respectively.

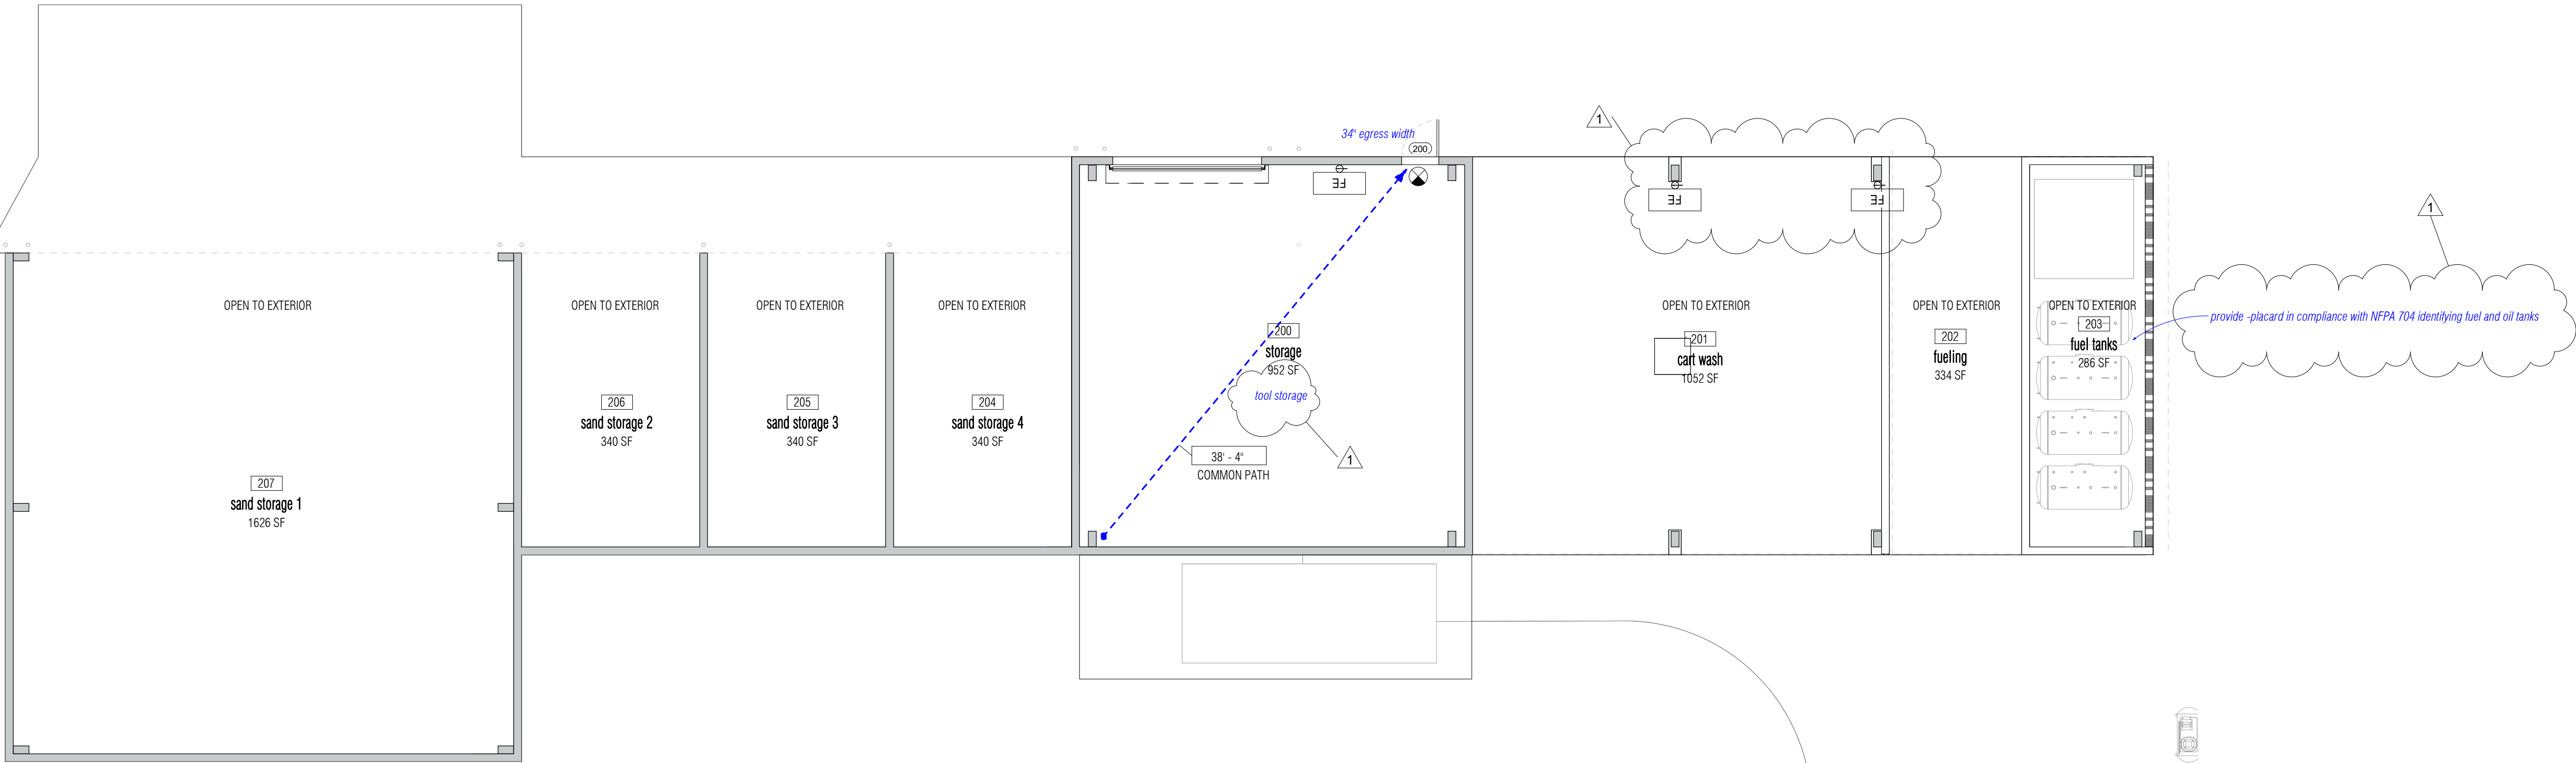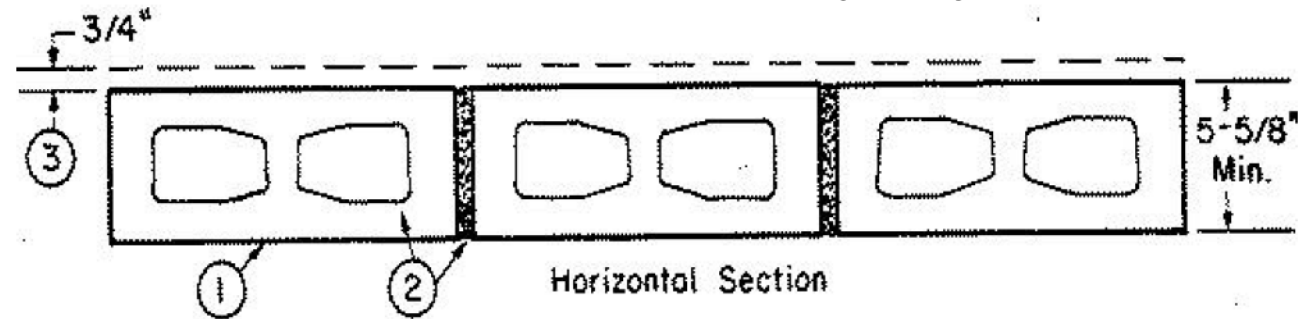

Reviewed for Code Compliance
With The Florida Building Code
ECS, Florida LLC
41-5640-BLD2 7/20/2026

Electrical Review - Roger Sanders PX651 - Reviewed - 7/14/2026

Mechanical Review - Roger Sanders PX651 - Reviewed - 7/14/2026

Plumbing Review - Roger Sanders PX651 - Reviewed - 7/14/2026

Fire Review - Jay Traina, N/A to Private Provider - 7/16/2026

JOHN MANVILLE - Type AP Foil-Faced Foam Sheathing

Building Review - Roger Sanders PX651 - Reviewed - 7/14/2026

4A. **Building Units*** — As an alternate to Item 4, min. 1-in thick polyisocyanurate composite foamed plastic insulation boards, nom. 48 by 48 or 96 in.

ATLAS ROOFING CORP — EnergyShield® Ply

RMAX, A BUSINESS UNIT OF SIKA CORPORATION — "Thermasheath-SI", "ECOBASecI", "ThermaBase-CI", "ECOMAXci FR Ply", "ECOMAXci Ply"

4B. **Foamed Plastic*** — (Optional — Not Shown) — As an alternate to Item 4 - Expanded polystyrene insulation installed at a maximum nominal density of 2.0 lb/ft³ attached to concrete blocks (Item 1).

BASF CORP STYRENIC FOAMS DIV — Neopor® GPS and NeoTherm GPS

* Indicates such products shall bear the UL or cUL Certification Mark for jurisdictions employing the UL or cUL Certification (such as Canada), respectively.

Last Updated on 2026-01-14

UL Solutions permits the reproduction of the material contained in Product iQ subject to the following conditions: 1. The Guide Information, Assemblies, Constructions, Designs, Systems, and/or Certifications (files) must be presented in their entirety and in a non-misleading manner, without any manipulation of the data (or drawings); 2. The statement "Reprinted from Product iQ with permission from UL Solutions" must appear adjacent to the extracted material. In addition, the reprinted material must include a copyright notice in the following format: "©2026 UL LLC."

OCCUPANCY LOAD TABLE - BUILDING 2

NUMBER	ROOM NAME	AREA	OCCUPANCY TYPE	FUNCTION OF SPACE	OCC LOAD FACTOR	OCCUPANT TOTAL
200	storage	952 SF	S/M		300	4
201	cart wash	1052 SF				
202	fueling	334 SF				
203	fuel tanks	286 SF				
204	sand storage 4	340 SF				
205	sand storage 3	340 SF				
206	sand storage 2	340 SF				
207	sand storage 1	1626 SF				
Grand total: 8		5272 SF			4	

LIFE SAFETY GENERAL NOTES

- ALL PENETRATIONS THROUGH FIRE RATED ASSEMBLIES SHALL BE SEALED AS REQUIRED BY BUILDING AND FIRE CODES AND AS BY GOVERNING AUTHORITIES.
- VERIFY LOCATIONS FOR FIRE ALARM PULL STATIONS, FIRE ALARM ANNUNCIATOR PANEL, FIRE ALARM REMOTE CONTROL PANEL, EMERGENCY LIGHTING , STROBES AND AUDIBLE ALERTS.
- INSTALL FIRE EXTINGUISHERS IN ACCORDANCE WITH NFPA 10 BY A LICENSED FIRE EQUIPMENT DEALER. INSPECT, TAG, AND MOUNT ALL FIRE EXTINGUISHERS. SEE LOCATION IN PLAN
- ALL PANIC AND FIRE EXIT HARDWARE TO BE COMPLIANT WITH FBC SECTION 1008.1.10
- FINAL EXIT SIGNS AND EMERGENCY LIGHTING LOCATIONS ARE SUBJECT TO THE APPROVAL OF THE GOVERNING JURISDICTION. APPLICABLE SIGNAGE SHALL BE PROVIDED BY CONTRACTOR AND COORDINATE WITH OTHER BUILDING SIGNAGE. REFER TO FBC SECTION 1013.4 FOR RAISED CHARACTER AND BRAILLE EXIT SIGN REQUIREMENTS.

LIFE SAFETY PLAN LEGEND

*COORDINATE ITEMS W/ ELECTRICAL AS REQUIRED

- ILLUMINATED (DIRECTIONAL) EXIT SIGN
- RECESSED FIRE EXTINGUISHER CABINET
- WALL HUNG FIRE EXTINGUISHER
- DOOR TAG
- TOTAL EXIT ACCESS TRAVEL DISTANCE (FEET)
- 1 HR FIRE SEPARATION WALL
- OCCUPANT LOAD SIGN PER FBC 1004.9

OLD MEMORIAL

13600 National Golf Dr
Tampa, FL 33626

no.	description	date
	PERMIT SET	04.24.26
1	REVISION 01	06.19.26

A2-100
LIFESAFETY PLAN

GENERAL NOTES - DEMOLITION

- ALL DIMENSIONS AND CONDITIONS TO BE FIELD VERIFIED BY CONTRACTOR PRIOR TO WORK. NOTIFY ARCHITECT IF CONFLICTS ARE FOUND.
- PROTECT ALL AREAS TO REMAIN. G.C. TO REPAIR OR REPLACE ANY ITEM TO REMAIN OR TO BE RELOCATED THAT IS DAMAGED DURING THE WORK. PROVIDE A SEAMLESS, UNDAMAGED APPEARANCE WHEN JOINING NEW TO EXISTING.
- REMOVE DASHED PORTION OF EXISTING WALLS, DOORS, WINDOWS, SIDELIGHTS, TRANSOMS, AND FRAMES. PREPARE AREA TO RECEIVE NEW CONSTRUCTION AS SCHEDULED.
- FIRE RESISTANCE - MAINTAIN INTEGRITY OF EXISTING FIRE AND/OR SMOKE PARTITIONS THROUGHOUT. UNLESS OTHERWISE NOTED, MAINTAIN INTEGRITY OF ALL EXISTING FIREPROOFING, FIRE STOPPING, COLUMN ENCLOSURES, ETC. TO ENSURE FIRE RESISTANCE MEETS OR EXCEEDS THAT ORIGINALLY REQUIRED OR SPECIFIED. PATCH ALL AREAS DAMAGED OR REMOVED DUE TO NEW CONSTRUCTION TO MATCH THAT OF THE EXISTING OR AS REQUIRED FOR NEW.
- FINISHES - ALL EXISTING FINISHES SHALL REMAIN, UNLESS SCHEDULED FOR NEW. CONTINUE EXISTING FINISHES TO REMAIN INTO NEW EXTENDED AREAS THAT ARE ADJACENT. PATCH & REPAIR EXISTING TO MATCH NEW. PREPARE SUBSTRATES TO RECEIVE NEW FINISHES WHERE SCHEDULED. FINISH ALL PATCHED OR EXTENDED WALLS TO NEAREST CHANGE OF DIRECTION, WALL TERMINATION, OR INTERSECTION. PHASING - COORDINATE EQUIPMENT DELIVERIES AND INSTALLATION WITH THE PHASING PLAN FOR APPROPRIATE SCHEDULING.
- CONFLICTS - ANY CONFLICT FOUND WITH EXISTING CONDITIONS AND REQUIREMENTS FOR NEW CONSTRUCTION SHALL BE IMMEDIATELY BROUGHT TO THE ATTENTION OF THE ARCHITECT. IF THE CONFLICT AFFECTS THE PROGRESS OF THE WORK, VERIFY WITH ARCHITECT SOLUTION NECESSARY PRIOR TO PROCEEDING WITH THAT PORTION OF THE WORK AND IN A TIMELY FASHION SO AS NOT TO DELAY THE WORK. COORDINATE ALL TRADES TO ASCERTAIN NO FURTHER WORK WILL BE IMPACTED BY THE CONFLICT, OR ITS SOLUTION.


GENERAL FLOOR PLAN NOTES

- PROVIDE SUPPORT FOR WALL MOUNTED CABINETS AND PLUMBING FIXTURES. STEEL STUDS SUPPORTING WALL MOUNTED FIXTURES TO BE DOUBLED AT 16 O.C. OR NOT LESS THAN 20 GAUGE PER FBC 2517.5.1.1.
- PROVIDE CEMENTITIOUS BACKER BOARD IN PLACE OF GWB AT ALL LOCATIONS SHOWING TILE FINISH.


LEGEND

- EXISTING WALL TO REMAIN
- EXISTING TO BE REMOVED
- EXISTING TO REMAIN

WALL TYPES

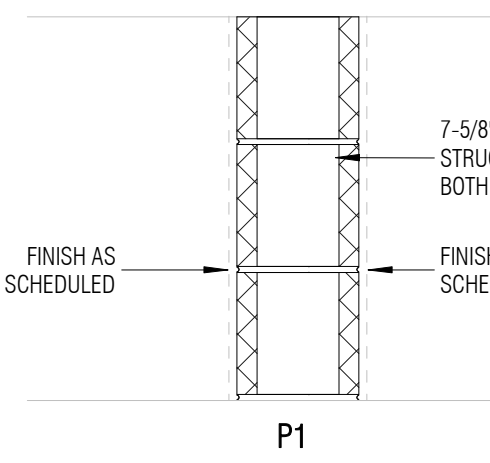

0 HR

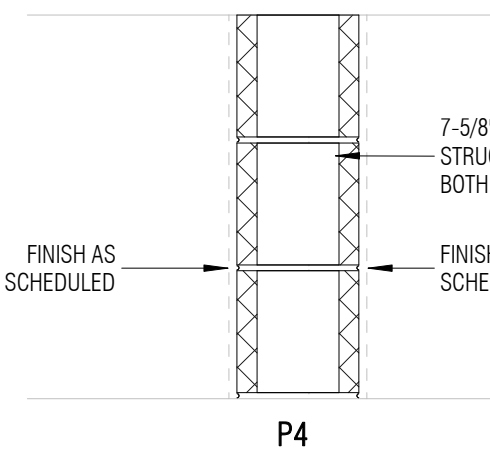


2 HR UL-U906


LAFATE WILSON
a r c h i t e c t s

1030 arlington ave n, st petersburg fl 33705
(727) 490-9483
studio@lafatewilson.com

THE ARCHITECT'S COMMON LAW COPYRIGHT AND OTHER PROPERTY RIGHTS ARE HEREBY RESERVED IN THE IDEAS, DESIGNS, PLANS, DRAWINGS, AND SPECIFICATIONS SHALL NOT BE REPRODUCED OR CONVEYED IN ANY MANNER NOR ASSIGNED TO ANY THIRD PARTY WITHOUT FIRST OBTAINING THE EXPRESS WRITTEN PERMISSION OF THE ARCHITECT.

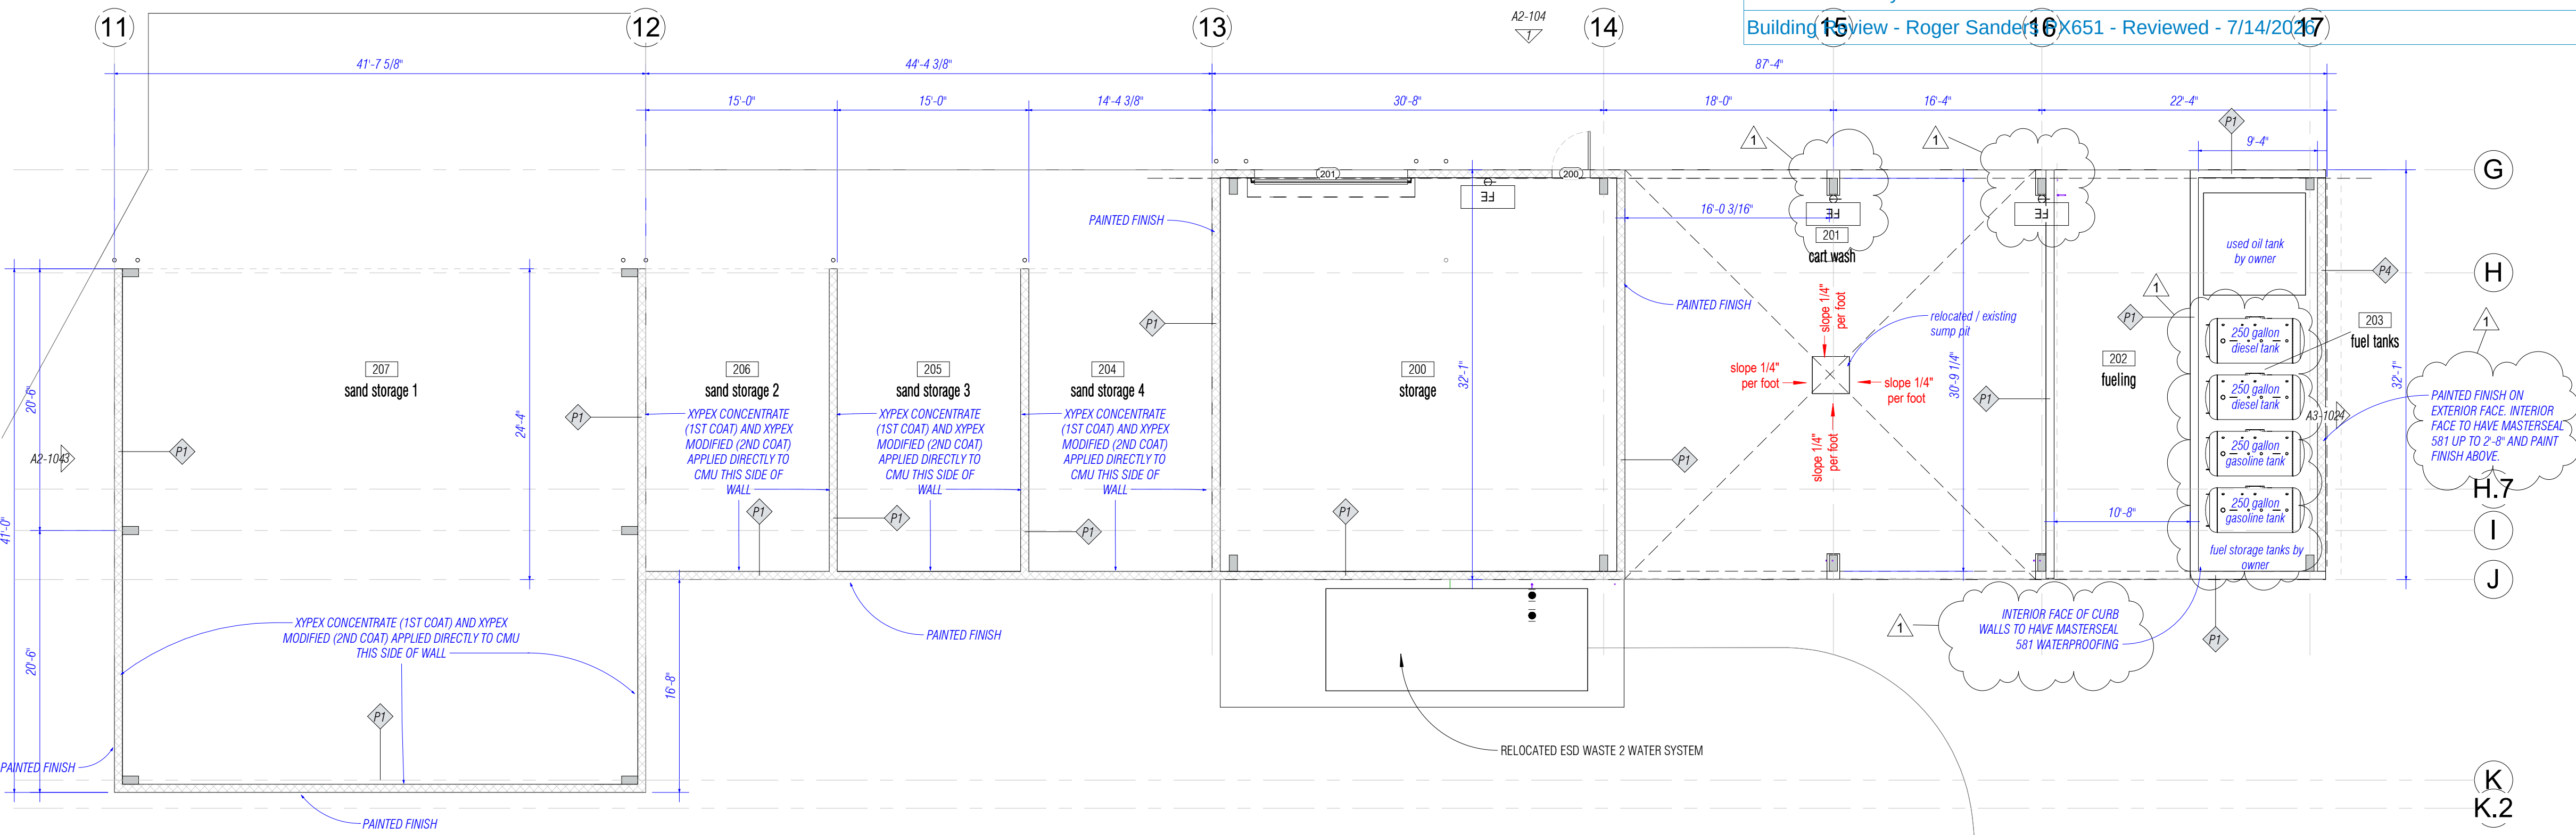

1 BUILDING 2 - FLOOR PLAN
1/8" = 1'-0"

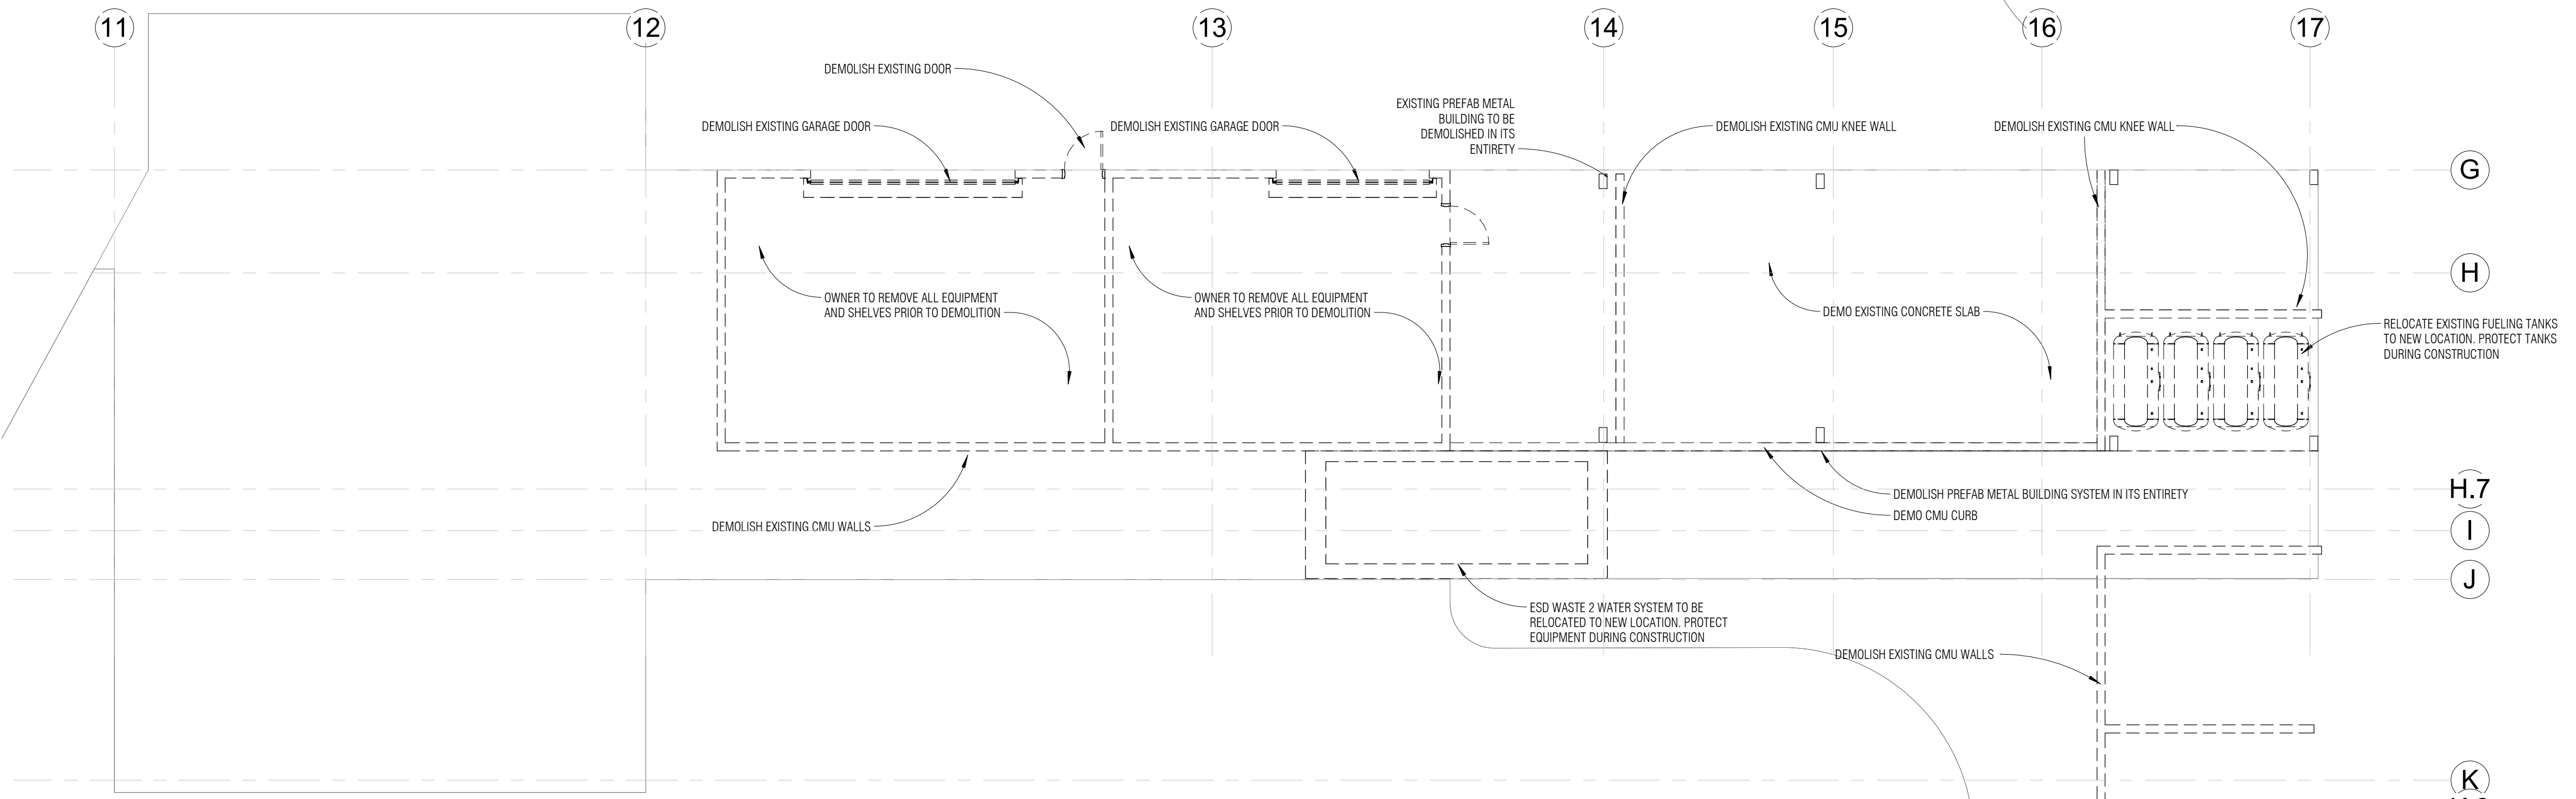


2 BUILDING 2 - DEMO PLAN
1/8" = 1'-0"

#	WIDTH	HEIGHT	TYPE	FRAME MATERIAL	FRAME FINISH	DOOR MATERIAL	DOOR FINISH	HARDWARE
200	3'-0"	6'-8"	D1	HM	PAINTED	HM	PAINTED	04
201	12'-0"	11'-8"	D3	STEEL	PAINTED	STEEL	WHITE	20

DOOR SCHEDULE

NOTE: VERIFY ALL WINDOW AND DOOR ROUGH OPENING SIZES WITH MANUFACTURER'S REQUIREMENTS

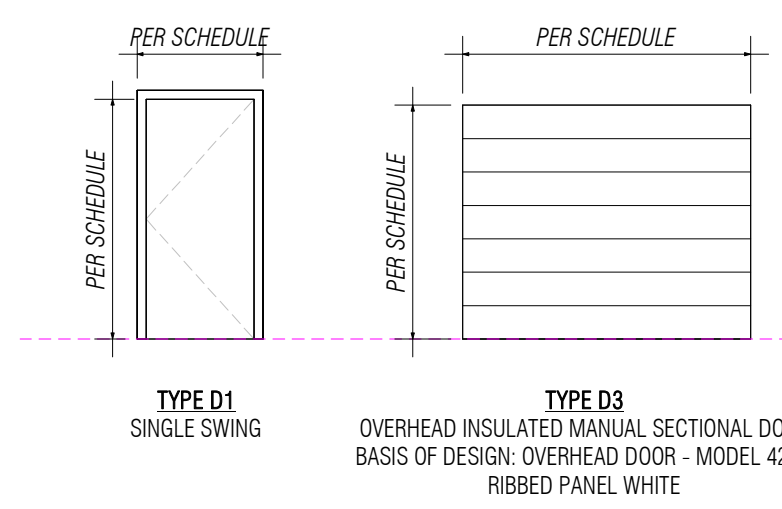

QTY	DESCRIPTION	CATALOG NUMBER	FINISH	MFR
3	EA HINGE	5BB1 4.5 X 4.5 NRP	630	IVE
1	EA STOREROOM LOCK	ND80P8D RHO	626	SCH
1	EA SURFACE CLOSER	4040XP SCUSH	689	LCN
1	EA KICK PLATE	8400 10" X 2" LDW B-CS	630	IVE
1	EA RAIN DRIP	142AA (IF EXPOSED ABOVE)	AA	ZER
1	EA GASKETING	188SBK PSA	BK	ZER
1	EA DOOR SWEEP	328AA	AA	ZER
1	EA THRESHOLD	65A	A	ZER

QTY	DESCRIPTION	CATALOG NUMBER	FINISH	MFR
1	EA ALL HARDWARE BY ROLL UP DOOR MANUFACTURER			

OLD MEMORIAL

13600 National Golf Dr
Tampa, FL 33626

no.	description	date
1	PERMIT SET	04.24.26
1	REVISION 01	06.19.26

A2-101
FLOOR PLAN



Electrical Review - Roger Sanders PX651 - Reviewed - 7/14/2026
Mechanical Review - Roger Sanders PX651 - Reviewed - 7/14/2026
Plumbing Review - Roger Sanders PX651 - Reviewed - 7/14/2026
Fire Review - Jay Traina - NA to Private Provider - 7/16/2026
Building Review - Roger Sanders PX651 - Reviewed - 7/14/2026


CEILING LEGEND

- EXPOSED STRUCTURE
- SURFACE MOUNTED FIXTURE
- EM LIGHT


LAFATE WILSON
a r c h i t e c t s

1030 arlington ave n, st petersburg fl 33705
(727) 490-9483
studio@lafatewilson.com

THE ARCHITECT'S COMMON LAW COPYRIGHT AND OTHER
PROPERTY RIGHTS ARE HEREBY RESERVED IN THE IDEAS, DESIGNS,
PLANS, DRAWINGS, AND SPECIFICATIONS SHALL NOT BE
REPRODUCED OR CONVEYED IN ANY MANNER NOR ASSIGNED TO
ANY THIRD PARTY WITHOUT FIRST OBTAINING THE EXPRESS
WRITTEN PERMISSION OF THE ARCHITECT.

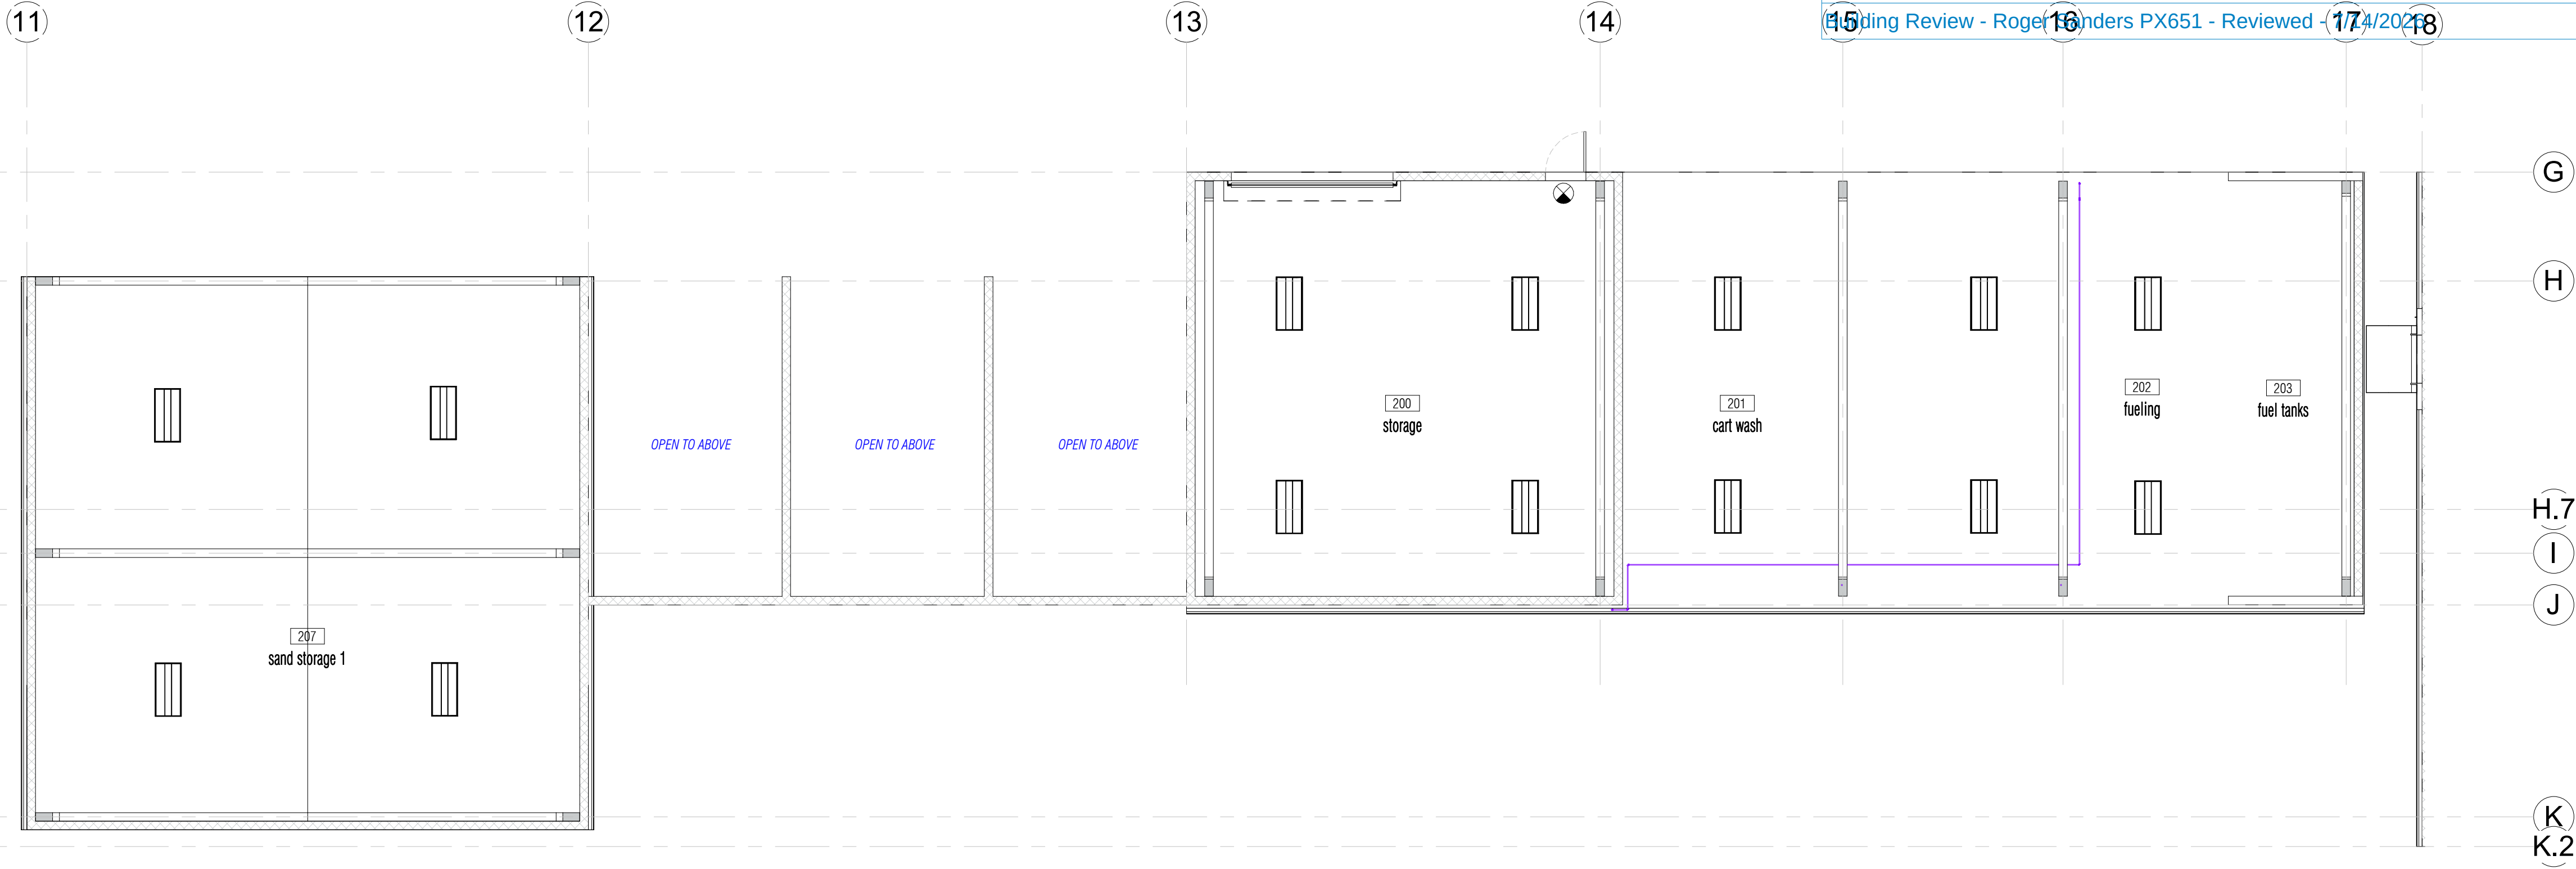

1 | BUILDING 2 - RCP
1/8" = 1'-0"

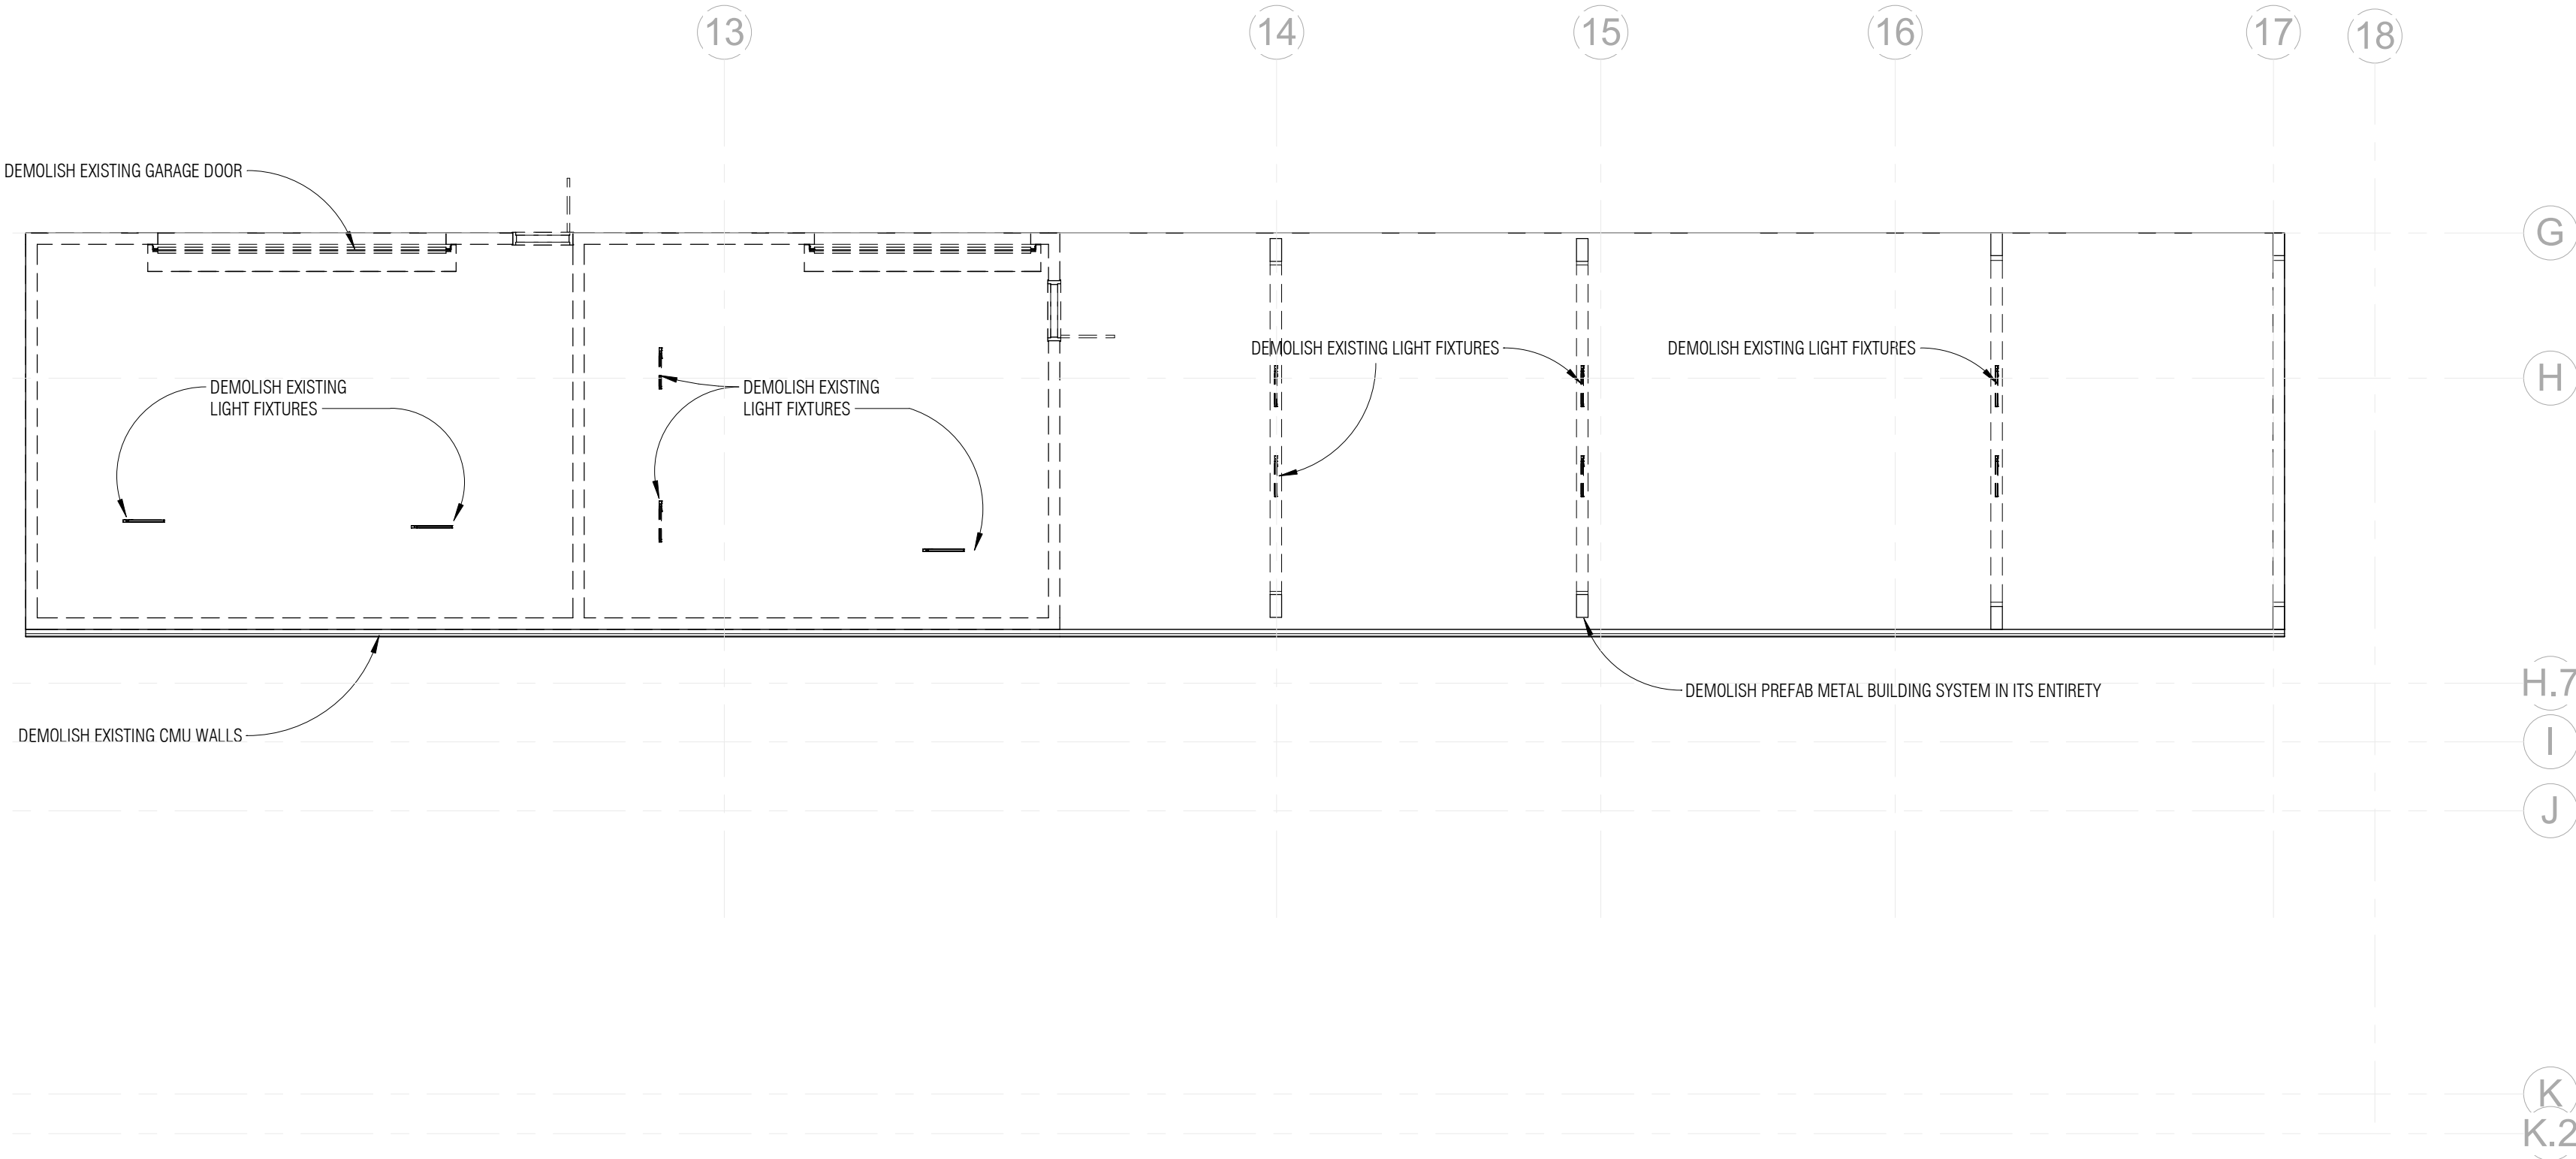


2 | BUILDING 2 - DEMO RCP
1/8" = 1'-0"

OLD MEMORIAL


13600 National Golf Dr
Tampa, FL 33626

no.	description	date
1	PERMIT SET	04.24.26

A2-102
CEILING PLAN

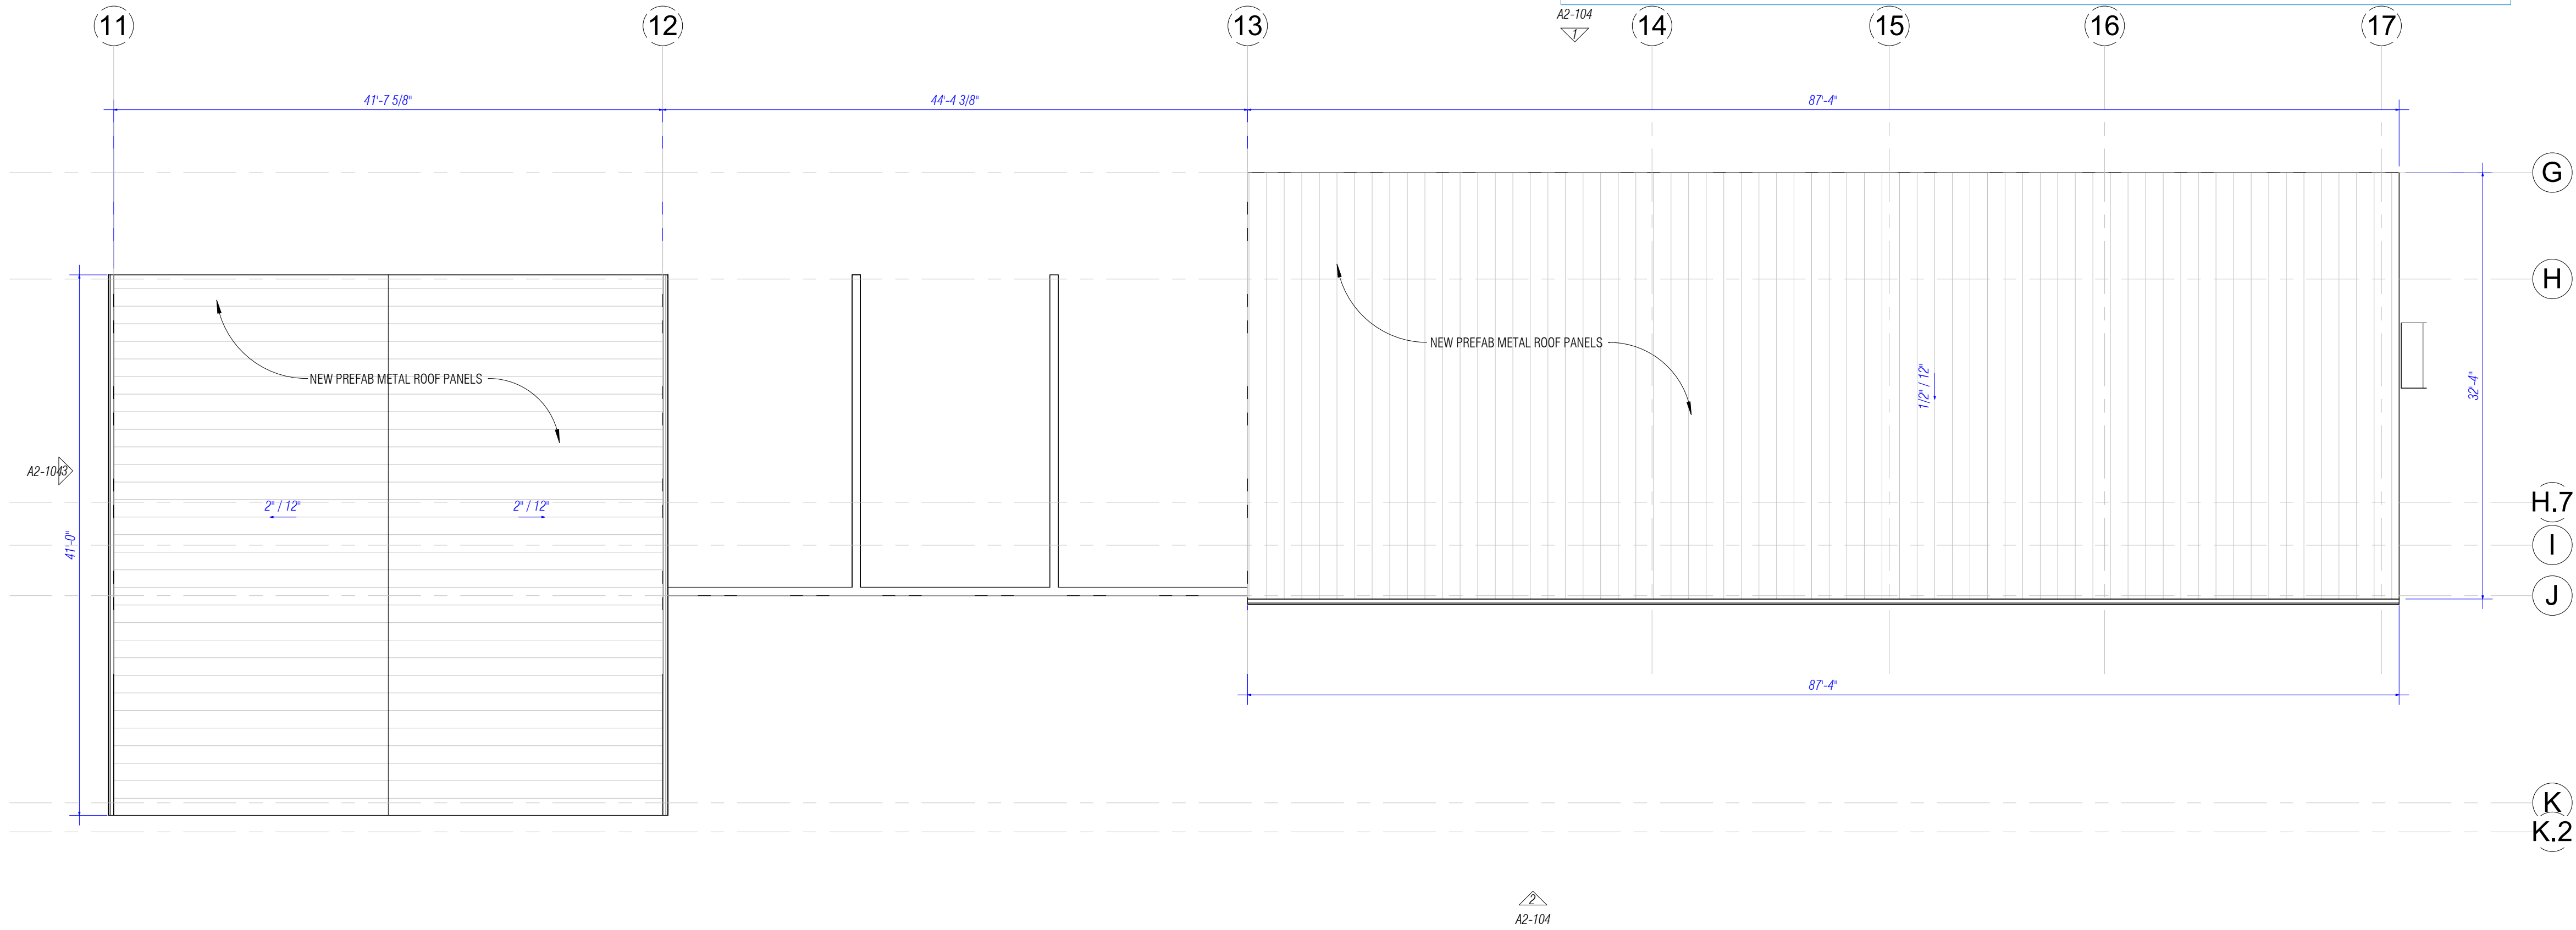

1 | BUILDING 2 - ROOF PLAN
1/8" = 1'-0"

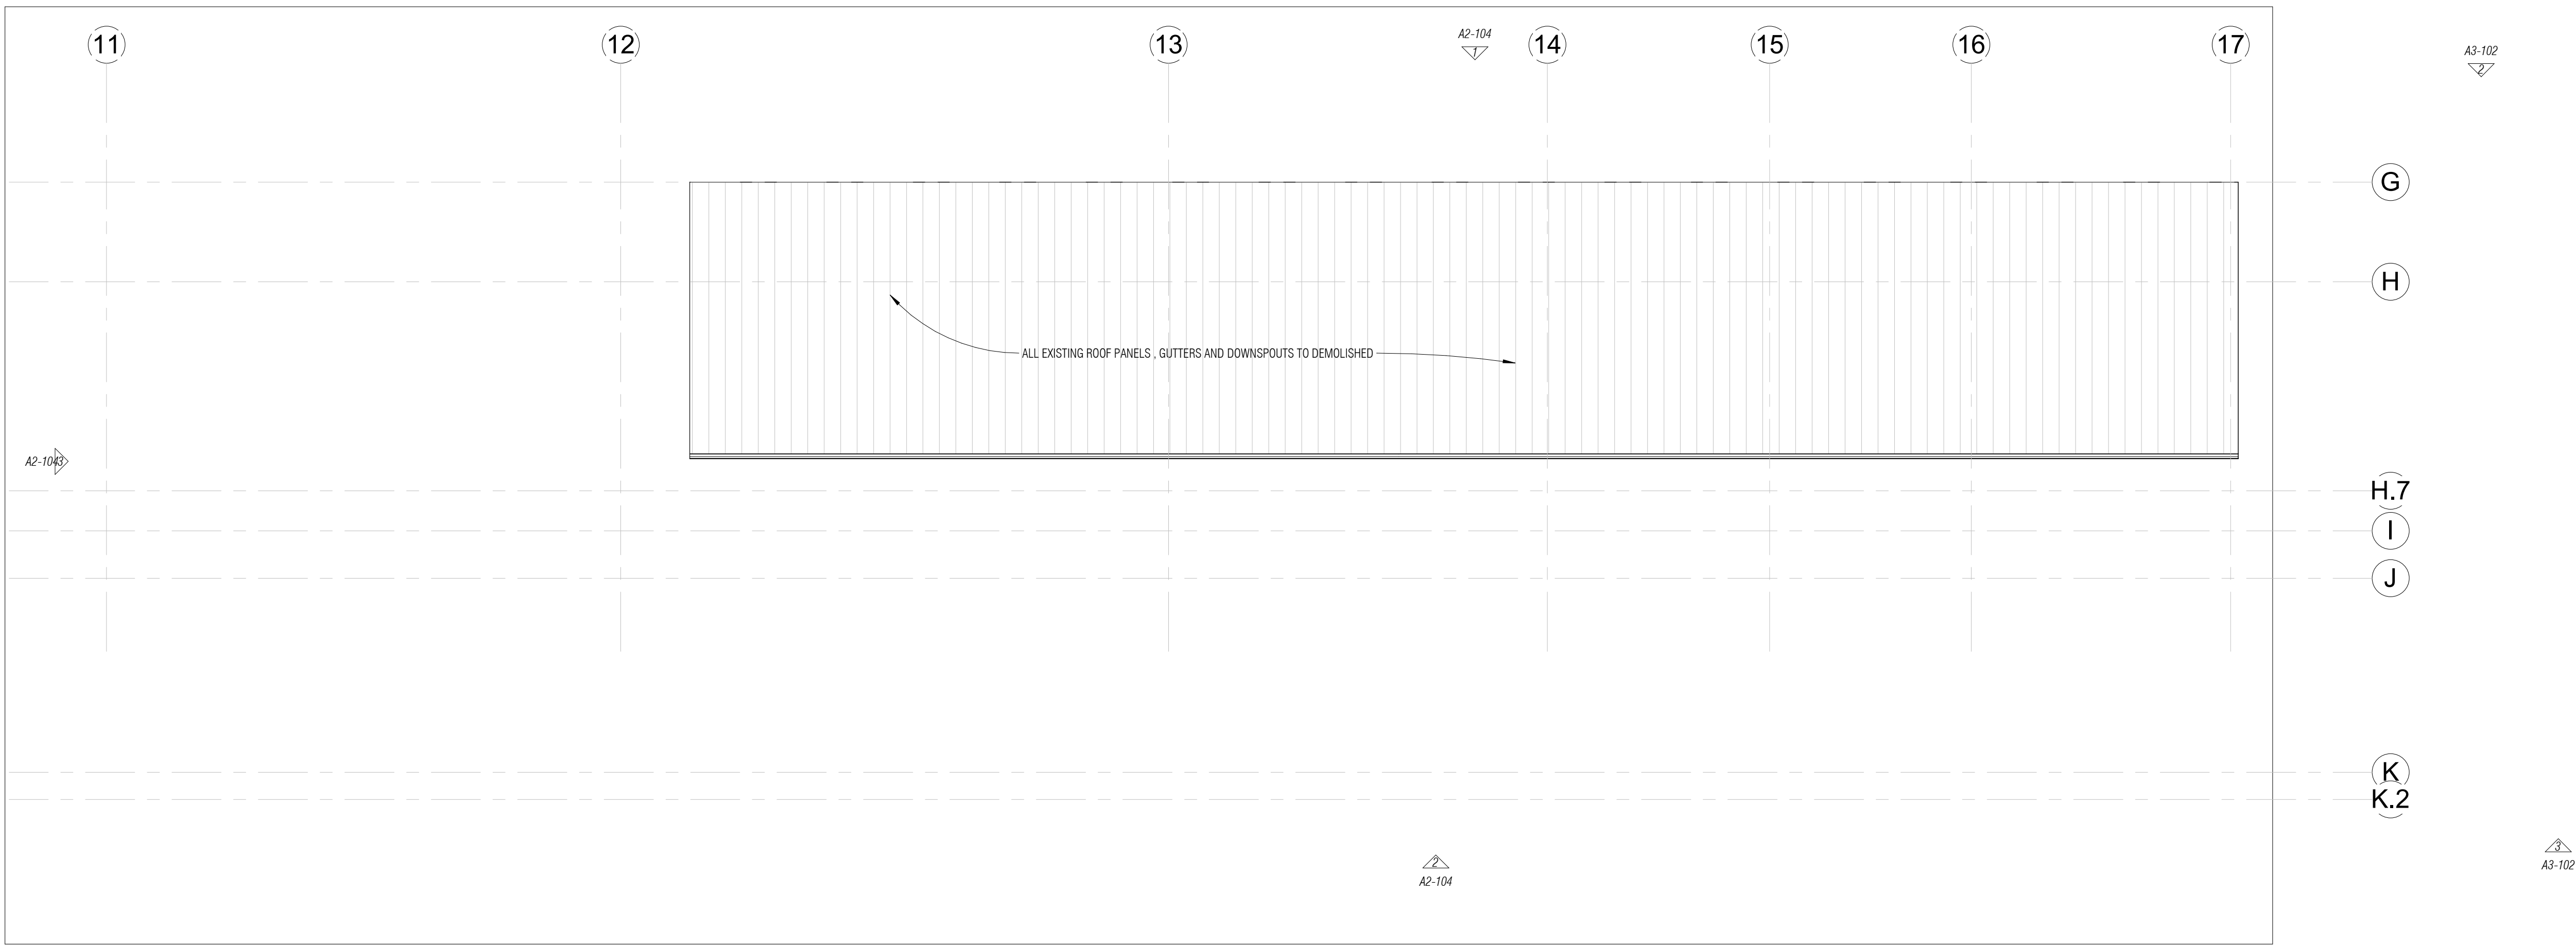


2 | BUILDING 2 - DEMO ROOF PLAN
1/8" = 1'-0"

OLD MEMORIAL


13600 National Golf Dr
Tampa, FL 33626

no.	description	date
1	PERMIT SET	04.24.26


A2-103
ROOF PLAN

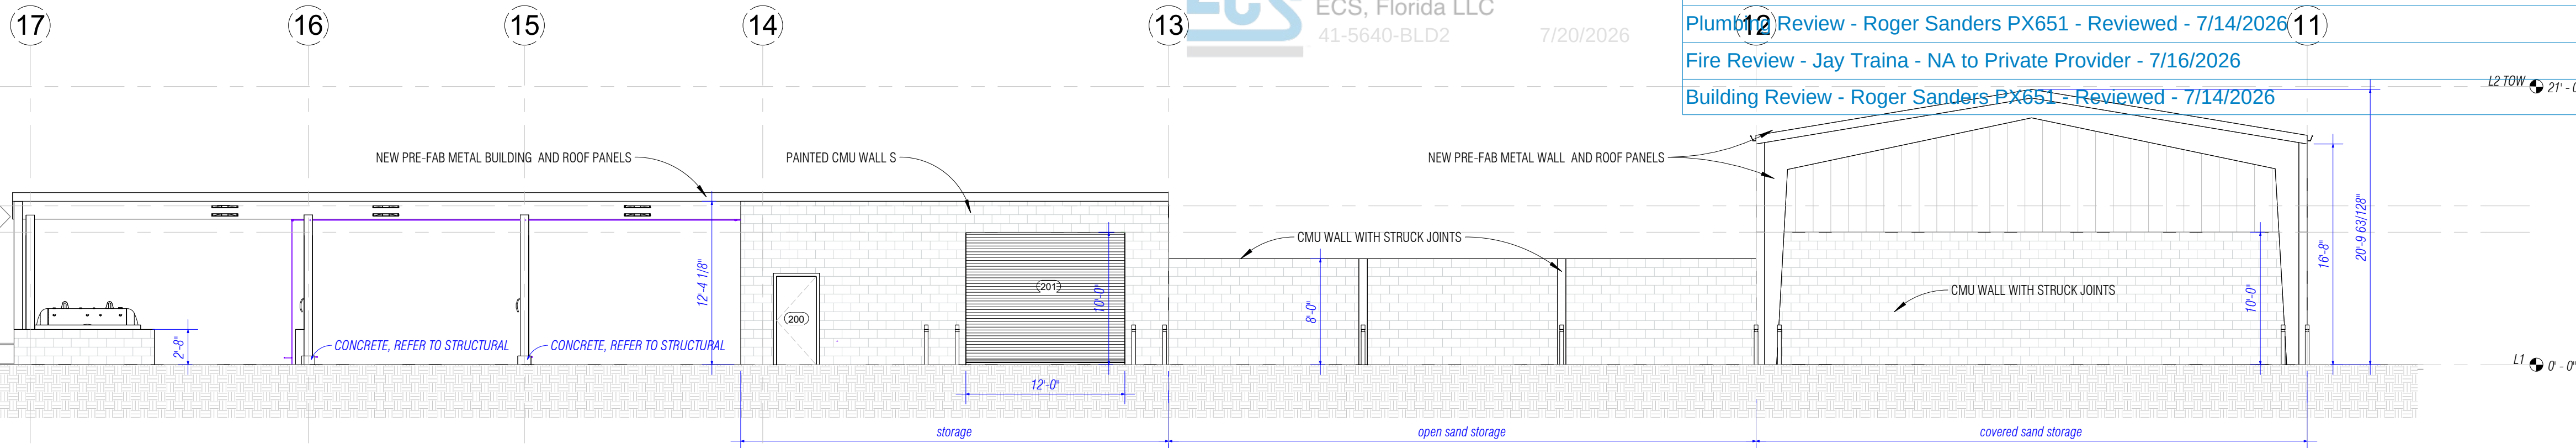



1 sand & chem storage - north elevation
18' - 1'-0"

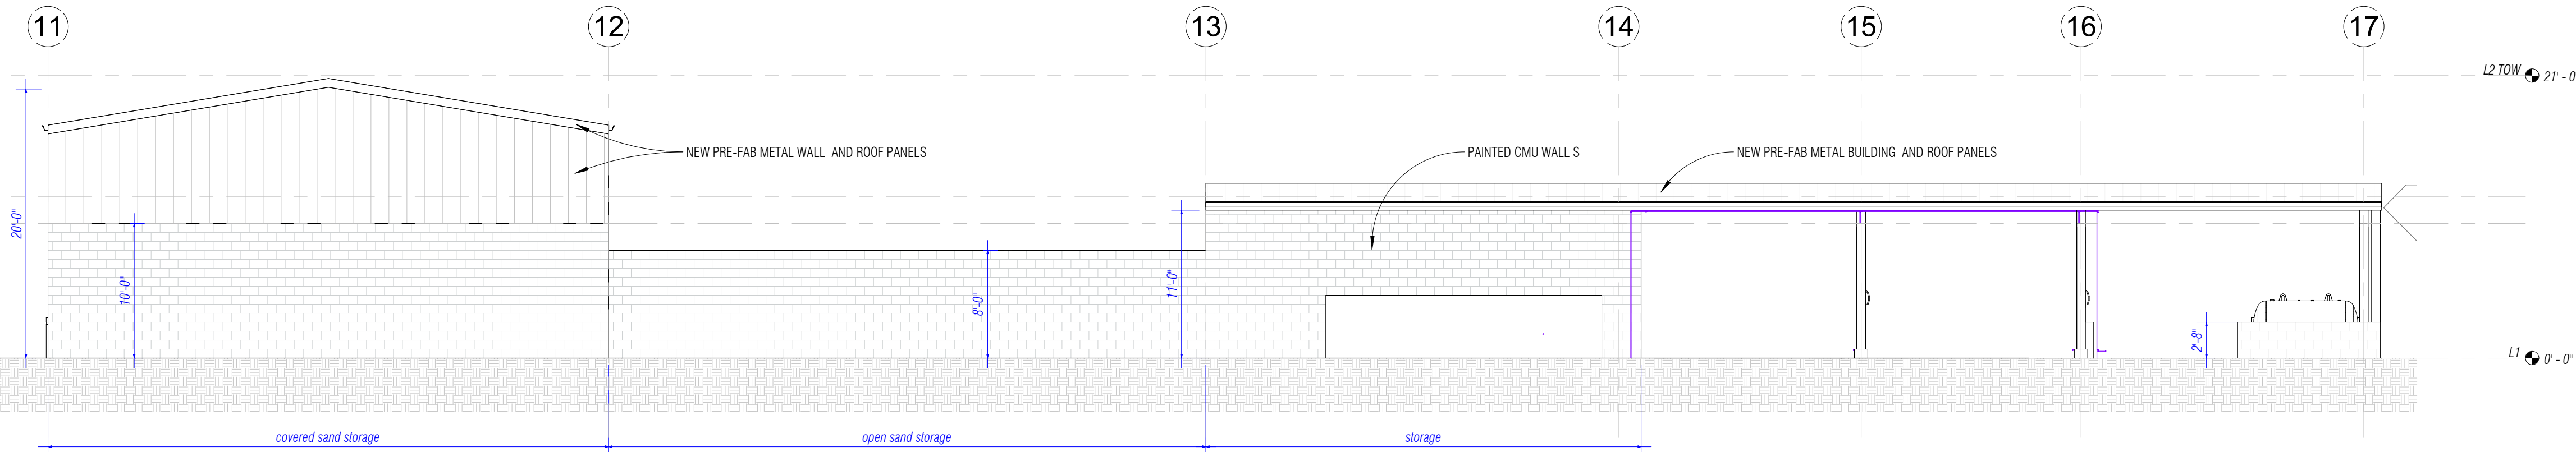

2 sand & chem storage - south elevation
18' - 1'-0"

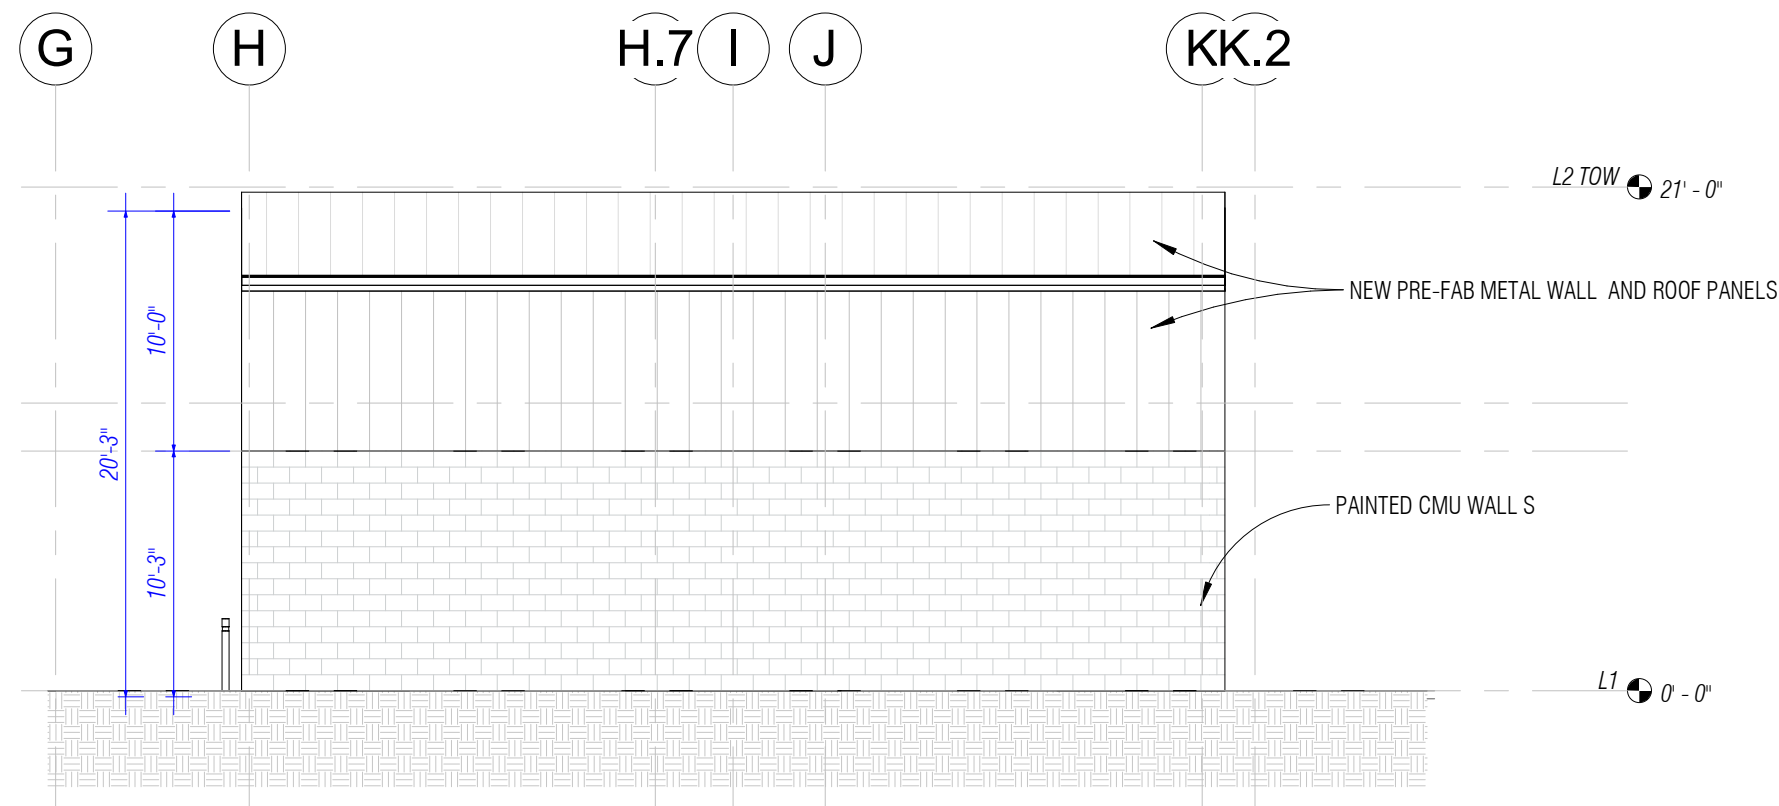

3 sand storage - west elevation
18' - 1'-0"

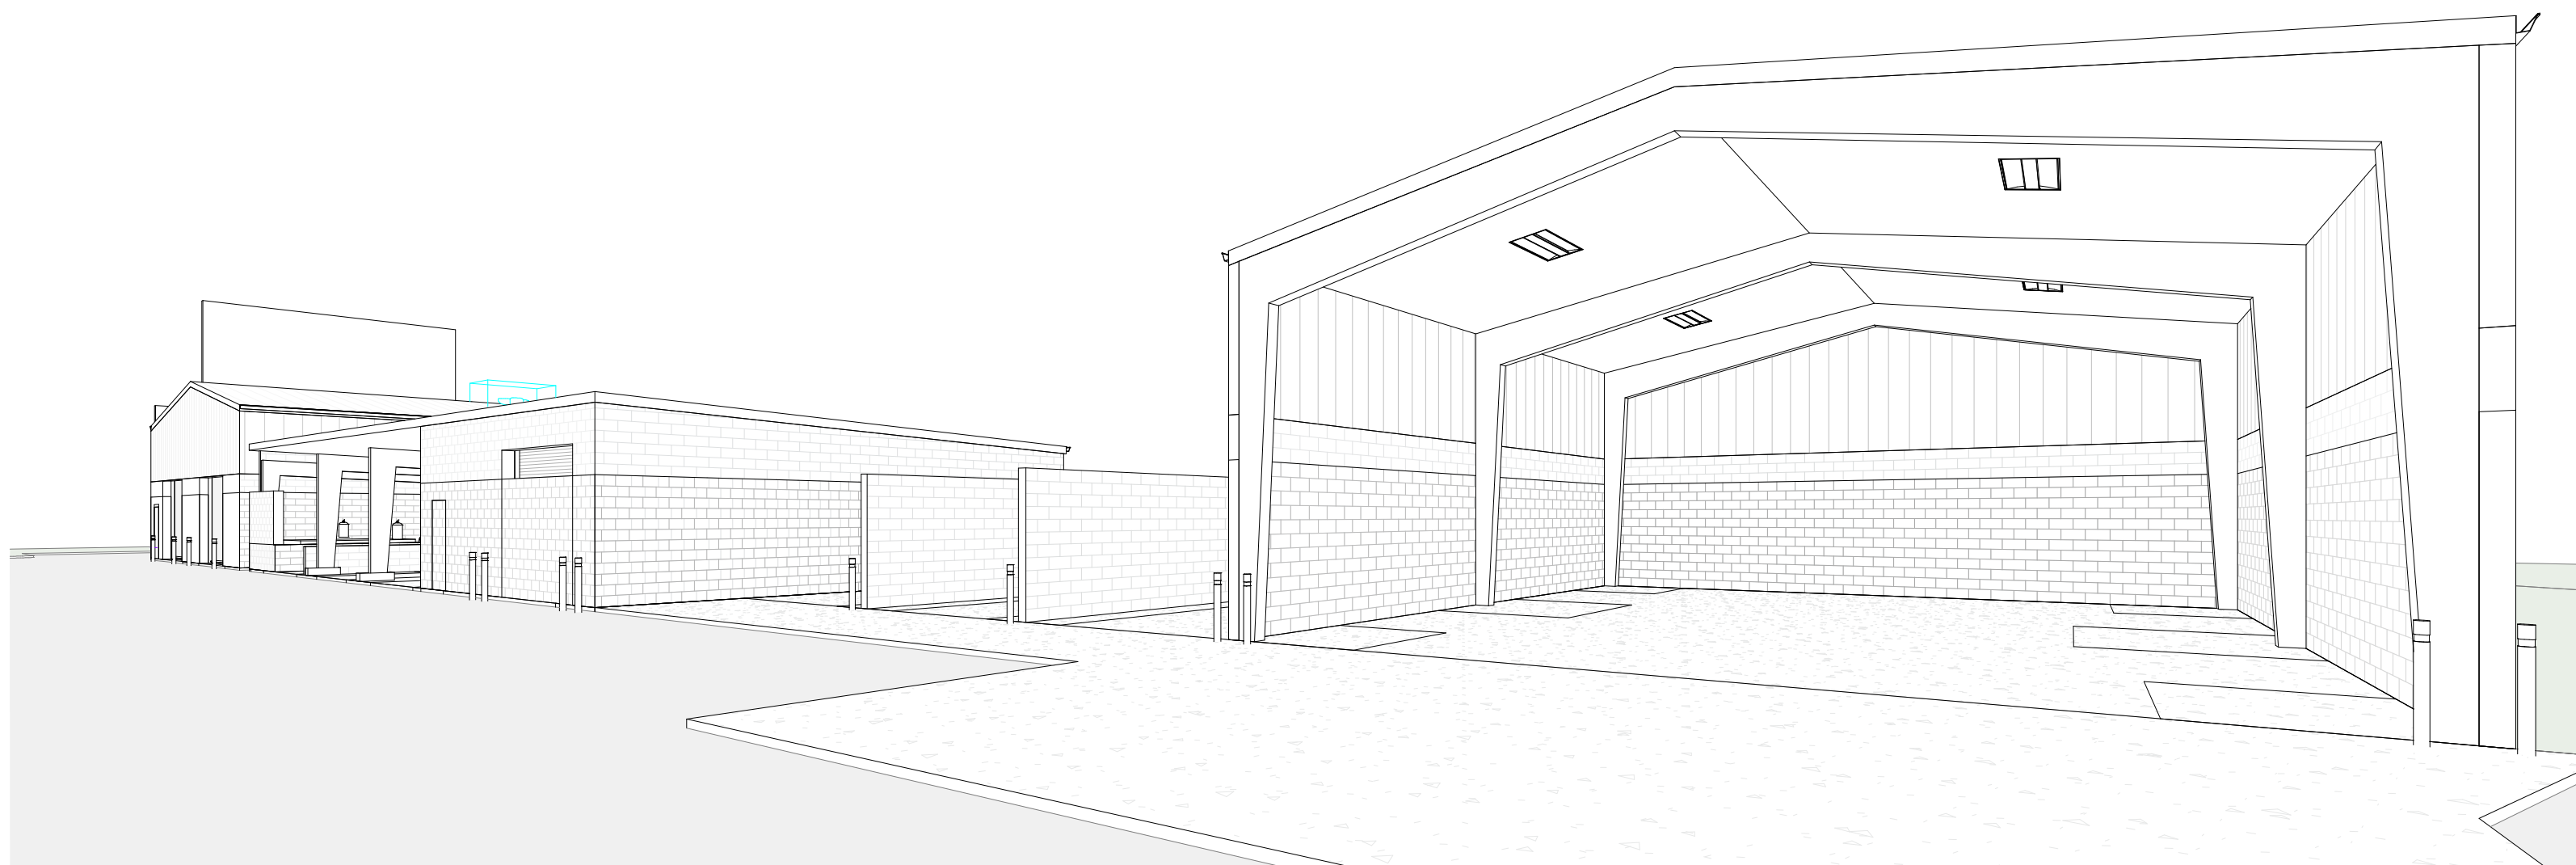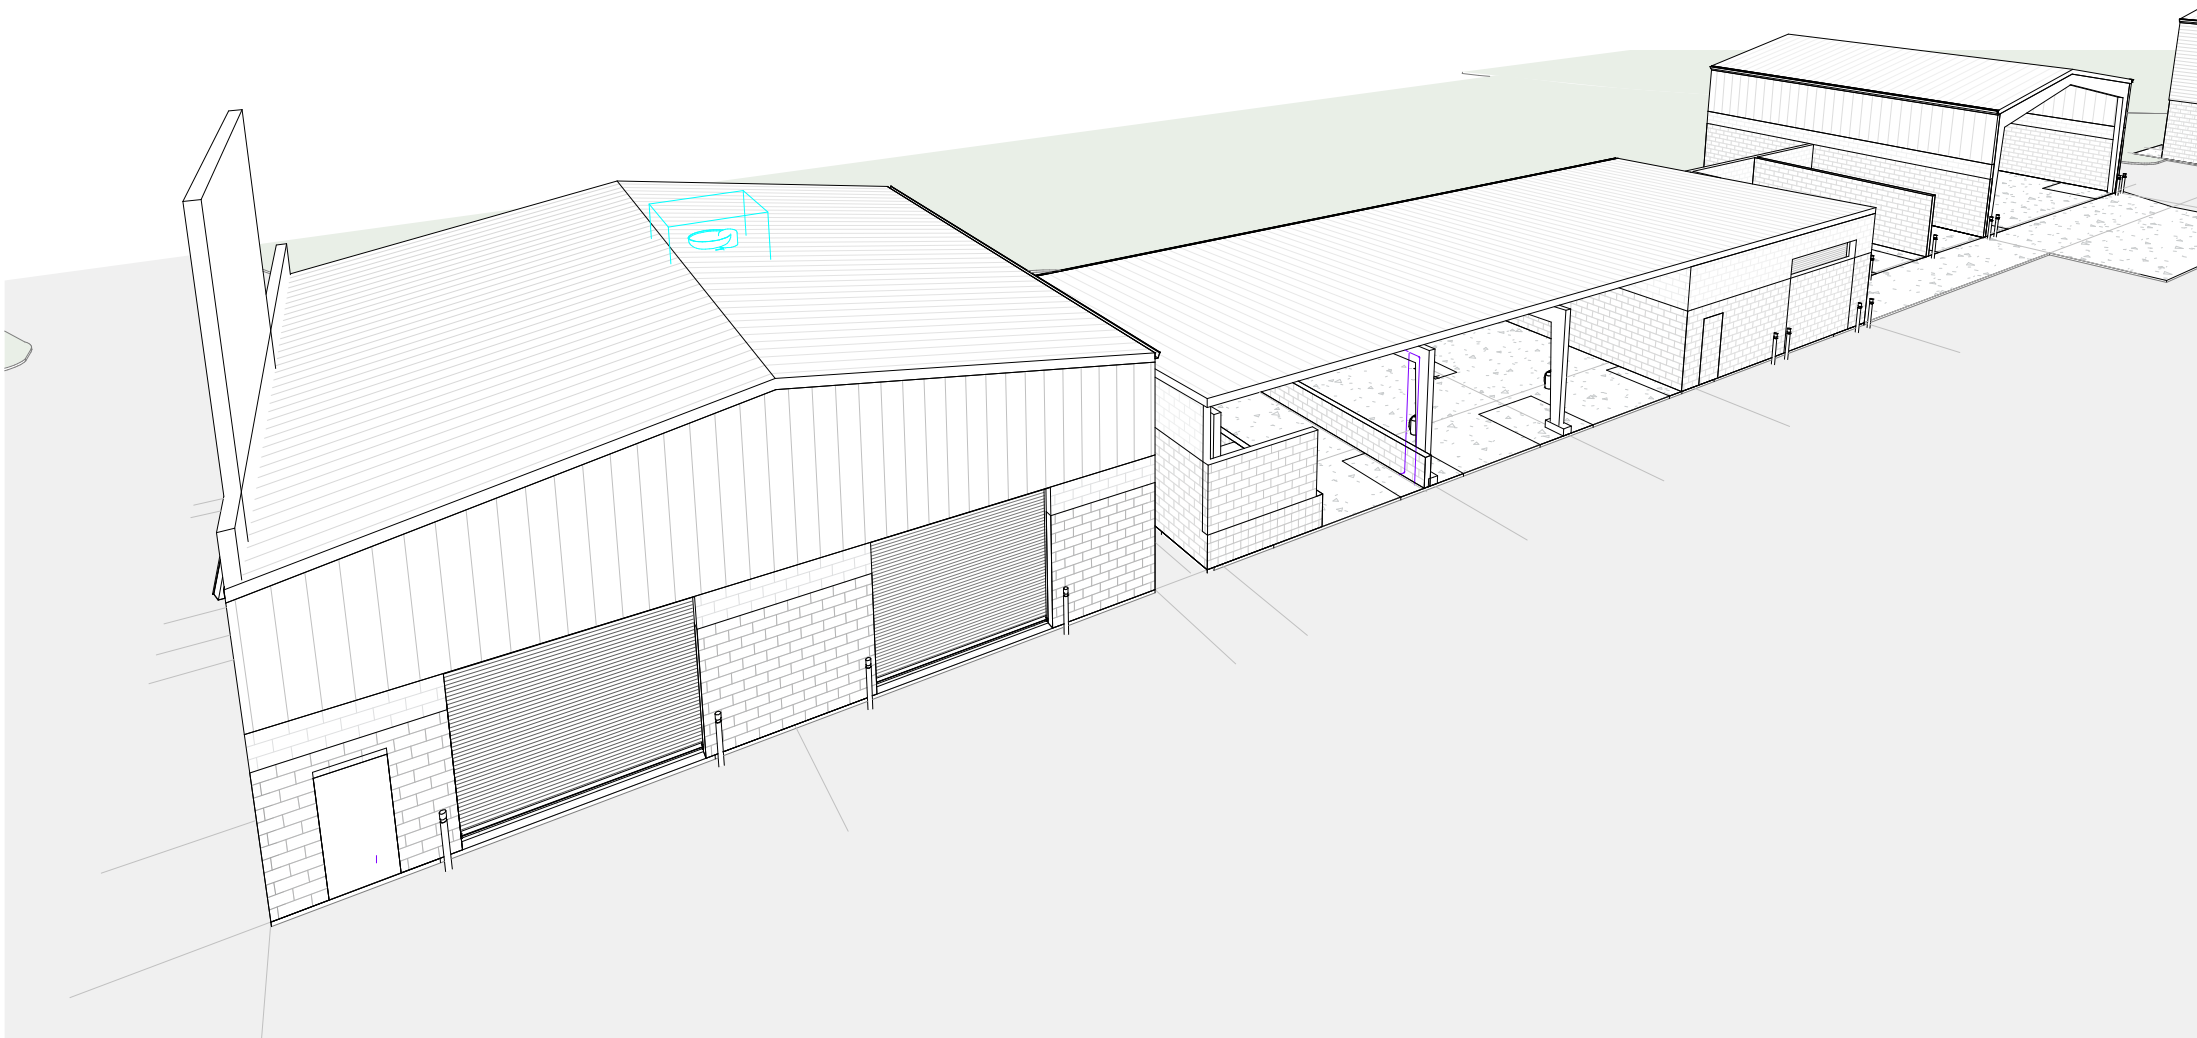


OLD MEMORIAL

13600 National Golf Dr
Tampa, FL 33626

no.	description	date
1	PERMIT SET	04.24.26

A2-104 ELEVATIONS

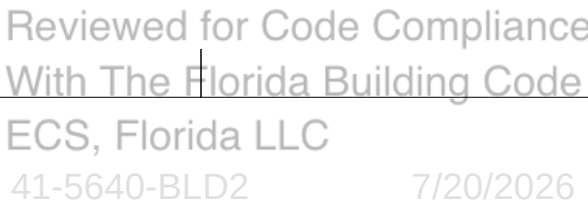

Reviewed for Code Compliance
With The Florida Building Code
ECS, Florida LLC
41-5640-BLD2 7/20/2026


Building Review - Roger Sanders PX651 - Reviewed - 7/14/2026

1. **FOUNDATIONS**
GEOTECHNICAL ENGINEER: VALLEYSHORE ENGINEERING
GEOLOGICAL REPORT TITLE: REPORT OF GEOTECHNICAL EXPLORATION, OLD MEMORIAL GOLF CLUB, 9602 SOUTH MOBLEY ROAD, TAMPA, FLORIDA 33556
JOB NUMBER: P26-0018-2
REPORT DATE: FEBRUARY 13, 2026
2. SHALLOW FOUNDATION ALLOWABLE BEARING PRESSURES:
STRIP FOUNDATIONS-----2000 PSF
SPREAD FOUNDATIONS-----2000 PSF
3. ALL FOUNDATION BEARING SURFACES SHALL BE INSPECTED AND APPROVED BY THE GEOTECHNICAL ENGINEER PRIOR TO PLACING CONCRETE TO ENSURE COMPLIANCE WITH NOTED PRESSURES.
4. FINAL BEARING ELEVATIONS MAY VARY AS REQUIRED TO PROVIDE PROPER BEARING CAPACITY IN AN APPROVED BEARING STRATUM AS DETERMINED BY THE GEOTECHNICAL ENGINEER.
5. FOOTINGS SHALL BE NEATLY EXCAVATED WHERE POSSIBLE AND FREE OF LOOSE OR WET MATERIALS. WHERE SOFT OR UNSUITABLE BEARING SURFACES ARE ENCOUNTERED, THE AREA SHALL BE UNDERCUT AND REPLACED WITH LEAN CONCRETE OR COMPACTED, DENSE GRADED STONE AS DIRECTED BY THE GEOTECHNICAL ENGINEER.
6. FOOTINGS SHALL BE PLACED THE SAME DAY AS INSPECTED BY THE GEOTECHNICAL ENGINEER UNLESS OTHERWISE DIRECTED BY THE GEOTECHNICAL ENGINEER.
7. COMPACTED FILL SHALL MEET THE REQUIREMENTS NOTED IN THE GEOLOGICAL REPORT. EXCAVATED MATERIAL MAY BE USED AS BACKFILL WITH WRITTEN APPROVAL FROM THE GEOTECHNICAL ENGINEER STATING THAT SUCH MATERIAL IS SUITABLE AS BACKFILL AND INSTRUCTIONS ARE GIVEN FOR PROPER MOISTURE CONTENT AND COMPACTION.
8. FOUNDATION AND RETAINING WALLS SHALL NOT BE BACKFILLED UNTIL CONCRETE HAS REACHED NOTED 28-DAY COMPRESSIVE STRENGTH.
9. PROVIDE 4" OF COMPACTED GRANULAR FILL BENEATH ALL SLABS ON GRADE. PROVIDE 10 MIL VAPOR RETARDER BETWEEN BOTTOM OF SLAB AND TOP OF GRANULAR FILL.
10. **CN. CONCRETE**
1. CONCRETING OPERATIONS SHALL COMPLY WITH ACI STANDARDS.
2. REINFORCING BARS USED IN CONCRETE SHALL MEET ASTM A615, GRADE 60.
3. WELDED WIRE REINFORCEMENT (WWR) USED IN CONCRETE SHALL MEET ASTM A185, MINIMUM LAB AND EMBEDMENT TO BE THE GREATER OF ONE CROSS WIRE SPACING + 2", OR 6".
4. REINFORCING BARS SHOWN IN SECTIONS AND DETAILS ARE A SCHEMATIC REPRESENTATION OF THE MEMBER REINFORCEMENT. SEE SCHEDULES, SECTION NOTES, AND GENERAL NOTES FOR ACTUAL REINFORCEMENT REQUIREMENT. DO NOT SCALE OFF OF SECTIONS.
5. DETAILING, FABRICATION, AND PLACEMENT OF REINFORCEMENT AND ANY ACCESSORIES SHALL BE IN ACCORDANCE WITH ACI 315, GUIDE TO PRESENTING REINFORCING STEEL DESIGN DETAILS. FABRICATION OF REINFORCEMENT STEEL CANNOT BEGIN TILL ENGINEER OF RECORD HAS REVIEWED AND APPROVED SHOP DRAWINGS. SEE SUBMITTAL SCHEDULE FOR SHOP DRAWING REQUIREMENTS.
6. SPLICES SHALL BE CLASS "B" TENSION LAP SPLICES UNLESS NOTED. REINFORCEMENT MARKED CONTINUOUS SHALL BE SPliced WITH A CLASS "B" TENSION LAP SPlice. BARS SHALL BE IN CONTACT WHEN MAKING A LAP SPlice UNLESS OTHERWISE NOTED.
7. DO NOT WELD REINFORCEMENT WITHOUT PRIOR APPROVAL FROM THE ENGINEER OF RECORD.
11. **SS. STRUCTURAL STEEL**
1. FABRICATE AND ERECT ALL STRUCTURAL STEEL IN ACCORDANCE WITH AISC "CODE OF STANDARD PRACTICE FOR STEEL BUILDINGS AND BRIDGES".
2. THE STEEL FRAME IS "NON-SELF-SUPPORTING". ADEQUATE TEMPORARY SUPPORT MUST BE PROVIDED BY THE CONTRACTOR TILL THE LATERAL FORCE RESISTING SYSTEM ELEMENTS AND STABILITY OF THE STRUCTURE IS IN PLACE.
3. STRUCTURAL STEEL AND STRUCTURAL STEEL CONNECTIONS MUST CONFORM TO THE FOLLOWING MINIMUM REQUIREMENTS, UNLESS NOTED ELSEWHERE IN THE DOCUMENTS.

WIDE FLANGE (W & WT) SHAPES, CHANNELS (C & MC)-----ASTM A992
ALL PLATES, ANGLES (L)-----ASTM A572, GR. 50
MISCELLANEOUS (M & MT), AMERICAN STANDARD (S & ST), AND WIDE
FLANGE BEARING PILES (HP) SHAPES-----ASTM A572, GR. 50
HOLLOW STRUCTURAL SECTION (HSS)-----ASTM A500, GR. C
STEEL PIPE-----ASTM A53, GR. B
HEADED STUDS-----ASTM A108
BOLTS-----ASTM F3125
NUTS-----ASTM A36
ANCHOR RODS-----ASTM F1554, GR. 36
THREADED ROD-----ASTM A36
WASHERS (FOR STRUCTURAL BOLTS)-----ASTM F436
WASHERS (FOR ANCHOR BOLTS)-----ASTM A36
WELDED CONNECTIONS-----E70XX ELECTRODES
4. BEAMS ARE TO BE SPACED EQUALLY IN BAYS, UNLESS DIMENSIONED ON PLAN.
5. BEAMS SHALL BE ERECTED WITH NATURAL CAMBER ORIENTED UPWARDS.
6. FABRICATE BRACING MEMBERS WITH SUFFICIENT DRAW TO PREVENT SAGGING.
7. HSS MEMBERS SHALL HAVE 1/4" CLOSURE PLATE.
8. GROUT UNDER BASE PLATES SHALL BE NON-SHRINK, NON-METALLIC TYPE. GROUT SHALL HAVE SPECIFIED DESIGN COMPRESSIVE STRENGTH TWO TIMES THAT OF THE SUPPORTING CONCRETE.
9. STRUCTURAL STEEL MEMBERS SHALL NOT BE CUT, SPliced, OR MODIFIED IN THE FIELD UNLESS NOTED ON THE STRUCTURAL DRAWINGS OR APPROVED BY THE STRUCTURAL ENGINEER OF RECORD.
10. STRUCTURAL STEEL NOT EXPOSED TO VIEW SHALL BE PRIMED WITH THE MANUFACTURER'S STANDARD SHOP PRIMER. STRUCTURAL STEEL EXPOSED TO WEATHER IN ITS FINAL POSITION SHALL BE HOT-DIPPED GALVANIZED IN ACCORDANCE WITH ASTM A123. STRUCTURAL STEEL EXPOSED TO VIEW, REFER TO PROJECT SPECIFICATIONS FOR FINISHED COATING SYSTEM.
11. CONNECTION WORK LINES SHOWN IN THE TYPICAL DETAILS ARE ALONG THE MEMBERS NEUTRAL AXIS UNLESS NOTED.
12. ALL WELD SHALL CONFORM TO THE AMERICAN WELDING SOCIETY STANDARDS AND MUST BE PERFORMED BY A CERTIFIED WELDER.
13. ALL WELD SIZES SHOWN IN THE DRAWINGS ARE CONSIDERED EFFECTIVE WELD SIZES.
14. ALL BOLTED CONNECTIONS SHALL BE BEARING TYPE CONNECTIONS.
15. ALTERNATE CONNECTION DETAILS FROM THOSE SHOWN IN THE TYPICAL DETAILS SHALL BE SUBMITTED BY THE CONTRACTOR TO THE ARCHITECT AND STRUCTURAL ENGINEER OF RECORD FOR APPROVAL.
16. ALL STRUCTURAL STEEL CONNECTIONS ARE TO BE DESIGNED UNDER DIRECT SUPERVISION OF A LICENSED PROFESSIONAL ENGINEER IN THE STATE IN WHICH THE PROJECT IS LOCATED.
17. DESIGN CALCULATIONS FOR THE CONNECTIONS SHALL BE SUBMITTED TO THE STRUCTURAL ENGINEER OF RECORD. CONNECTION CALCULATIONS IN THE CALCULATION PACKAGE SHALL BE REPRESENTATIVE OF THE CONNECTIONS DETAILED IN THE SHOP DRAWINGS. THE CALCULATIONS SHALL BE SIGNED AND SEALED BY A LICENSED PROFESSIONAL ENGINEER IN THE STATE IN WHICH THE PROJECT IS LOCATED.
18. SEE PLAN NOTES FOR BEAM REACTIONS.

- Roger Sanders PY651 - Reviewed - 7/14/2026			
& # % Ø °	AT NUMBER OR POUND PERCENT DIAMETER DEGREE		
		JT JST JG	JOINT JOIST JOIST
ASD	ALLOWABLE STRESS DESIGN	K	KIP (10
ACI	AMERICAN CONCRETE INSTITUTE	KSF	KIPS P
AISC	AMERICAN INSTITUTE OF STEEL CONSTRUCTION	KSI	KIPS P
AISI	AMERICAN IRON AND STEEL INSTITUTE	KLF	KIPS P
ASTM	AMERICAN SOCIETY FOR TESTING MATERIALS	LW	LIGHT
AWS	AMERICAN WELDING SOCIETY	LWC	LIGHT
AFF	ABOVE FINISH FLOOR	LRFD	LOAD
ARCH.	ARCHITECT OR ARCHITECTURAL	LLV	LONG
AESS	ARCHITECTURALLY EXPOSED STRUCTURAL STEEL	LLH	LONG
		LBS	POUND
		L	ANGLE
AHU	AIR HANDLING UNIT		
ALT	ALTERNATE	MTL	METAL
APPROX	APPROXIMATE	MIN	MINIM
APPRV	APPROVED	MAX	MAXIM
		MRF	MANUR
		M	MOME
B	BOTTOM	MECH	MECH
BRG	BEARING	MISC	MISCE
BOF	BOTTOM OF FOUNDATION		
BOT	BOTTOM	NWC	NOT IN
BLDG	BUILDING	NIC	NOT IN
BTWN	BETWEEN	NS	NS
CIP	CAST-IN-PLACE	NT.S	NOT TO
CONC	CONCRETE	OC	ON CE
CMU	CONCRETE MASONRY UNIT	OPNG	OPEN
CRSI	CONCRETE REINFORCING STEEL INSTITUTE	OPP	OPPOS
CONT	CONTINUOUS		
CJ	CONTROL JOINT	PC	PILE C
CLR	CLEAR	PL	PLATE
COL	COLUMN	PSF	POUND
C	CHANNEL	PSI	POUND
COMP	COMPRESSION	PCI	POUND
CONN	CONNECTION	PLBG	PLUME
CONTR	CONTRACTOR	PLF	POUND
		PT	POST-
DIA	DIAMETER		
DIM	DIMENSION	R	RADIU
DWLS	DOWELS	REINF	REINFO
DBL	DOUBLE		
DEG	DEGREE	SECT	SECTI
DP	DRILLED PIER	SC	SHEAR
		SHT	SHEET
EA	EACH	SLV	SHORT
EE	EACH END	SIM	SIMIL
EF	EACH FACE	SOG	SLAB
EJ	EXPANSION JOINT	STD	STAND
ES	EACH SIDE	STL	STEEL
EQ	EQUAL	SDI	STEEL
EXP	EXPANSION	SF	SQUAR
EW	EACH WAY	STIFF	STIFFE
EOD	EDGE OF DECK	SUP	SUPPO
EOS	EDGE OF SLAB	SYM	SYMM
ELEC	ELECTRICAL	STD	STAND
EMBED	EMBEDMENT		
ENGR	ENGINEER	T	TOP
		TO	TOP OF
FF	FINISH FACE	TOT	TOP OF
FTG	FOOT OR FEET	TOF	TOP OF
FTG	FOOTING	TOS	TOP OF
FDN	FOUNDATION	TOW	TOP OF
FV	FIELD VERIFY	TOPC	TOP OF
FS	FAR SIDE	TPC	TYPIC
		T	TENSIS
GALV	GALVANIZED		
GA	GAUGE	UNO	UNLES
GR	GRADE	US	UNDER
H. STUD	HEADED STUDS	WWR	WELDE
		W	WITH
IN	INCH	WP	WORK
INV	INVERT	W/O	WITHO
INFO	INFORMATION		

DER	
BS)	
SQUARE FOOT	
SQUARE INCH	
LINEAR FOOT	
IGHT	
IGHT CONCRETE	
RESISTANCE FACTOR DESIGN	
VERTICAL	
HORIZONTAL	
TURER	
CAL	
NEOUS	
WEIGHT CONCRETE	
TRACT	
SCALE	
R	
ER SQUARE FOOT	
ER SQUARE INCH	
ER CUPIC FOOT	
ER LINEAR FOOT	
SIONING	
ELEMENT	
NNECTOR	
G VERTICAL	
GRADE	
O	
CK INSTITUTE	
OOT	
R	
CAL	
O	
ONCRETE	
OTING	
EEL	
ALL	
LE CAP	
OTED OTHERWISE	
E	
WIRE REINFORCEMENT	
NT	

 

1030 arlington ave n, st petersburg fl 33705
(727) 490-9483
studio@lafatewilson.com

THE ARCHITECT'S COMMON LAW COPYRIGHT
AND OTHER PROPERTY RIGHTS ARE HEREBY
RESERVED IN THE IDEAS, DESIGNS, PLANS,
DRAWINGS, AND SPECIFICATIONS SHALL NOT
BE REPRODUCED OR CONVEYED IN ANY
MANNER NOR ASSIGNED TO ANY THIRD PARTY

13600 National Golf Dr
Tampa, FL 33626

[illegible]

S0-101
GENERAL NOTES

Flat Roof Pressures		
Area (sq.ft)	Max + Pressure (psf)	Max - Pressure (psf)
Interior Zone 1'		
10	16.0	-47.7
20	16.0	-44.5
50	16.0	-40.4
100	16.0	-37.2
200	16.0	-34.1
≥500	16.0	-29.9
Perimeter Zone 2		
10	16.0	-62.9
20	16.0	-58.9
50	16.0	-53.5
100	16.0	-49.5
200	16.0	-45.4
≥500	16.0	-40.1
Corner Zone 3		
10	16.0	-85.7
20	16.0	-77.6
50	16.0	-66.9
100	16.0	-58.9
200	16.0	-50.8
≥500	16.0	-40.1

1 Flat Roof Components and Cladding Wind Pressures
3/4" = 1'-0"


Gable/Hip Roof Pressures		
Area (sq.ft)	Max + Pressure (psf)	Max - Pressure (psf)
Interior Zone 1		
10	24.2	-67.7
20	22.1	-58.2
50	19.2	-45.7
100	17.1	-36.2
200	16.0	-26.7
≥500	16.0	-21.1
Perimeter Zone 2		
10	24.2	-89.4
20	22.1	-77.2
50	19.2	-61.1
100	17.1	-48.9
200	16.0	-36.6
≥500	16.0	-36.6
Corner Zone 3		
10	24.2	-117.4
20	22.1	-100.6
50	19.2	-78.3
100	17.1	-61.5
200	16.0	-61.5
≥500	16.0	-61.5

2 Gable/Hip Roof Components and Cladding Wind Pressures
3/4" = 1'-0"

Wall Pressures		
Area (sq.ft)	Max + Pressure (psf)	Max - Pressure (psf)
Interior Zone 4		
10	36.6	-39.8
20	35.0	-38.1
50	32.8	-35.9
100	31.2	-34.3
200	29.5	-32.6
≥500	27.3	-30.4
Corner Zone 5		
10	36.6	-49.1
20	35.0	-45.8
50	32.8	-41.4
100	31.2	-38.1
200	29.5	-34.8
≥500	27.3	-30.4


3 Wall Components and Cladding Wind Pressures
3/4" = 1'-0"

Structural Submittal Schedule					
Submittal Type	Description	For Approval	For Record	Signed & Sealed Shop Dwgs	Signed & Sealed Calcs
31600 FOUNDATIONS					
MILD REINFORCEMENT		X			
33000 STRUCTURAL CONCRETE					
CONCRETE MIX DESIGN	SUBMIT MIX DESIGN FOR EACH CONCRETE MIX DESIGN. NOTE THE USAGE FOR EACH PROVIDED DESIGN. PROVIDE MIX RECIPE, BREAK DATE, AND PRODUCT DATA AS REQUIRED BY ACI 301.	X			
CONCRETE ACCESSORIES	VAPOR BARRIER, REBAR CHAIRS, ETC.	X			
WELDED WIRE REINFORCEMENT		X			
MILD REINFORCEMENT		X			
CONCRETE FORMWORK			X		
EMBEDDED ITEMS	EMBED PLATES, BEARING PLATES, ETC.	X			
42000 CONCRETE MASONRY UNITS (CMU)					
MASONRY PRODUCT INFORMATION		X			
MILD REINFORCEMENT	VERTICAL REINF. BOND BEAM REINF. LITEL REINF. BENT BAR SCHEDULE	X			
GROUT MIX DESIGNS	MIX DESIGN AND BREAK DATA	X			
MORTAR MIX DESIGNS		X			
MASONRY ACCESSORIES	BAR SPASCERS, HORIZONTAL JOINT REINF. ETC.		X		
PRECAST LINTEL DATA		X			
51200 STRUCTURAL STEEL					
STRUCTURAL STEEL		X		X	
STEEL CONNECTION CALCULATIONS	BEAM-BEAM CONNECTIONS, VERTICAL BRACING, MOMENT CONNECTIONS, ETC.	X			X
STEEL STAIRS		X		X	
STEEL STAIR CALCULATIONS	STAIR MEMBERS AND THEIR CONNECTIONS TO EACHOTHER/TO THE STRUCTURE	X			X
STEEL HANDRAILS		X		X	X
53100 STEEL DECK					
STEEL DECK	SUBMIT PLANS SHOWING SPANS, DECK SIZE, AND MATERIAL FOR EACH ROOF AND/OR DECK TYPE.	X			
DECK ATTACHMENT		X			
133419 METAL BUILDING SYSTEMS					
ERECTION DRAWINGS	SIZE, LAYOUT, AND ORIENTATION OF COLUMNS. ANCHOR BOLT DIAMETER AND LAYOUT IN BASE PLATE.	X		X	
CALCULATIONS	LIST LOADS USED IN DESIGN. LIST FINAL COLUMN REACTIONS.	X			X

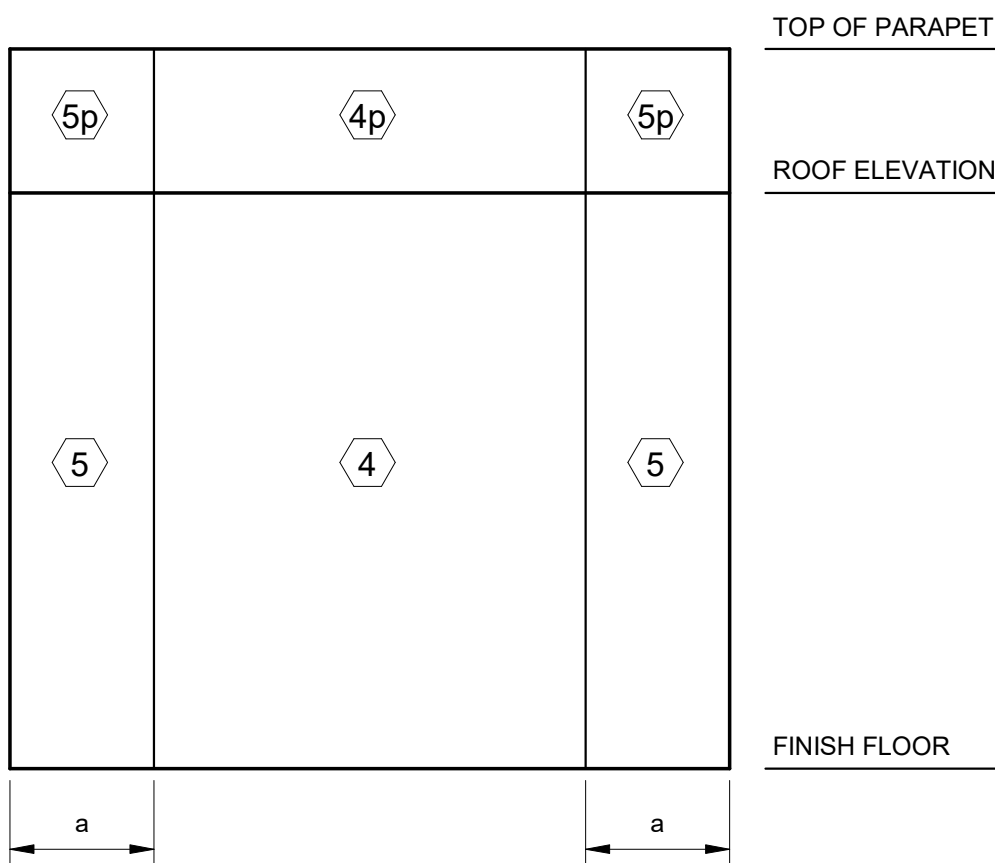


4 Wall Components and Cladding Wind Zones
3/4" = 1'-0"

a = 5' - 0"
b = 3' - 2"
c = 7' - 2"

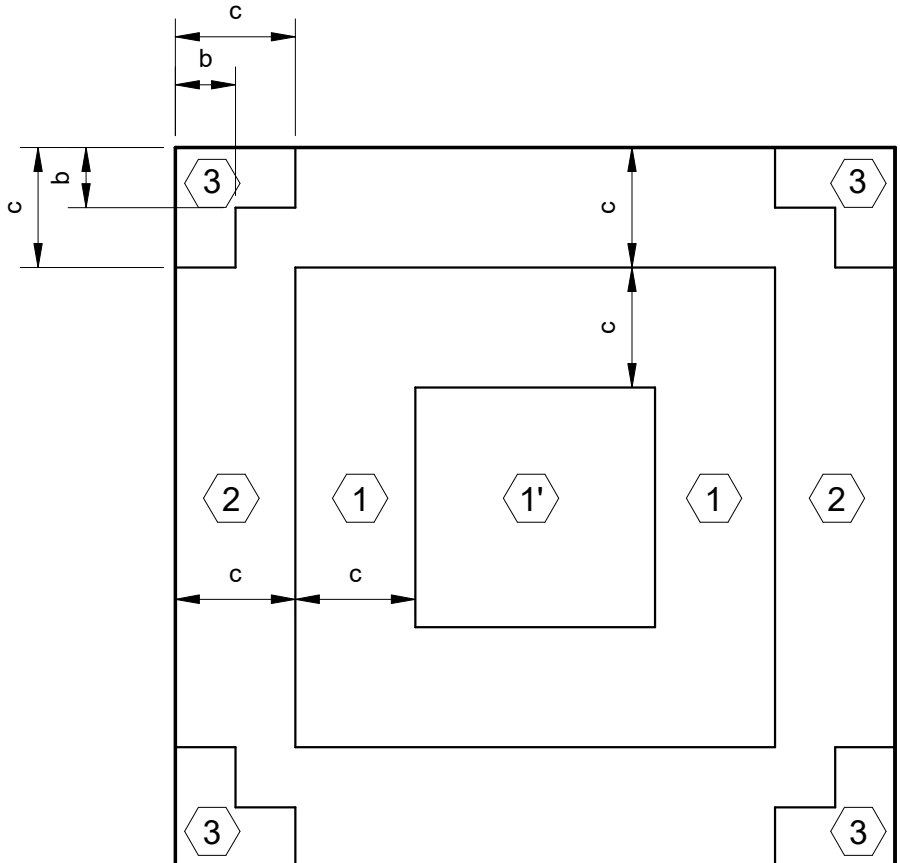

5 Flat Components and Cladding Wind Zones
3/4" = 1'-0"

a = 5' - 0"
b = 3' - 2"
c = 7' - 2"

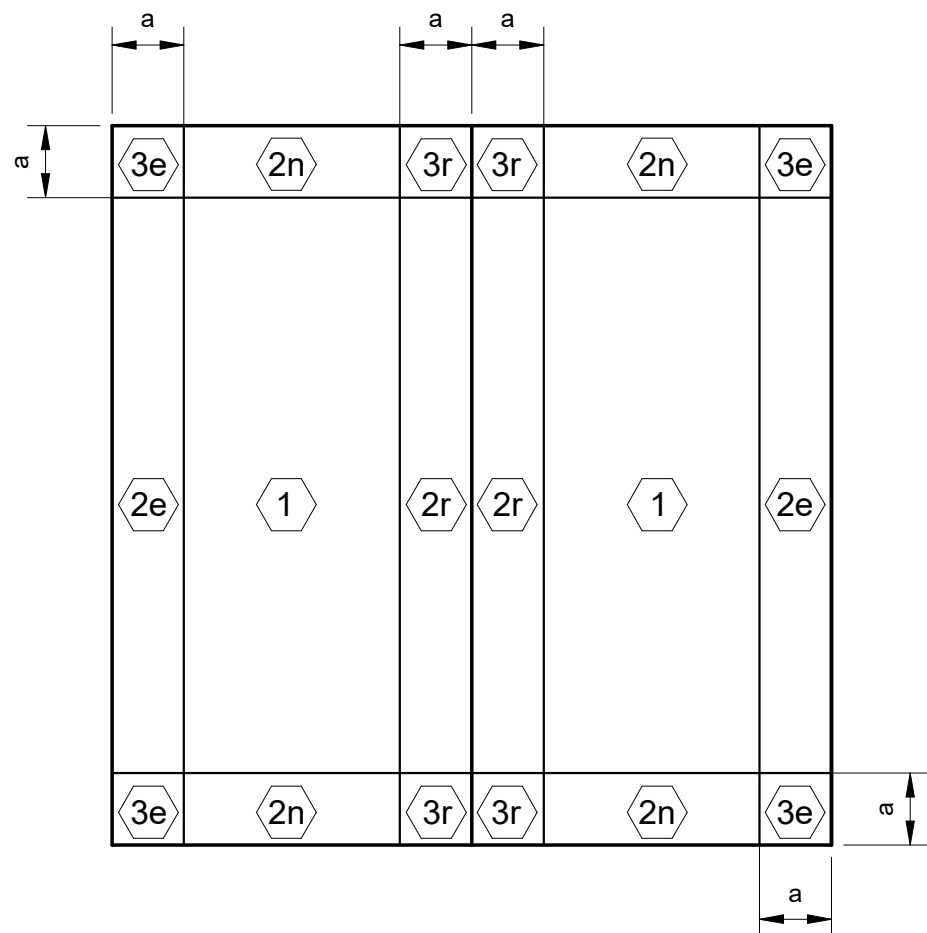

6 Gable Roof (7°<Θ≤20°) Components and Cladding Wind Zones
3/4" = 1'-0"

a = 5' - 0"
b = 3' - 2"
c = 7' - 2"




OLD MEMORIAL

13600 National Golf Dr
Tampa, FL 33626

no.	description	date
	PERMIT SET	4.24.26

S0-102

COMPONENTS AND
CLADDING SHEET

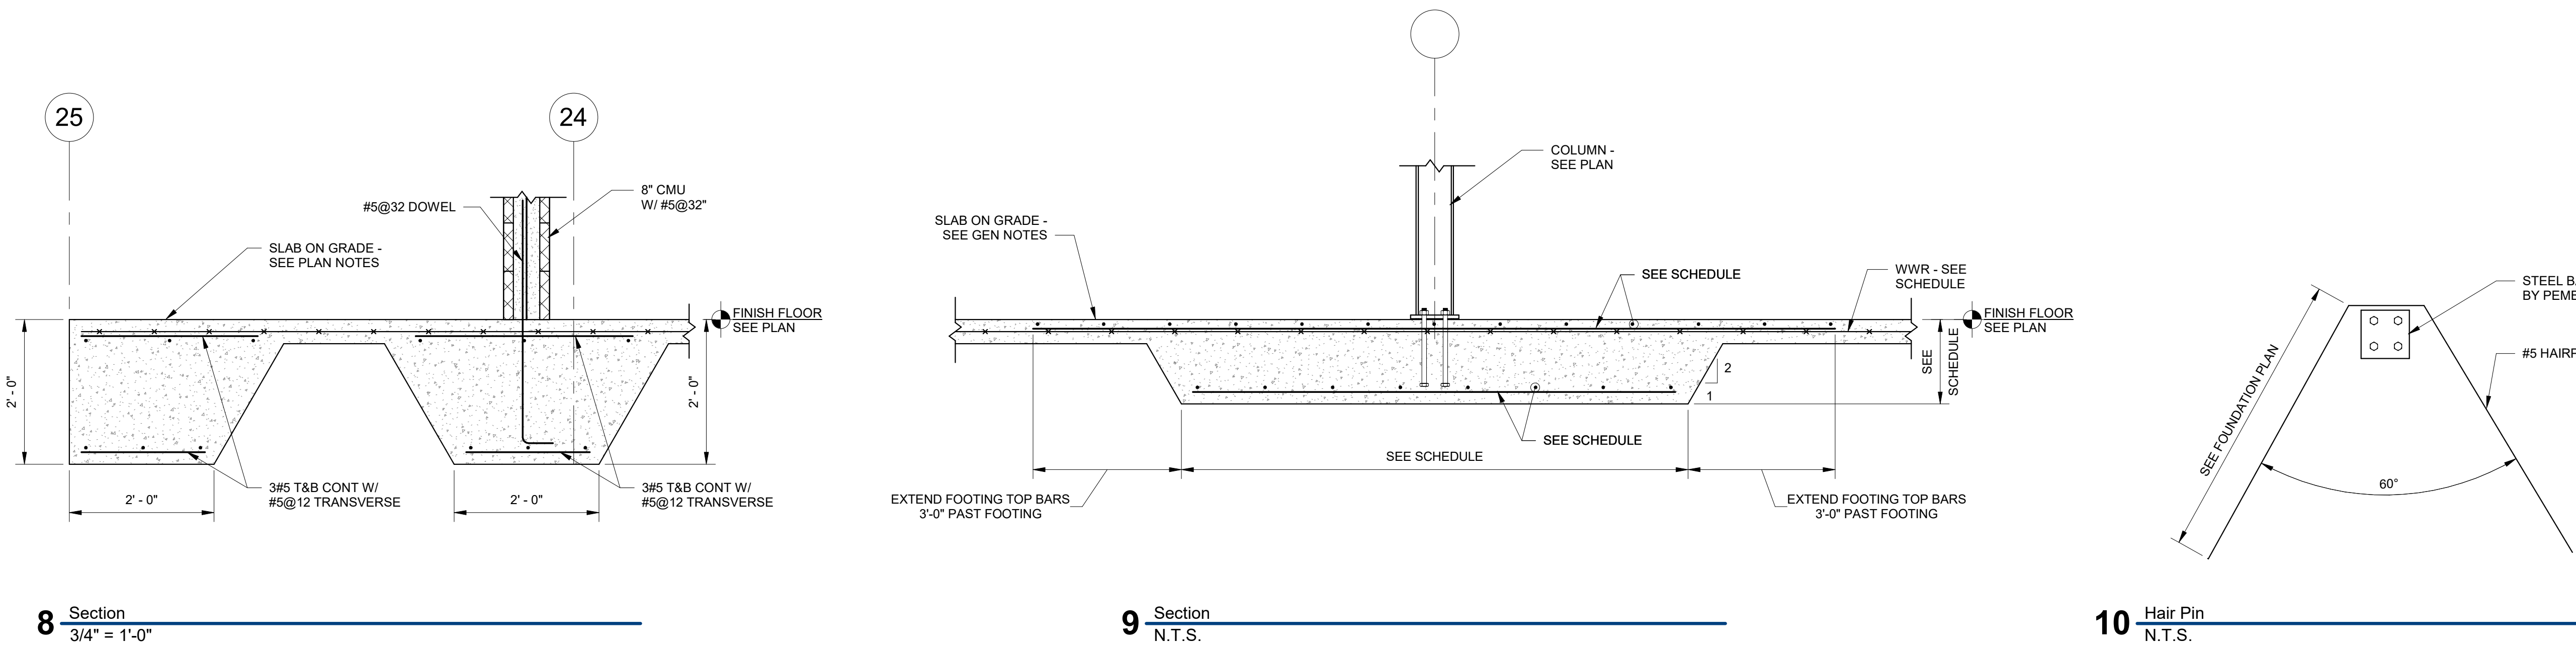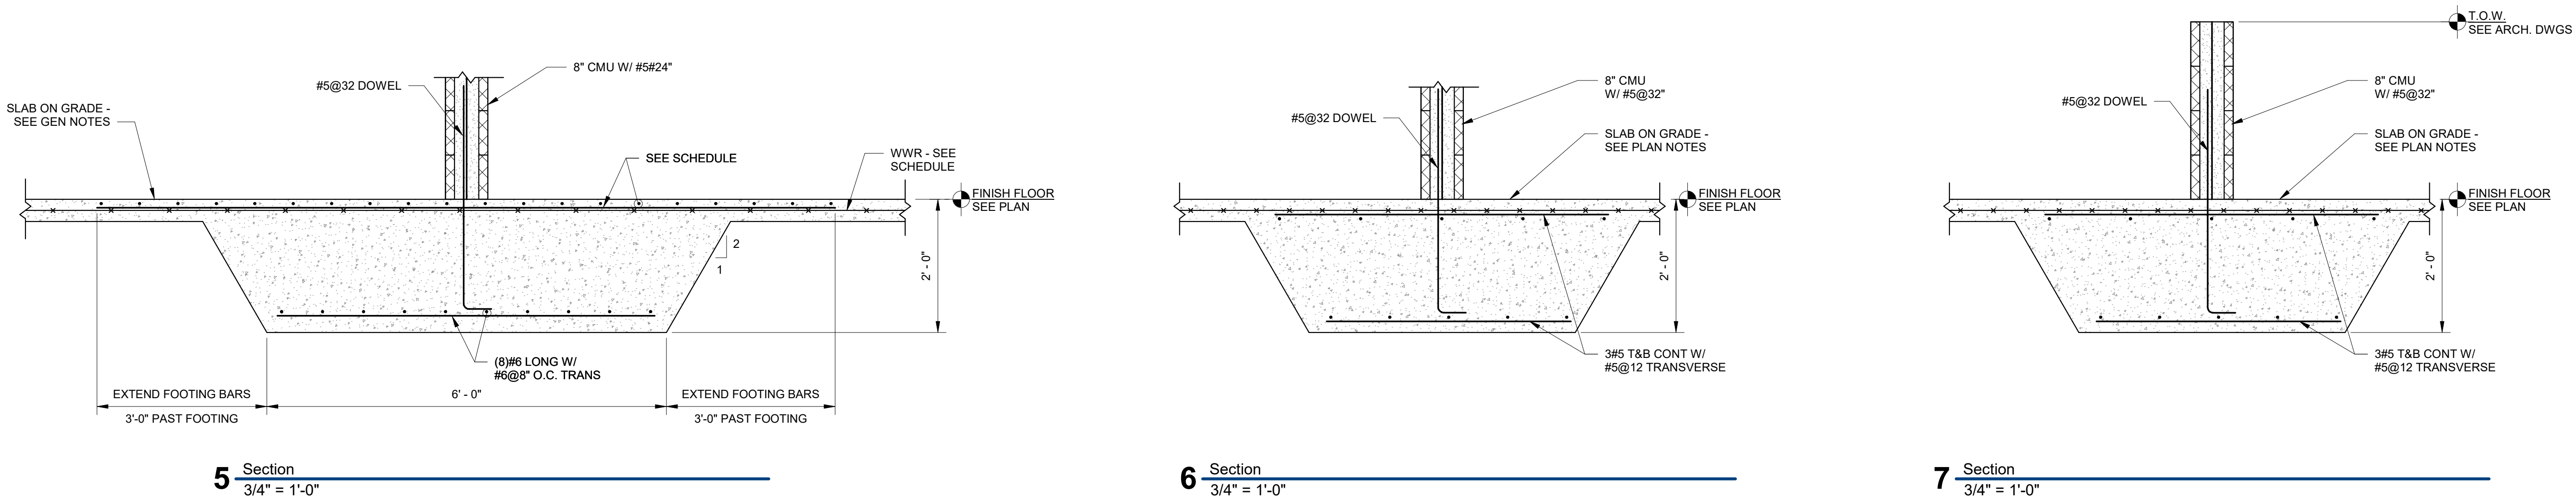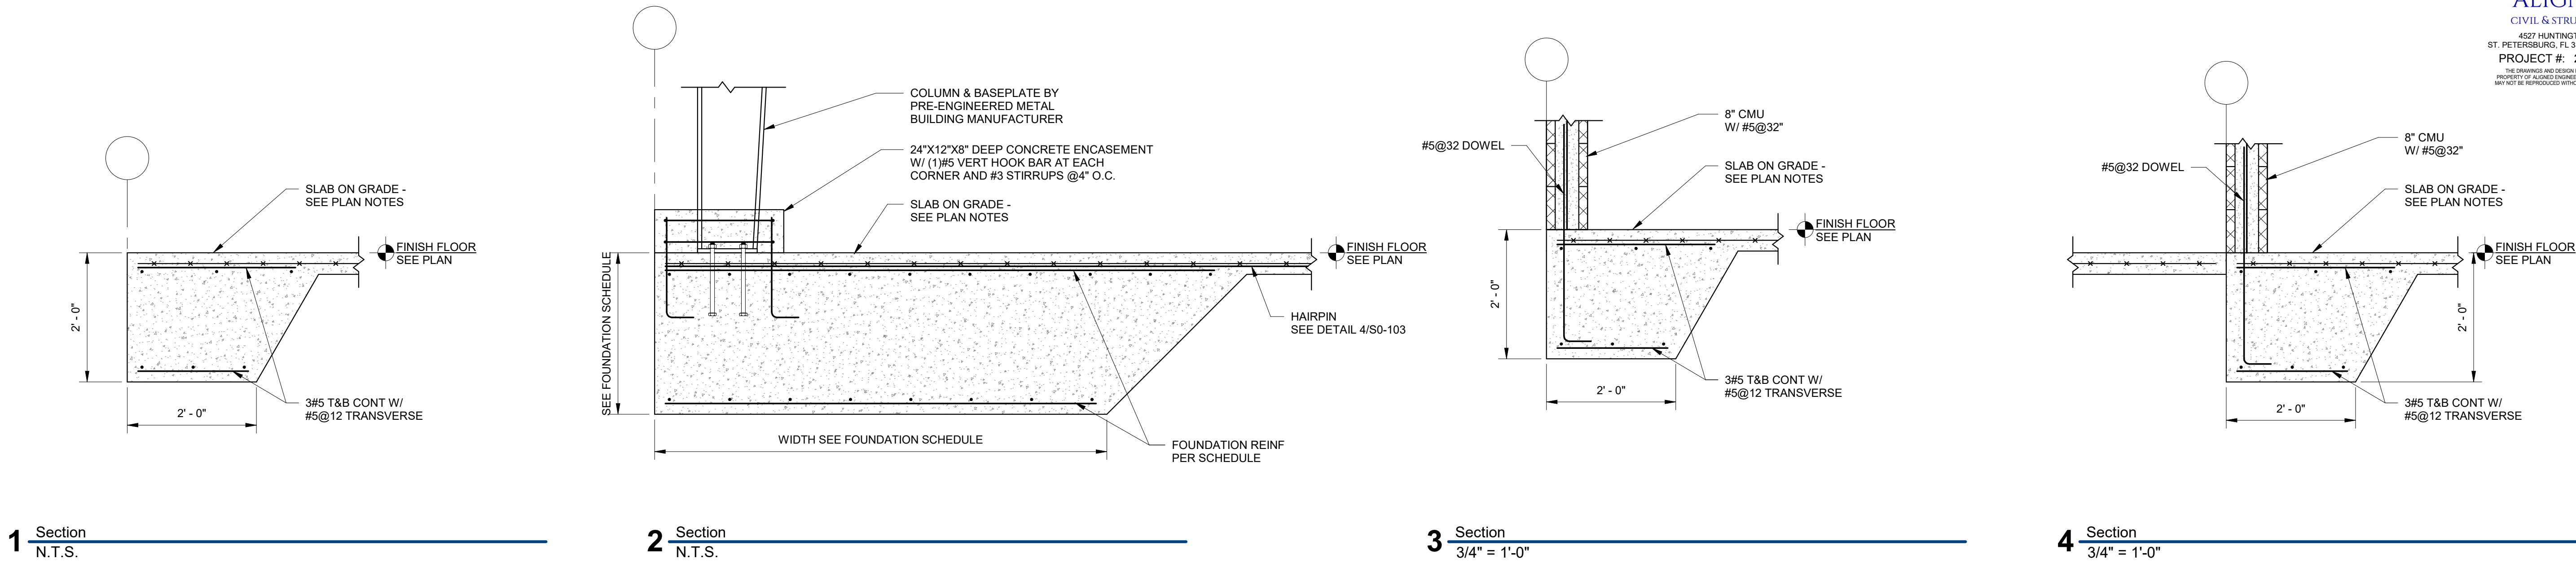

OLD MEMORIAL

13600 National Golf Dr
Tampa, FL 33626

no.	description	date
	PERMIT SET	4.24.26

S0-103
TYPICAL DETAILS



Concrete Tension Lap Splice Lengths								
Bar Size	f _c = 3000 PSI				f _c = 4000 PSI			
	Top Bars		Bottom Bars		Top Bars		Bottom Bars	
	A	B	A	B	A	B	A	B
#3	22"	29"	17"	23"	19"	25"	15"	20"
#4	29"	38"	22"	29"	25"	33"	19"	25"
#5	36"	47"	28"	37"	31"	41"	24"	32"
#6	43"	56"	33"	43"	37"	49"	29"	38"
#7	63"	82"	48"	63"	54"	71"	42"	55"
#8	72"	94"	55"	72"	62"	81"	48"	63"
#9	81"	106"	62"	81"	70"	91"	54"	71"
#10	91"	119"	70"	91"	79"	103"	61"	80"
#11	101"	132"	78"	102"	87"	114"	67"	88"
#14	121"	158"	93"	121"	105"	137"	81"	106"

1. TABULATED TENSION LAP SPICE LENGTHS ARE FOR NORMAL WEIGHT CONCRETE ONLY AND HAVE NOT BEEN FACTORED FOR EPOXY-COATED BARS.
2. ALL LENGTHS ARE IN INCHES (IN)
3. TABULATED VALUES ARE CALCULATED PER ACI 318-14, CHAPTER 25.
4. WHEN LAP SPICING BARS OF DIFFERENT SIZES, THE LAP LENGTH IS DETERMINED BY THE LARGER BAR.
5. TOP BARS ARE HORIZONTAL REINFORCEMENT WITH MORE THAN 12" CONCRETE CAST BELOW REINFORCEMENT.
6. TABLE SHALL APPLY ONLY WHEN ACI 318 MINIMUM COVER IS PROVIDED AND THE CENTER-TO-CENTER SPACING IS ≥ 3db

1

Tension Lap Splice Lengths by Concrete Compression Strength

3/4" = 1'-0"

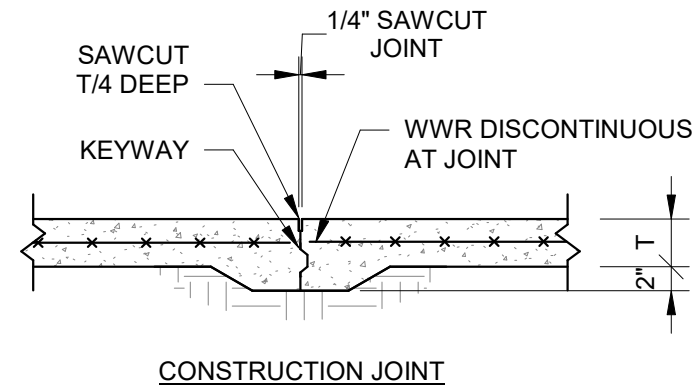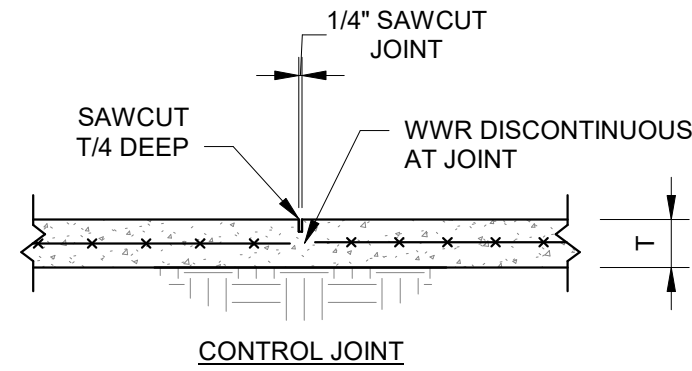

CONTROL/CONSTRUCTION JOINT NOTES:

1. CUT JOINTS AS SOON AS SLAB IS ABLE TO SUPPORT WEIGHT OF WORKERS AND EQUIPMENT. APPROXIMATELY 4 TO 8 HOURS AFTER CONCRETE PLACEMENT.
2. CLEAN JOINT PRIOR TO FILLING WITH SEMI-RIGID EPOXY
3. CUT JOINTS AROUND COLUMNS AS SHOWN IN COLUMN ISOLATION DETAIL.
4. FOR LAYOUT OF CONTROL JOINTS, SEE FOUNDATION AND FIRST FLOOR PLAN. IF NO CONTROL JOINTS ARE SHOWN ON PLAN, CONTACT ENGINEER OF RECORD.
5. SEE PLANS AND DETAILS FOR SLAB THICKNESS.
6. CONTRACTOR TO COORDINATE TILE JOINT LOCATIONS WITH CONTROL JOINTS.
7. SEE TYPICAL DETAILS FOR CONCRETE STRENGTH AND WELDED WIRE REINFORCEMENT REQUIREMENTS.

4

Slab on Grade Control Joints

3/4" = 1'-0"


Concrete Compressive Strengths		
Structural Element	Exposure Class	Design Strength, f _c (PSI)
Foundations and Stem Walls	C1	3000
Slab on Grade	C1	3000
Concrete on Metal Deck	W0	3500
Columns	W0	5000
Walls	W0	5000
Beams	W0	5000
Elevated Slabs	W0	5000

1. NOTED EXPOSURE CLASSES ARE IN REFERENCE TO CHAPTER 19 OF ACI 318-14. MINIMUM AND MAXIMUM REQUIREMENTS BASED ON TABLE 19.3.2.1.
2. CONCRETE COMPRESSIVE STRENGTHS NOTED ARE MINIMUM REQUIREMENTS USED IN DESIGN.


2

Concrete Compressive Strengths


3/4" = 1'-0"

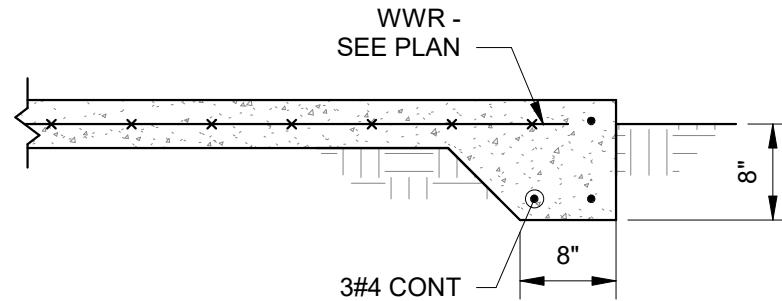


SLAB EDGE

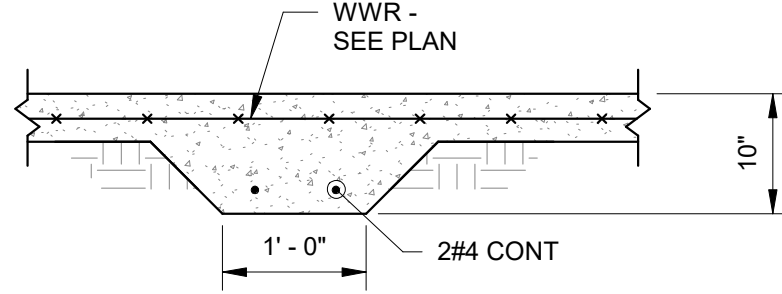

THICKENED SLAB

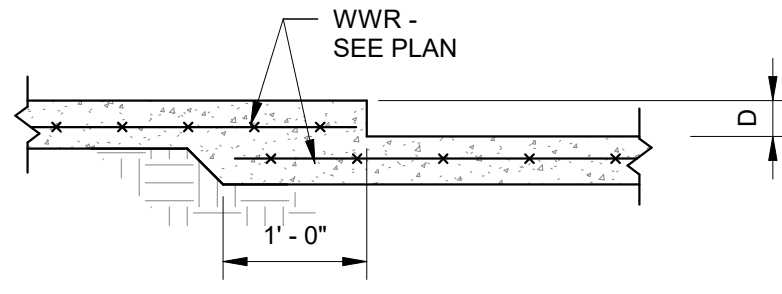

SLAB DEPRESSION D ≤ 3"

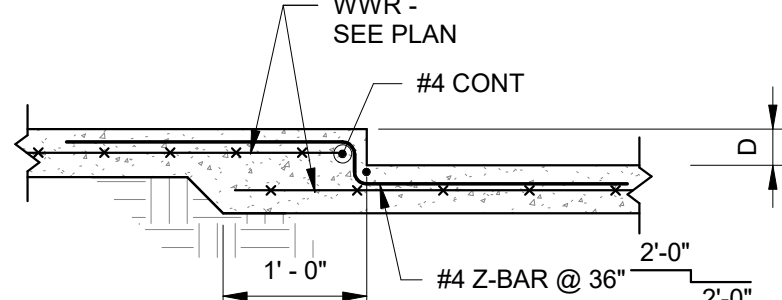

SLAB DEPRESSION 3' < D ≤ 12"

5

Slab on Grade Details

3/4" = 1'-0"

Concrete Cover Requirements		
Structural Element	Reinforcement	Cover (in)
Members Not Exposed to Weather or in Contact With Ground		
Slabs	All	3/4"
Joists	All	3/4"
Walls	All	3/4"
Beams	To Stirrups	1 1/2"
Columns	To Stirrups	1 1/2"
Members Exposed to Weather or in Contact With Ground		
Slabs	#5 or Smaller	1 1/2"
	#6 or Larger	2"
Columns/Pedestals	#5 or Smaller	1 1/2"
	#6 or Larger	2"
Walls	#5 or Smaller	1 1/2"
	#6 or Larger	2"
Slab on Grade	WWR	2" From Top
Foundations and Grade Beams	Bottom/Side	3"
	Top	2"

3

Concrete Cover Requirements

3/4" = 1'-0"





OLD MEMORIAL

13600 National Golf Dr
Tampa, FL 33626


no.	description	date
	PERMIT SET	4.24.26

S0-104

TYPICAL DETAILS

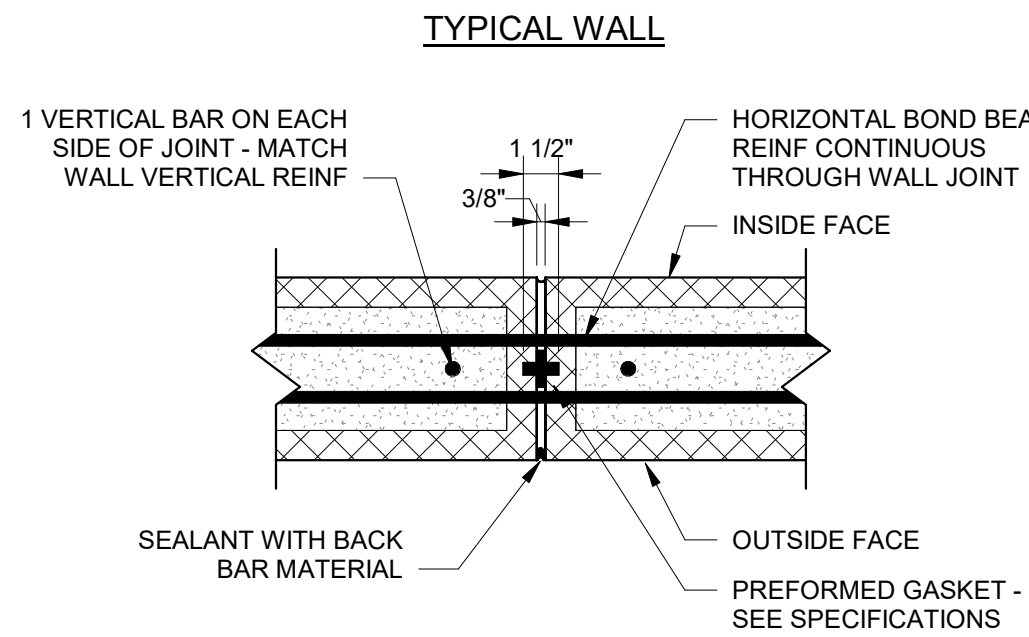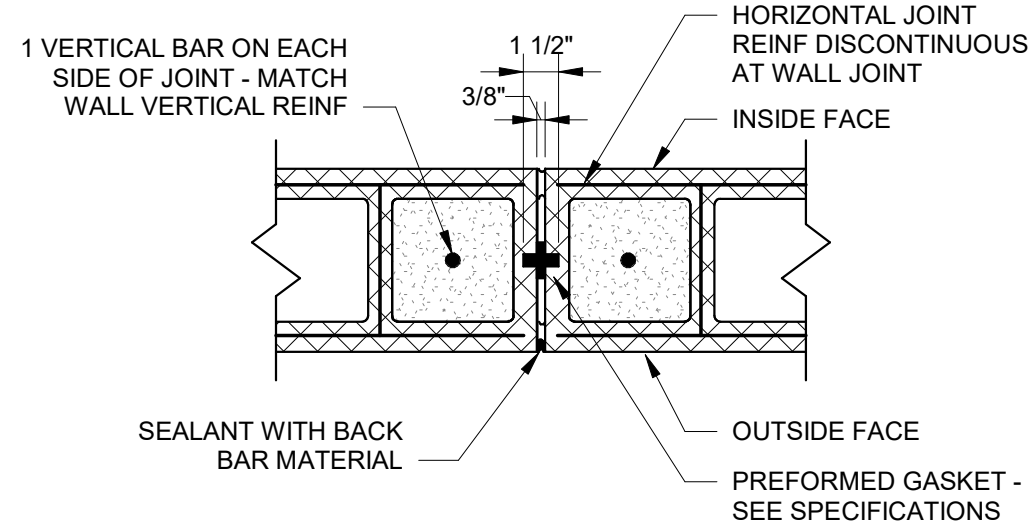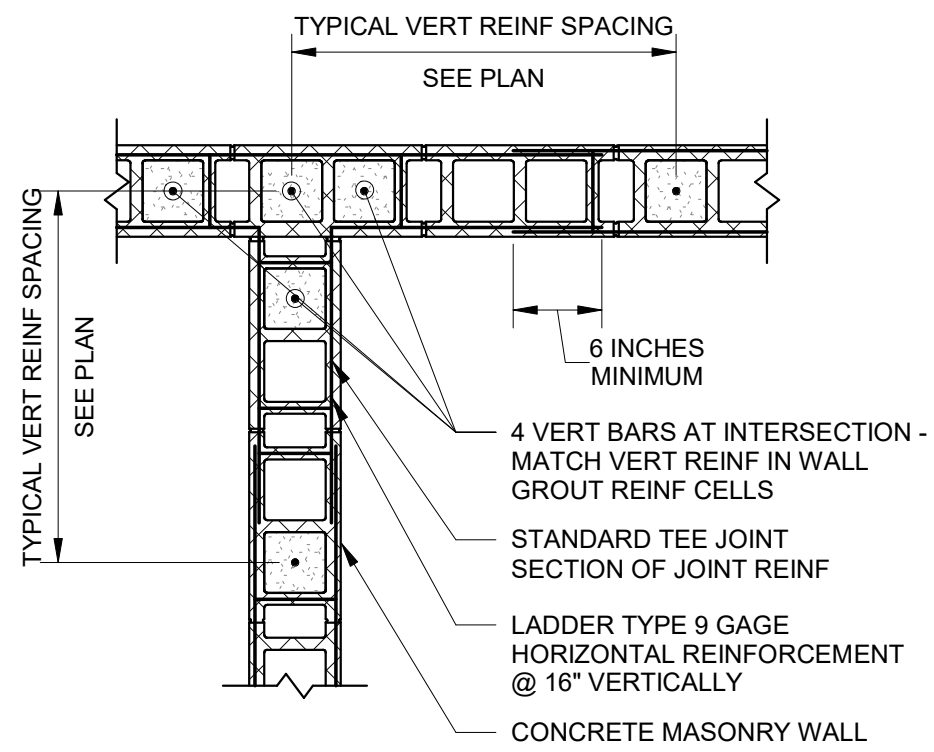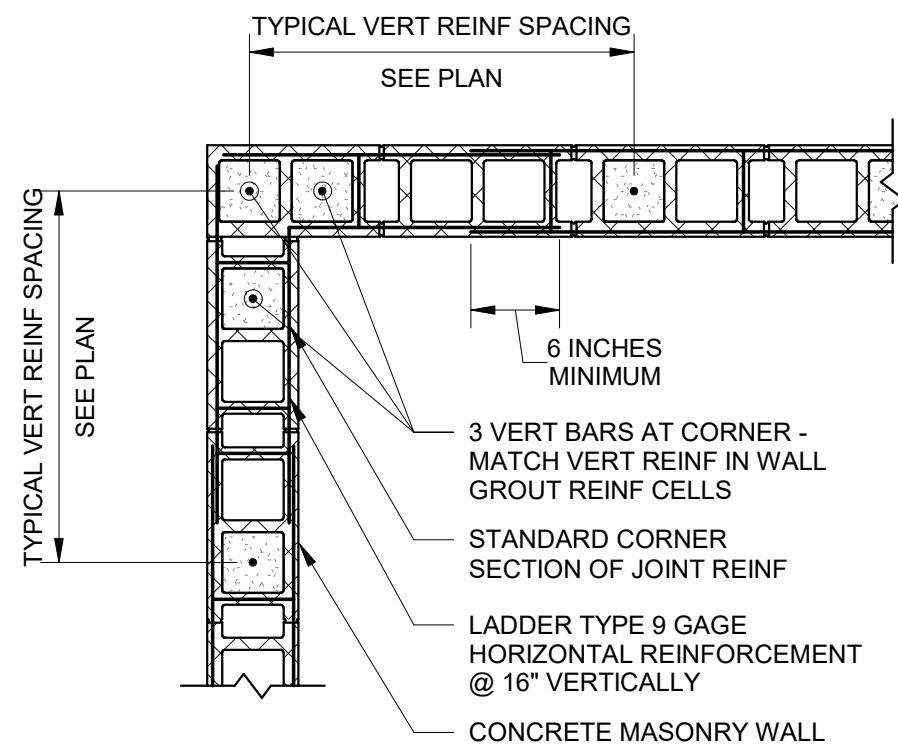


- CONTROL JOINT NOTES:
- DO NOT PLACE CONTROL JOINTS WITHIN 5 FEET OF WALL CORNER.
 - DO NOT PLACE CONTROL JOINTS WITHIN DOORS, WINDOWS, OR THEIR JAMBS.
 - SPACE CONTROL JOINTS AT A MAXIMUM OF 25 FT.
 - COORDINATE CONTROL JOINT LOCATIONS WITH ARCHITECTURAL VENEER JOINT LOCATIONS. CONTACT STRUCTURAL ENGINEER OF RECORD IF ARCHITECTURAL CONTROL JOINTS ARE WITHIN AREAS NOTED ABOVE.

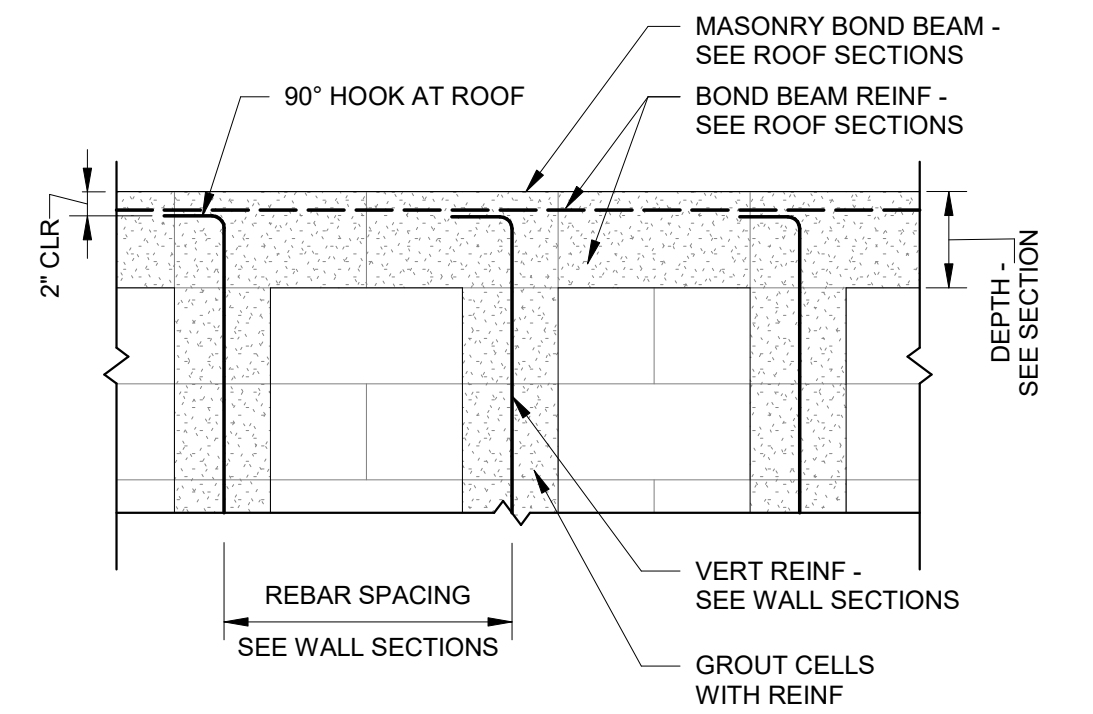


1 Plan View of Joint Reinforcement in Masonry Wall Joints
3/4" = 1'-0"

2 Masonry Wall Control Joint
1 1/2" = 1'-0"


3 Top of Wall Reinforcement Detail
3/4" = 1'-0"

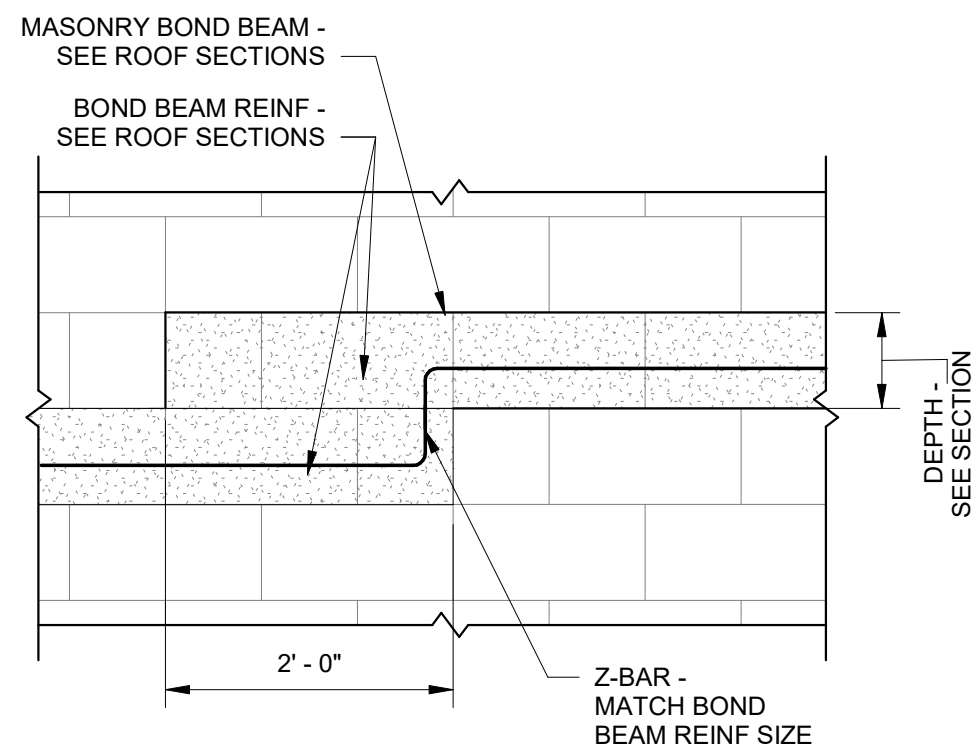


4 Stepped Bond Beam Detail
3/4" = 1'-0"

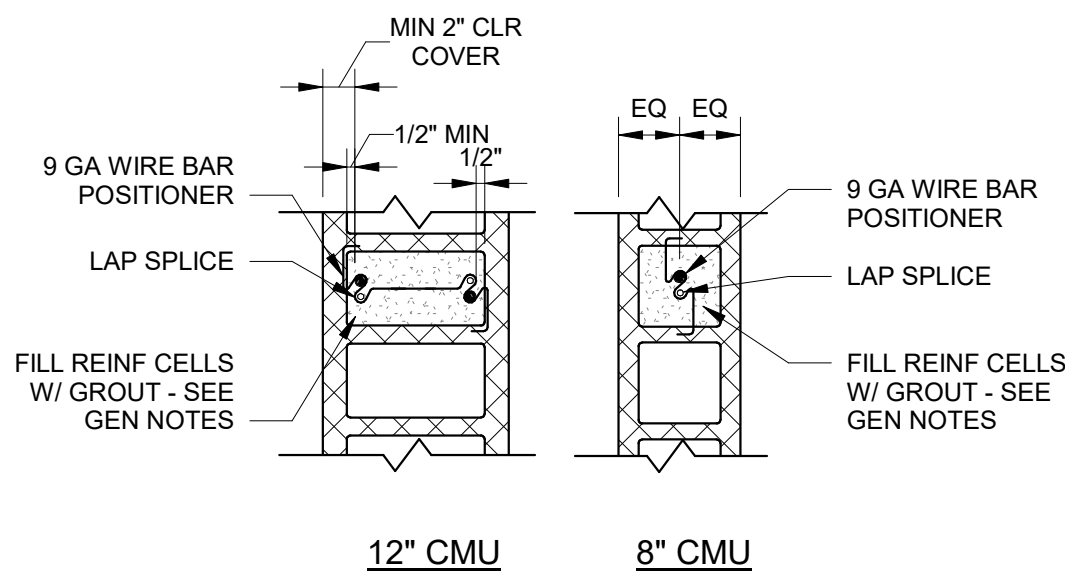

5 Vertical Wall Reinforcement Location Details
1" = 1'-0"

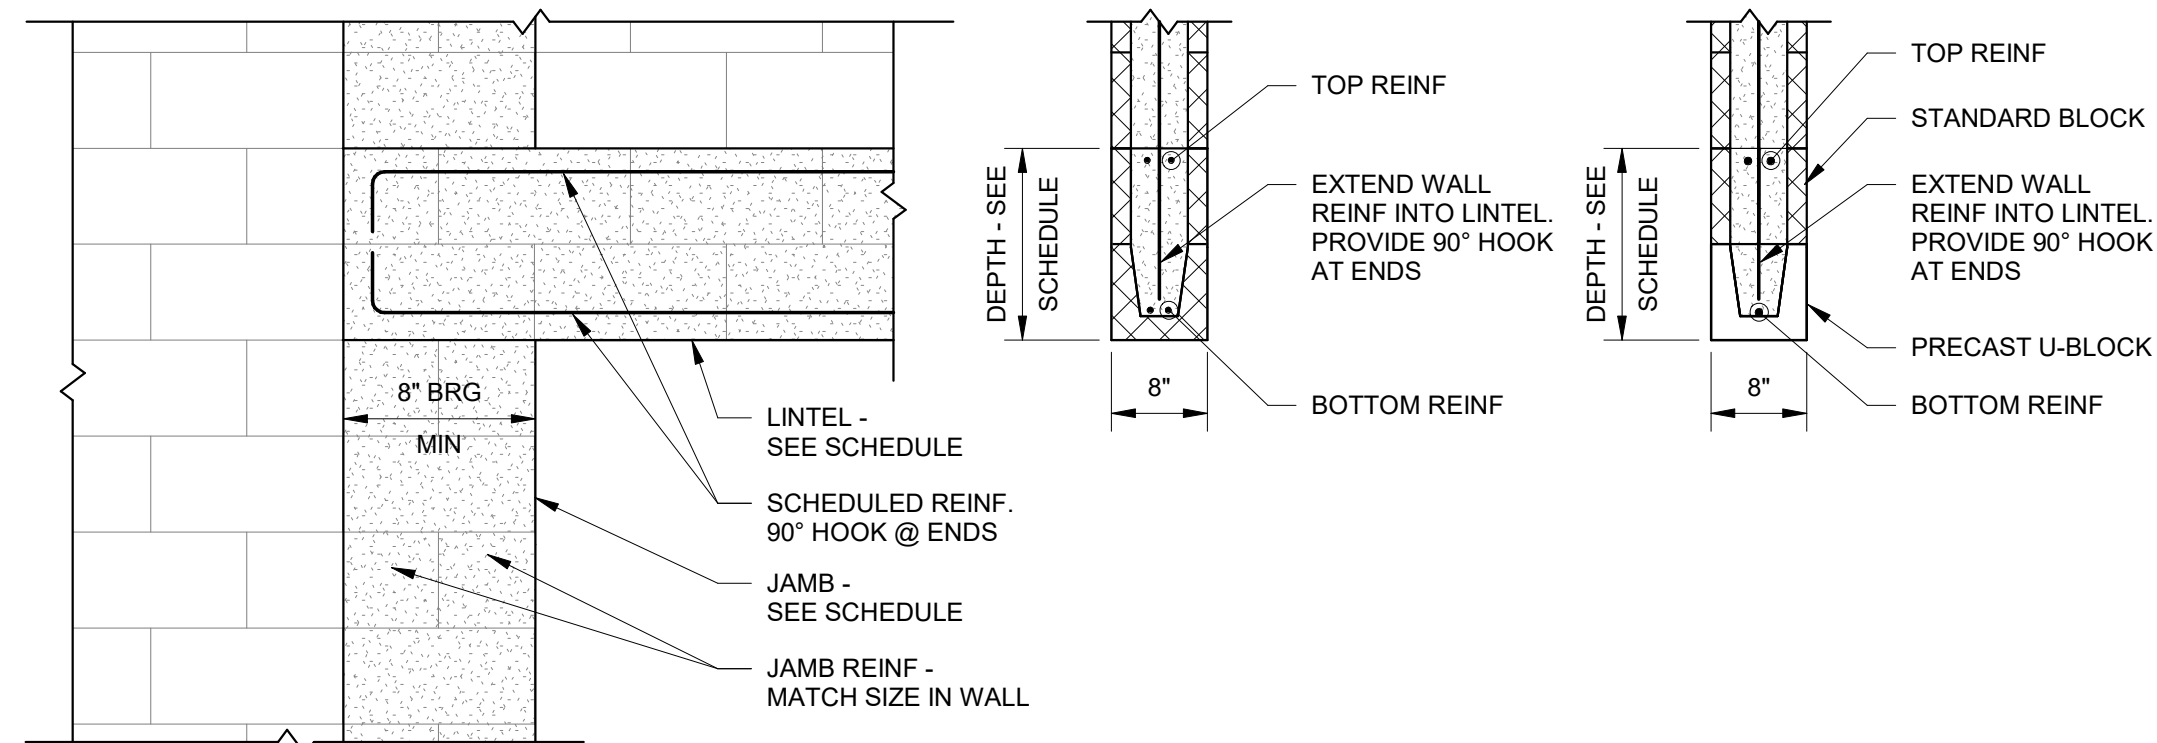

CMU Lintel Schedule						Precast Lintel
Opening Width	Wall Thickness	Lintel Depth	Bottom Reinf	Top Reinf	Jamb	
3'-0"-4'-0"	8"	8"	(1)#5	---	1 Cell	8F8-1B
4'-0"-6'-1"	8"	16"	(1)#5	(1)#5	2 Cells	8F16-1B/1T
6'-1"-8'-0"	8"	20"	(1)#5	(2)#5	2 Cells	8F20-1B/2T
8'-1"-12'-0"	8"	24"	(2)#5	(2)#5	2 Cells	8F24-2B/2T

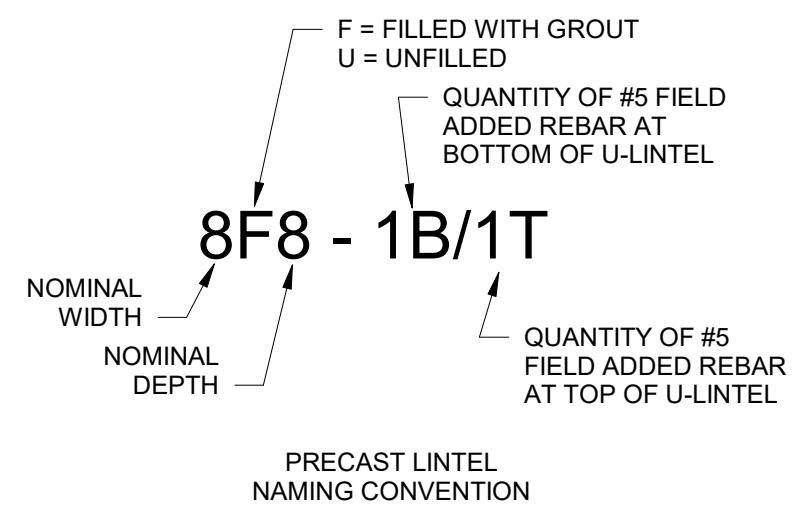


6 Masonry Lintel Detail
N.T.S.

OLD MEMORIAL


13600 National Golf Dr
Tampa, FL 33626

no.	description	date
	PERMIT SET	4.24.26


S0-105 TYPICAL DETAILS

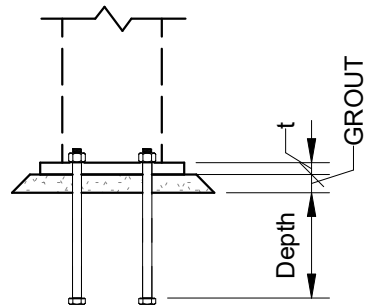



Base Plate Schedule											
Mark	Base Plate				Anchor Rods			Weld		Grout	
	N	B	E1	E2	t	#	Dia	Depth	W1	W2	
BP-1	8"	8"	2 1/2"	2 1/2"	3/4"	4	3/4"	12"	1/4"	1/4"	1 1/2"

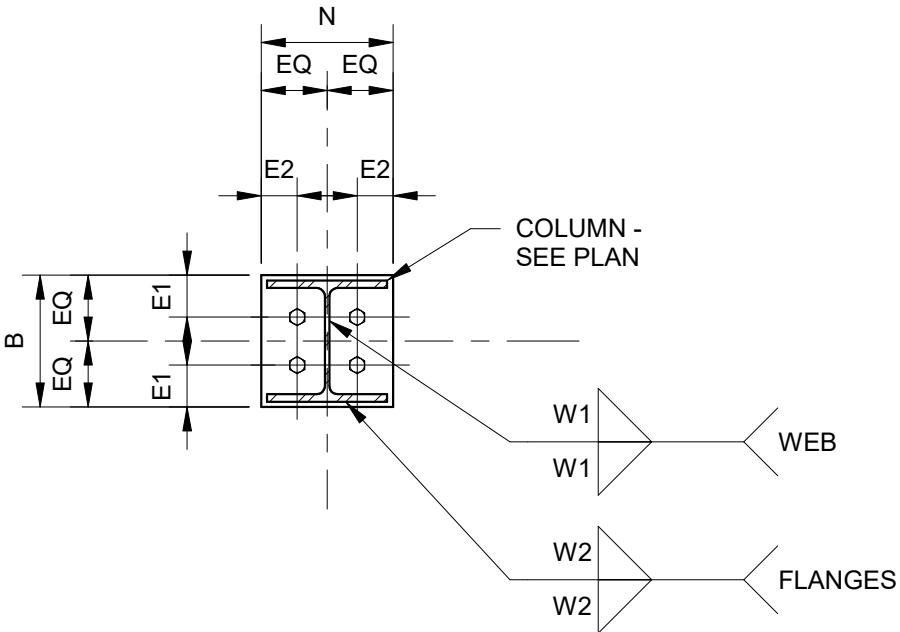



1 Base Plate Schedule and Details
3/4" = 1'-0"

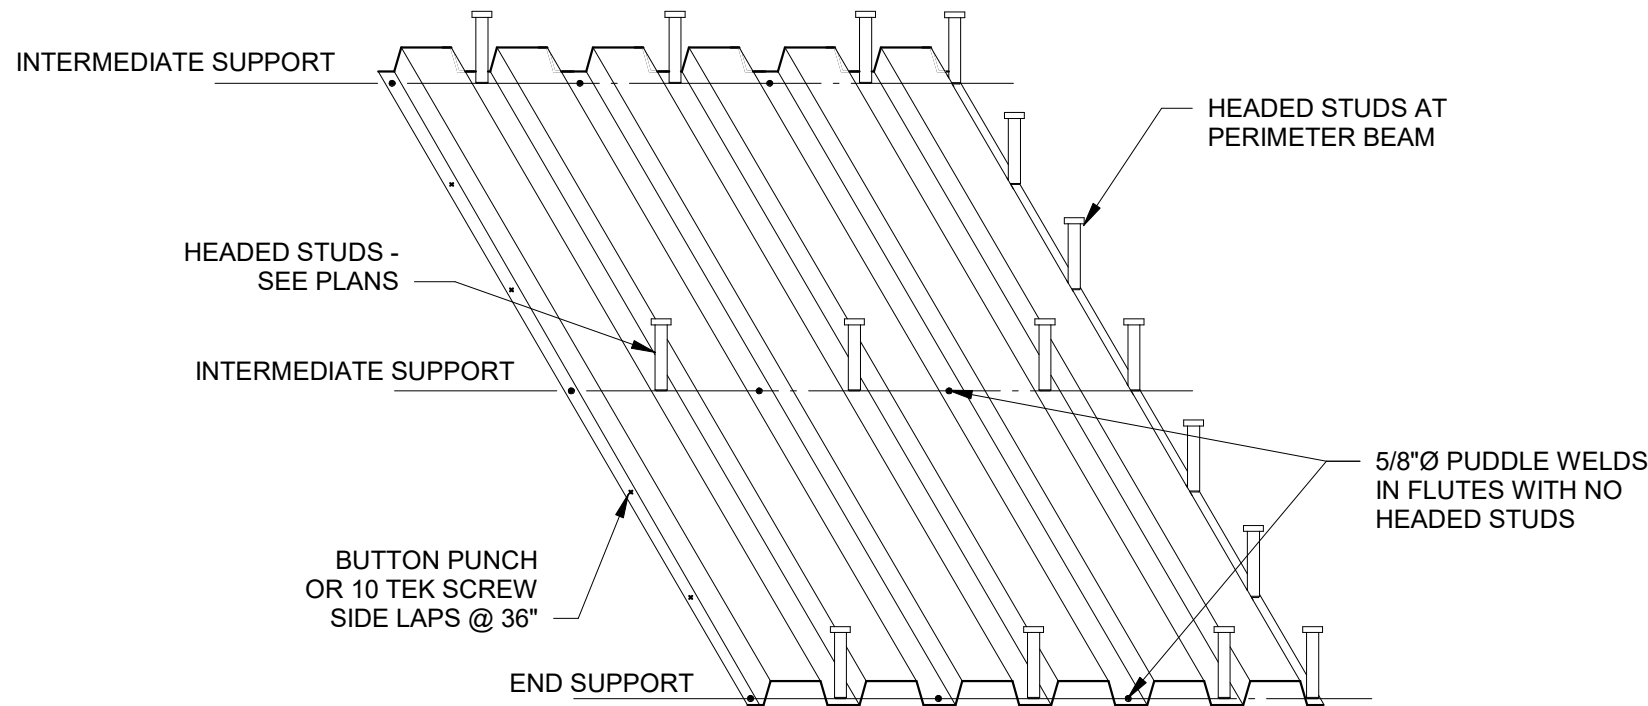





2 Composite Deck Attachment Detail
1" = 1'-0"

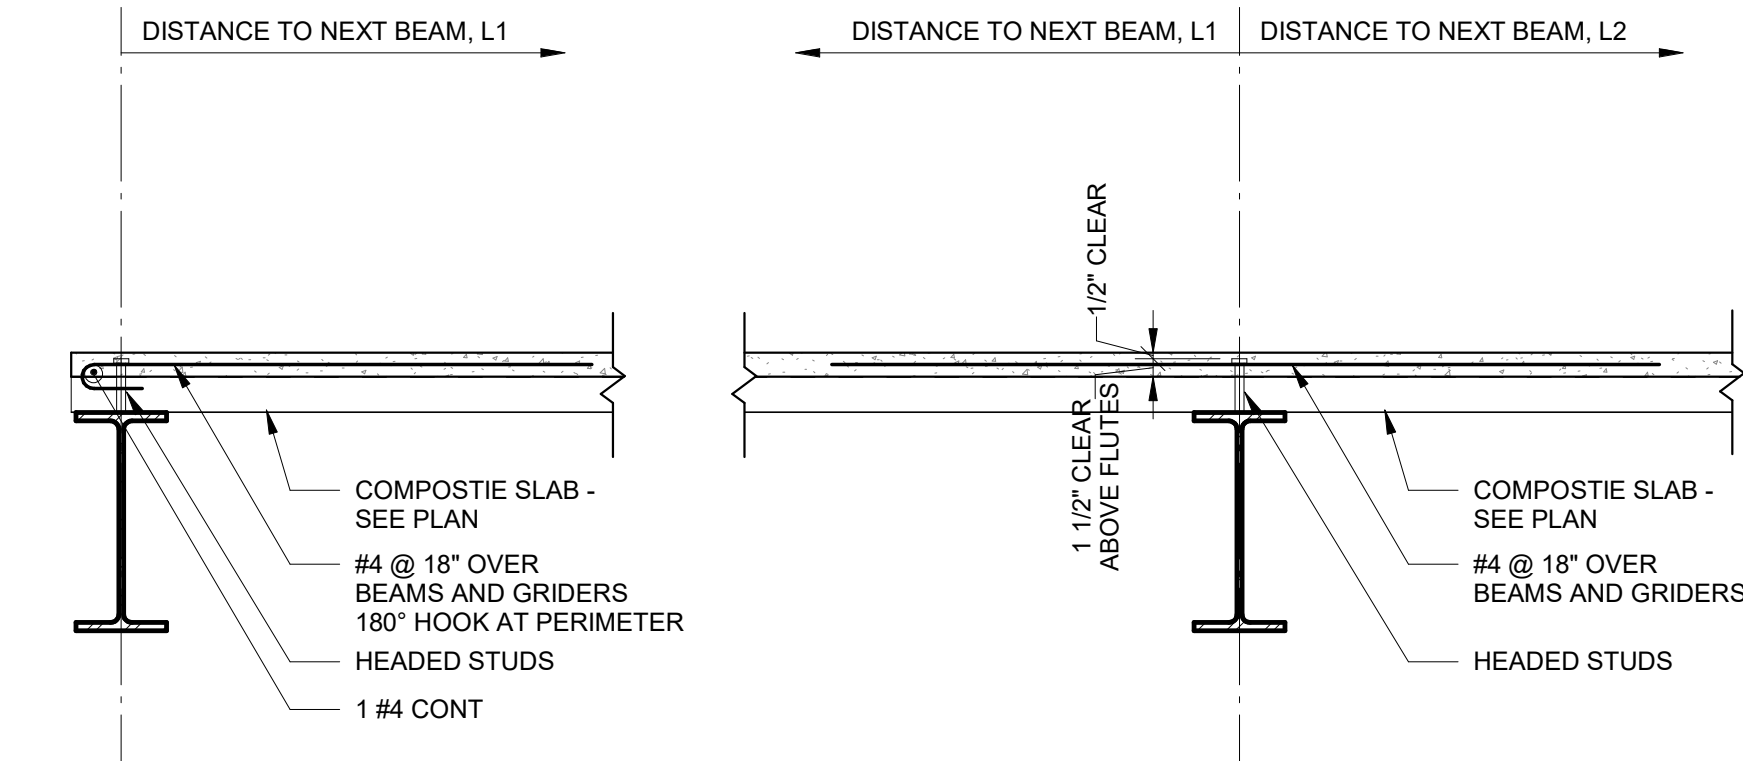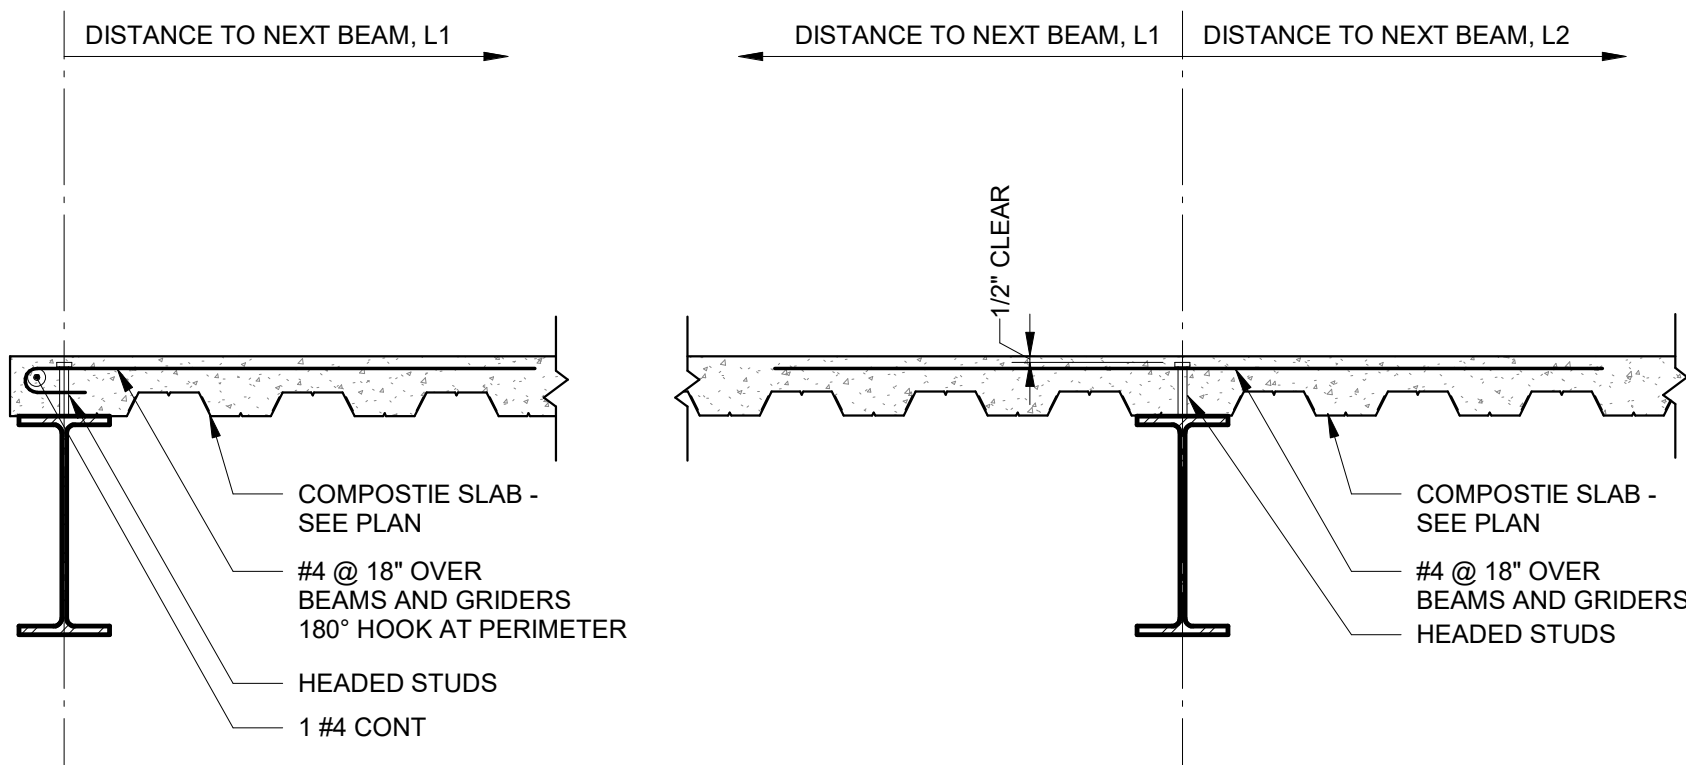

4 Composite Slab Reinforcement At Beams and Girders Detail
3/4" = 1'-0"

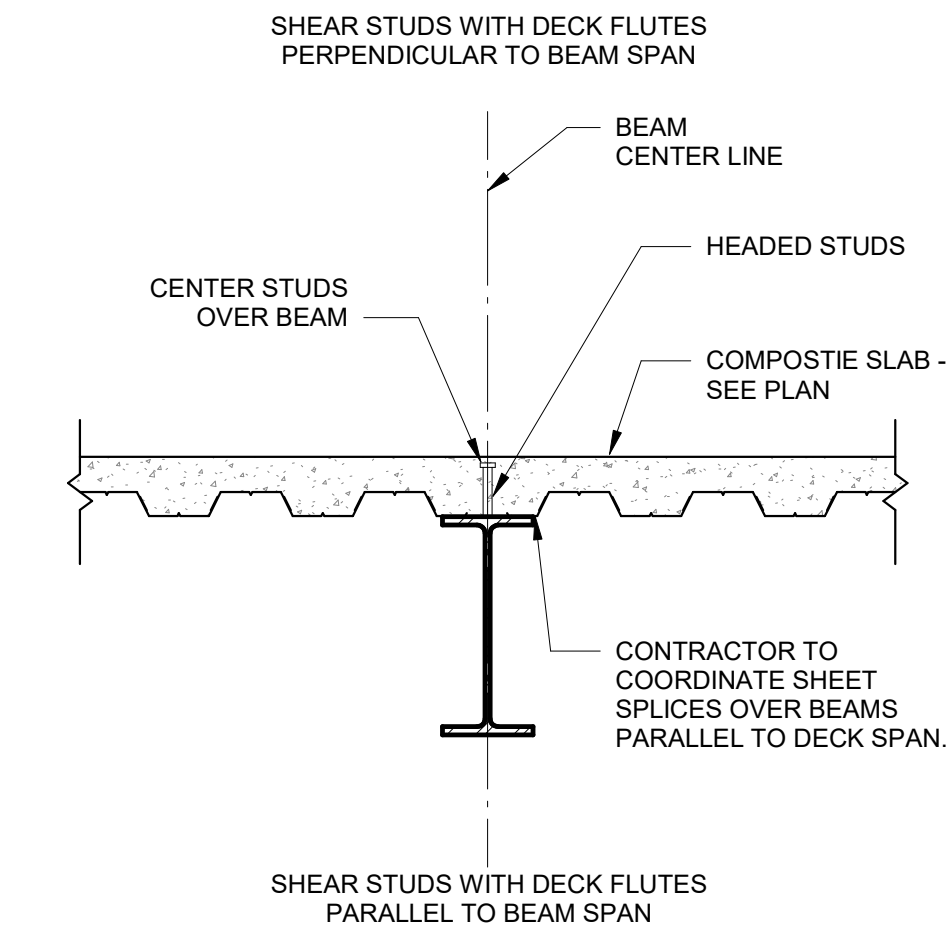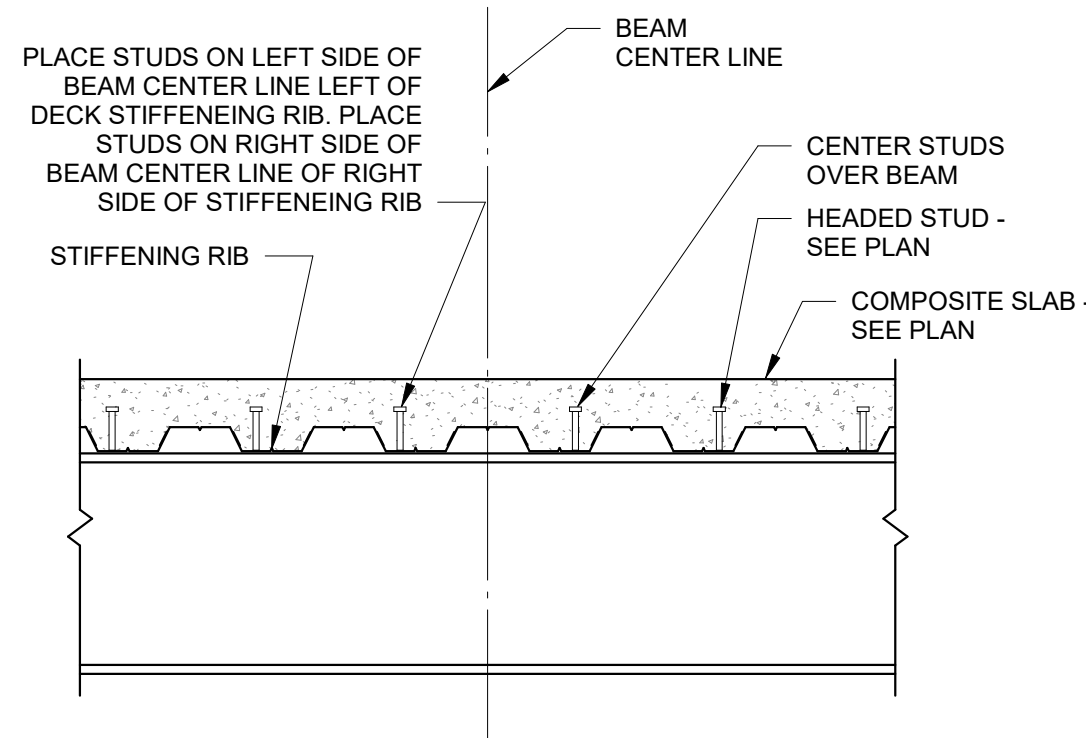


5 Placement of Headed Shear Studs in Deck Flutes Detail
3/4" = 1'-0"

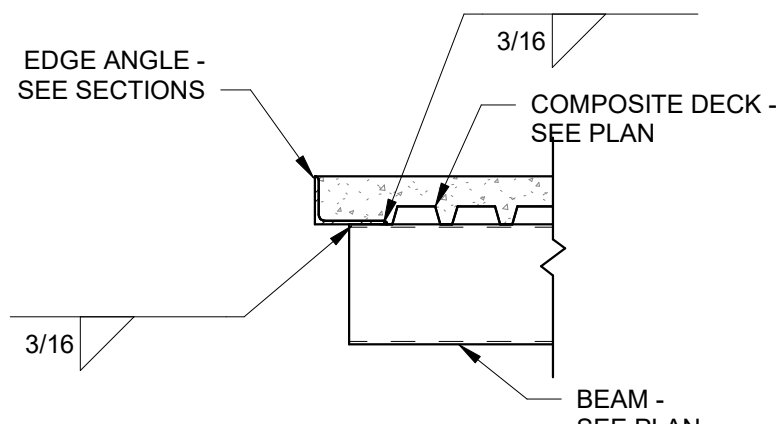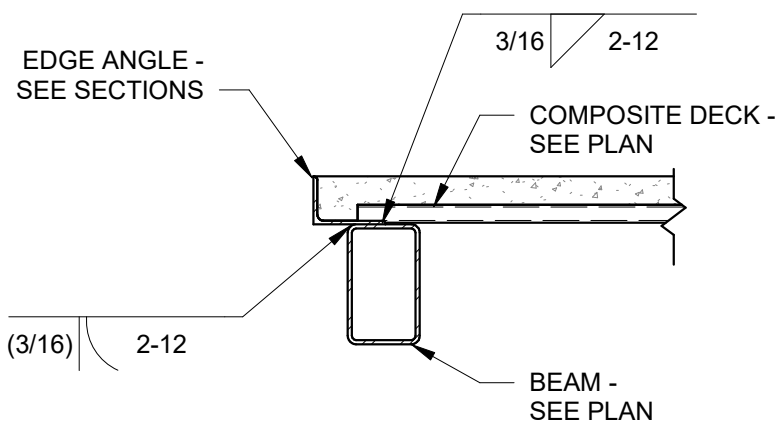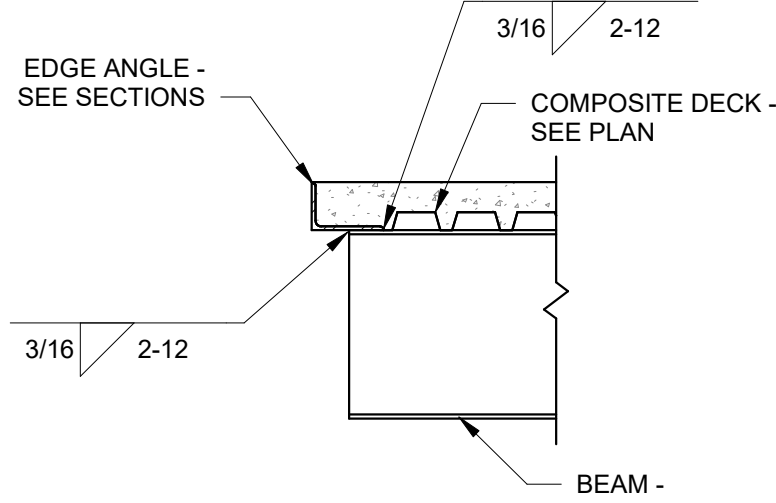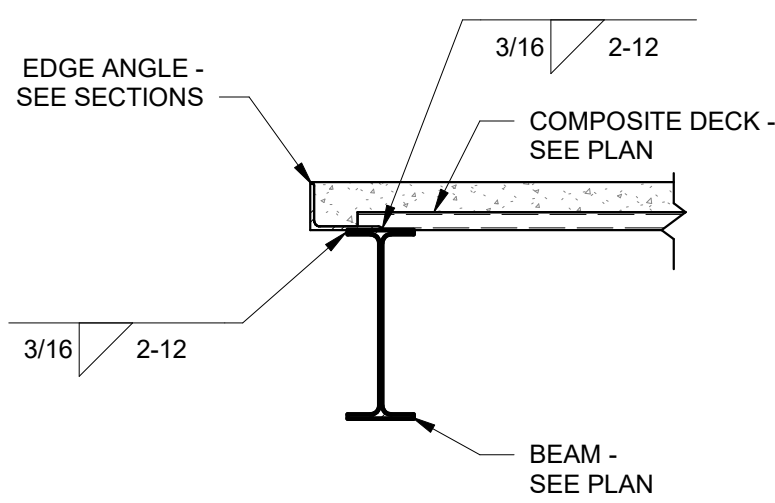

3 Composite Deck Edge Angle Attachment
3/4" = 1'-0"

no.	description	date
	PERMIT SET	4.24.26

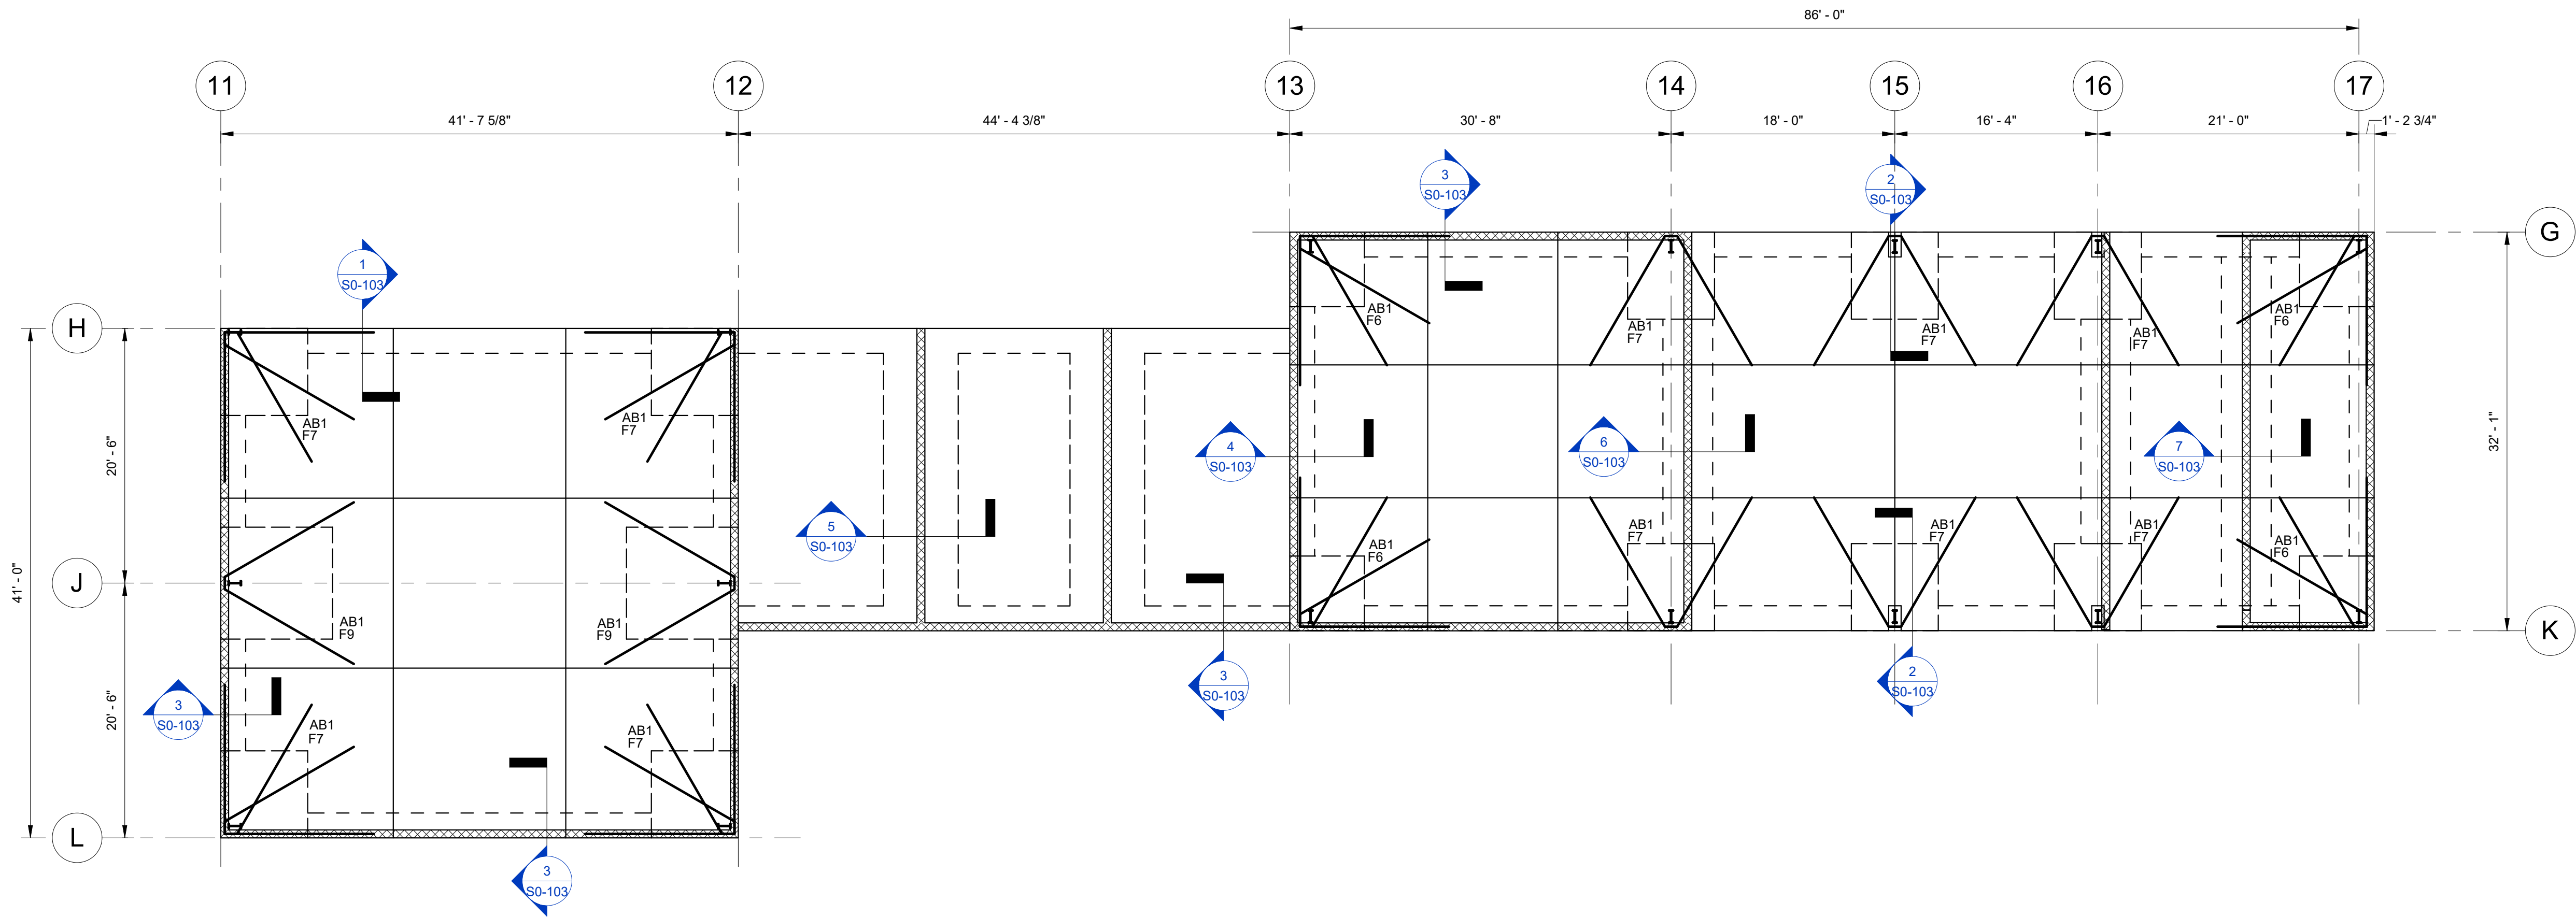


- 1 Building 2 - Foundation and First Floor Plan
- 1/8" = 1'-0"
1. FINISH FLOOR (SLAB ON GRADE) ELEVATION 0'-0", UNLESS NOTED ON PLAN.

2. FOUNDATIONS ARE POURED MONOLITHICALLY WITH SLAB ON GRADE.

3. SLAB ON GRADE: 4" THICK CONCRETE, REINFORCED WITH 6X6 W2.9/2.9 WWR. SEE GENERAL NOTES AND TYPICAL DETAILS.

Structural Foundation Schedule - BLDG 2						
Mark	Length	Width	Depth	Bottom Reinforcement	Top Reinforcement	Notes
F6	6' - 0"	6' - 0"	2' - 6"	(7)#7 EW	(7)#7 EW	
F7	7' - 0"	7' - 0"	2' - 6"	(8)#7 EW	(8)#7 EW	
F9	9' - 0"	9' - 0"	3' - 0"	(10)#7 EW	(10)#7 EW	

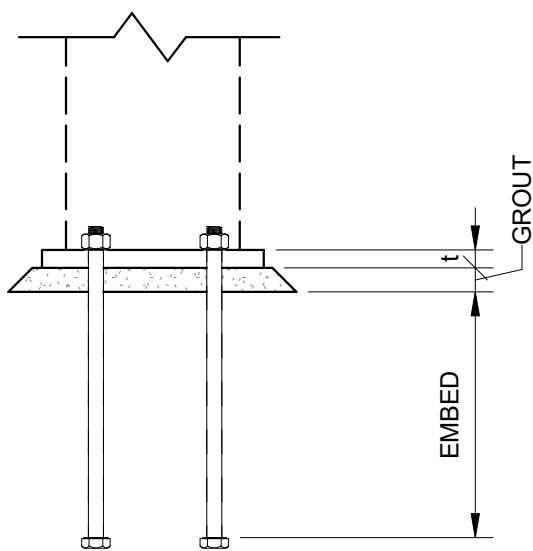

Anchor Bolt Schedule			
Mark	Anchor Rods		
	#	Dia.	Embed
AB1	4	3/4"	1' - 4"

OLD MEMORIAL

13600 National Golf Dr

Tampa, FL 33626

no.	description	date
	PERMIT SET	4.24.26

S2-101

FOUNDATION PLAN



no.	description	date
	PERMIT SET	04.24.26

ELECTRICAL SYMBOL LEGEND

WIRING AND POWER

	WALL OUTLET BOX AND SINGLE RECEPTACLE
	WALL OUTLET BOX AND DUPLEX RECEPTACLE
	TWO GANG WALL OUTLET BOX AND (2) DUPLEX RECEPTACLES
	WALL OUTLET BOX AND DUPLEX RECEPTACLE MOUNTED ABOVE COUNTER
	WALL OUTLET BOX AND DUPLEX RECEPTACLE WITH TOP HALF SWITCHED
	WALL OUTLET BOX AND DUPLEX RECEPTACLE CONNECTED TO EMERGENCY SYSTEM
	CEILING OUTLET BOX AND SINGLE RECEPTACLE
	CEILING OUTLET BOX AND DUPLEX RECEPTACLE
	WALL OUTLET BOX AND GFCI DUPLEX RECEPTACLE
	WALL OUTLET BOX AND GFCI DUPLEX RECEPTACLE MOUNTED ABOVE COUNTER
	WALL OUTLET BOX AND DUPLEX SAFETY RECEPTACLE
	WALL OUTLET BOX AND DUPLEX TWIST-LOCK RECEPTACLE
	WALL OUTLET BOX AND WEATHERPROOF COVER
	WALL OUTLET BOX AND SPECIAL PURPOSE OUTLET AS NOTED ON PLANS
	FLUSH FLOOR OUTLET BOX WITH DUPLEX RECEPTACLE
	FLUSH FLOOR OUTLET BOX WITH (2) DUPLEX RECEPTACLES
	FLUSH FLOOR OUTLET BOX WITH DUPLEX RECEPTACLE AND TELECOMMUNICATIONS OUTLET
	FLUSH WALL JUNCTION BOX AND BLANK PLATE
	JUNCTION BOX AND BLANK PLATE ABOVE CEILING
	SURFACE MOUNTED JUNCTION BOX AND BLANK PLATE
	SURFACE MOUNTED WEATHERPROOF JUNCTION BOX AND COVER
	FLUSH GRADE FIBER COMPOSITE PULL BOX AS NOTED
	MOTOR CONNECTION AS NOTED
	FLUSH SHUNT-TRIP BUTTON, MOUNTED 80" TO TOP
	CONTROL AND/OR POWER EQUIPMENT CONNECTION
	TIME CLOCK
	PHOTO CELL
	DISCONNECT SWITCH, SIZE AS NOTED
	120/208V BRANCH CIRCUIT PANELBOARD, SURFACE MOUNTED
	120/208V BRANCH CIRCUIT PANELBOARD, FLUSH MOUNTED
	277/480V BRANCH CIRCUIT PANELBOARD
	TRANSFORMER
	AUTOMATIC TRANSFER SWITCH
	BRANCH CIRCUIT HOMERUN WITH PANEL NAME AND CIRCUIT NUMBER. QUANTITY OF ARROWHEADS DENOTES QUANTITY OF BRANCH CIRCUITS
	BRANCH CIRCUIT WIRING, PROVIDE QUANTITY OF CONDUCTORS REQUIRED FOR CIRCUITING AND SWITCHING INDICATED ON PLANS
	POWER LEG ONLY (NO SWITCH LEG BETWEEN ROOMS)
	CONDUIT CAPPED OFF
	CONDUIT CONTINUED
	CONDUIT RUN UP
	CONDUIT RUN DOWN
	GROUND OR GROUND ROD AS NOTED

NOTE:
SYMBOLS SHOWN ARE FOR
REFERENCE PURPOSES
ONLY. ALL OF THESE
SYMBOLS MAY NOT BE
USED FOR THIS PROJECT.

ELECTRICAL SYMBOL LEGEND

LIGHTING AND SWITCHING

	CEILING MOUNTED LIGHT FIXTURE, REFER TO LIGHT FIXTURE SCHEDULE
	CEILING MOUNTED RECESSED DOWNLIGHT FIXTURE, REFER TO LIGHT FIXTURE SCHEDULE
	CEILING MOUNTED RECESSED WALLWASH FIXTURE, REFER TO LIGHT FIXTURE SCHEDULE
	CEILING MOUNTED "CLOSE TO CEILING" FIXTURE, REFER TO LIGHT FIXTURE SCHEDULE
	PENDANT MOUNTED LIGHT FIXTURE, REFER TO LIGHT FIXTURE SCHEDULE
	TRACK LIGHT FIXTURE WITH HEADS AS REQUIRED, REFER TO LIGHT FIXTURE SCHEDULE
	WALL MOUNTED LIGHT FIXTURE, REFER TO LIGHT FIXTURE SCHEDULE
	CEILING MOUNTED LIGHT FIXTURE WITH EMERGENCY BACKUP
	CEILING MOUNTED RECESSED DOWNLIGHT FIXTURE WITH EMERGENCY BACKUP
	WALL MOUNTED LIGHT FIXTURE WITH EMERGENCY BACKUP
	WALL MOUNTED EMERGENCY BATTERY LIGHT FIXTURE, REFER TO LIGHT FIXTURE SCHEDULE
	CEILING MOUNTED EMERGENCY BATTERY LIGHT FIXTURE, REFER TO LIGHT FIXTURE SCHEDULE
	CEILING MOUNTED EXIT SIGN WITH EMERGENCY BACKUP, REFER TO LIGHT FIXTURE SCHEDULE
	WALL MOUNTED EXIT SIGN WITH EMERGENCY BACKUP, REFER TO LIGHT FIXTURE SCHEDULE
	COMBINATION EXIT SIGN AND EMERGENCY LIGHT FIXTURE WITH BATTERY BACKUP
	WALL OUTLET BOX AND SINGLE POLE SWITCH (S INDICATES SWITCH LEG)
	WALL OUTLET BOX AND THREE-WAY SWITCH
	WALL OUTLET BOX AND FAN CONTROL SWITCH
	WALL OUTLET BOX AND DIMMER SWITCH AS REQUIRED FOR LOAD SERVED
	WALL OUTLET BOX AND THREE-WAY DIMMER SWITCH
	WALL OUTLET BOX WITH SINGLE POLE MANUAL MOTOR STARTER SWITCH
	WALL OUTLET BOX AND DUAL TECHNOLOGY OCCUPANCY SENSOR
	CEILING OUTLET BOX AND DUAL TECHNOLOGY OCCUPANCY SENSOR
	CEILING OUTLET BOX AND DAYLIGHT HARVESTING SENSOR

FIRE ALARM SYSTEM LEGEND

	MANUAL PULL STATION
	WALL MOUNTED HORN WITH STROBE (cd=CANDELA RATING)
	WALL MOUNTED HORN WITH STROBE IN WEATHERPROOF ENCLOSURE
	CEILING MOUNTED HORN WITH STROBE
	WALL MOUNTED MINI HORN
	WALL MOUNTED MINI HORN WITH STROBE
	WALL MOUNTED VOICE EVACUATION SPEAKER WITH STROBE
	CEILING MOUNTED VOICE EVACUATION SPEAKER WITH STROBE
	WALL MOUNTED STROBE
	SMOKE DETECTOR
	SMOKE AND CARBON MONOXIDE DETECTOR
	DUCT MOUNTED SMOKE DETECTOR
	HEAT DETECTOR
	REMOTE DUCT DETECTOR INDICATOR LIGHT AND TEST SWITCH (NUMBER INDICATES QUANTITY)
	FAN SHUT-DOWN RELAY
	ELECTROMAGNETIC DOOR RELEASE DEVICE
	SMOKE DAMPER (PROVIDE BY MECHANICAL, CONNECTED BY ELECTRICAL)
	FIREMAN'S PHONE JACK
	SPRINKLER SYSTEM SUPERVISORY SWITCH CONNECTION
	SPRINKLER SYSTEM FLOW SWITCH CONNECTION
	CONTROL MODULE
	MONITOR MODULE
	LOCK BOX
	FIRE ALARM CONTROL PANEL
	FIRE ALARM TERMINAL CABINET
	FIRE ALARM ANNUNCIATOR PANEL
	DIGITAL ALARM COMMUNICATOR TRANSMITTER

TELECOMMUNICATION SYSTEM LEGEND

	COMBINATION TELECOMMUNICATIONS/DATA WALL OUTLET BOX AND BLANK PLATE WITH MIN. 3/4" C. TO ACCESSIBLE CEILING SPACE. COORDINATE OUTLET REQUIREMENTS WITH OWNER.
	TELECOMMUNICATIONS WALL OUTLET BOX AND BLANK PLATE FOR WALL MOUNTED TELEPHONE WITH MIN. 3/4" C. TO ACCESSIBLE CEILING SPACE. COORDINATE OUTLET REQUIREMENTS WITH OWNER.
	DATA WALL OUTLET BOX AND BLANK PLATE WITH MIN. 3/4" C. TO ACCESSIBLE CEILING SPACE.
	FLUSH FLOOR OUTLET BOX WITH POWER DEVICE AND TELECOMMUNICATIONS OUTLET WITH MIN. 3/4" C. TO ACCESSIBLE CEILING SPACE.
	CEILING OUTLET BOX AND BLANK PLATE WITH MIN. 3/4" C. TO TTB FOR WIRELESS ACCESS POINT. COORDINATE OUTLET REQUIREMENTS WITH OWNER.
	COMBINATION TELECOMMUNICATIONS/TELEVISION WALL OUTLET BOX AND BLANK PLATE. COORDINATE OUTLET AND CABLING REQUIREMENTS WITH OWNER.
	3/4" PLYWOOD TELEPHONE TERMINAL BOARD, SIZE AS SHOWN ON PLANS.
	TELEPHONE TERMINAL CABINET, SIZE AS NOTED ON PLAN.

GENERAL NOTES:

- ALL WORK SHALL BE DONE IN ACCORDANCE WITH THE LATEST ADOPTED EDITION OF THE NATIONAL ELECTRICAL CODE (NFPA 70), AND THE LATEST ADOPTED EDITION OF THE FLORIDA BUILDING CODE.
- CONTRACTOR SHALL FIELD VERIFY ALL CONDITIONS AND COORDINATE WITH ALL EQUIPMENT MANUFACTURER/INSTALLERS PRIOR TO BIDDING.
- ALL ELECTRICAL MATERIALS, DEVICES, APPLIANCES, AND EQUIPMENT SHALL BE LABEL LISTED BY AN APPROVED THIRD-PARTY TESTING AGENCY.

BUILDING:

RECEPTACLE = 18"
CLOCK = 7'-6"
SWITCH = 44"
MODULAR JACK FOR WALL MOUNTED TELEPHONE = 48"
MODULAR TELEPHONE JACK = 18"
TELEVISION OUTLET = 84"
COMPUTER OUTLET = 18"
CALL SWITCH = 44"
REMOTE TEST STATION FOR DUCT DETECTOR = 52"
C = ABOVE COUNTER BACKSPLASH, COORDINATE WITH ARCHITECTURAL ELEVATIONS AND MILLWORK.
- INSTALLATION HEIGHT OF EQUIPMENT (TO CENTERLINE) ABOVE FINISHED FLOOR UNLESS NOTED OTHERWISE SHALL BE:

RECEPTACLE = 18"
CLOCK = 7'-6"
SWITCH = 44"
MODULAR JACK FOR WALL MOUNTED TELEPHONE = 48"
MODULAR TELEPHONE JACK = 18"
TELEVISION OUTLET = 84"
COMPUTER OUTLET = 18"
CALL SWITCH = 44"
REMOTE TEST STATION FOR DUCT DETECTOR = 52"
C = ABOVE COUNTER BACKSPLASH, COORDINATE WITH ARCHITECTURAL ELEVATIONS AND MILLWORK.
- ALL CONDUIT AND WIRING SHALL BE CONCEALED IN WALLS OR ABOVE CEILINGS UNLESS NOTED OTHERWISE OR APPROVED BY THE ARCHITECT/ENGINEER. ALL DEVICE OUTLET BOXES SHALL BE RECESSED UNLESS NOTED OTHERWISE OR APPROVED BY THE ARCHITECT/ENGINEER. WHERE APPROVED OR NOTED SURFACE METAL RACEWAY AND DEVICE BOXES SHALL BE USED IN LIEU OF CONDUIT AND CONCEALED BOXES AT NO EXTRA COST TO THE OWNER.
- ALL CONDUIT ROUTING SHOWN IS APPROXIMATE ONLY. CONTRACTOR SHALL FIELD VERIFY FINAL ROUTE WITH ALL OTHER TRADES AND CONDITIONS IN FIELD PRIOR TO ROUGH-IN.
- CONDUIT RUNS SHOWN ARE SCHEMATIC AND DO NOT INDICATE THE NECESSARY FITTINGS AND JUNCTION BOXES THAT ARE INCLUDED IN THE SCOPE OF THE WORK.
- CONTRACTOR SHALL PERMANENTLY IDENTIFY ALL WIRING WITH THE SOURCE AND CIRCUIT AT ALL ELECTRICAL EQUIPMENT, PULL AND JUNCTION BOXES AND ELECTRICAL TERMINATIONS PROVIDED OR ASSOCIATED WITH THIS CONSTRUCTION.
- COORDINATE EXACT LOCATION OF LIGHTING FIXTURES IN MECH. ROOMS/SPACES WITH DUCTWORK INSTALLER PRIOR TO ROUGH-IN. LOCATE BELOW DUCTWORK(8'-0" AFF MINIMUM) CENTERED IN ROOM AS MUCH AS POSSIBLE.
- COORDINATE EXACT INSTALLATION REQUIREMENTS OF OUTLETS IN MILLWORK WITH ARCHITECTURAL DRAWINGS, APPROVED SHOP DRAWINGS AND MILLWORK INSTALLER PRIOR TO ROUGH-IN.
- VERIFY EXACT LOCATION OF ALL MECHANICAL EQUIPMENT WITH MECHANICAL INSTALLER PRIOR TO ROUGH-IN.
- REFER TO ARCHITECTURAL REFLECTED CEILING PLANS FOR EXACT LOCATIONS OF ALL LIGHT FIXTURES
- PROVIDE NYLON PULLSTRINGS IN ALL EMPTY CONDUITS.
- COORDINATE THE EXACT LOCATION OF ALL ELECTRICAL EQUIPMENT LOCATED IN ELEVATOR MACHINE ROOMS, SHAFTS AND PITS. LOCATE EQUIPMENT AS REQUIRED TO MEET APPLICABLE CODES.PROVIDE AUTOMATIC DISCONNECTION OF THE ELEVATOR MAIN POWER SUPPLY (PER ANSI A17.1, RULE 102.2 1987 ED.) PRIOR TO ACTIVATION OF AUTOMATIC SPRINKLER LOCATED WITHIN THE ELEVATOR MACHINE ROOM, PIT OR SHAFT. COORDINATE WITH FIRE PROTECTION AND FIRE ALARM INSTALLER.
- COORDINATE THE REQUIRED SIZE OF ALL CIRCUIT BREAKERS FEEDING EQUIPMENT, (I.E. MOTORS, HVAC, KITCHEN EQUIPMENT, SPECIAL PURPOSE OUTLETS, ELEVATORS, OWNER FURNISHED EQUIPMENT ETC.) WITH APPROVED EQUIPMENT SHOP DRAWINGS AND OWNER REPRESENTATIVES PRIOR TO ORDERING PANELBOARDS. BREAKERS SHALL BE SIZED PER THE NEC, THE EQUIPMENT NAME PLATE AND MANUFACTURERS RECOMMENDATIONS.
- ALL DIMMED CIRCUITS SHALL BE PROVIDED WITH DEDICATED NEUTRALS FOR EACH DIMMER AND PHASE CONDUCTOR THROUGHOUT THE ENTIRE CIRCUIT.
- THE POWER COMPANY SHALL BE CONTACTED WITHIN 10 DAYS OF THE AWARD OF THE CONTRACT BY THE CONTRACTOR TO VERIFY THE ACTUAL AVAILABLE SHORT CIRCUIT FAULT CURRENT (AIC) AT THE TRANSFORMER SECONDARY BUSHINGS. THE CONTRACTOR SHALL PROVIDE ELECTRICAL DISTRIBUTION AND UTILIZATION EQUIPMENT AND PANELBOARDS WHICH HAVE AIC/WITHSTAND RATINGS GREATER THAN THE AVAILABLE AIC AT EACH POINT IN THE ELECTRICAL SYSTEM.
- CONTRACTOR SHALL INCLUDE IN HIS BID THE TRANSPORT AND DISPOSAL OR RECYCLING OF ALL WASTE MATERIALS GENERATED BY THIS PROJECT IN ACCORDANCE WITH ALL RULES, REGULATIONS AND GUIDELINES APPLICABLE.
- PANEL SCHEDULES INDICATE CIRCUIT DESIGNATIONS ONLY. CONTRACTOR TO PROVIDE MATERIALS AS REQUIRED WHEN NEUTRALS ARE SHARED TO COMPLY WITH NEC REQUIREMENTS. ALL SINGLE PHASE MULTIWIRE BRANCH CIRCUITS SHALL BE FED VIA A TWO POLE BREAKER OR TWO SINGLE POLE BREAKERS WITH AN IDENTIFIED HANDLE TIE. ALL THREE PHASE MULTIWIRE BRANCH CIRCUITS SHALL BE FED VIA A THREE POLE BREAKER OR THREE SINGLE POLE BREAKERS WITH AN IDENTIFIED HANDLE TIE (PER NEC 210.4B).
- PER NEC 110.22; PROVIDE PERMANENT LABELING FOR ALL SERIES RATED PANEL ENCLOSURES TO READ AS FOLLOWS: CAUTION - SERIES COMBINATION SYSTEM RATED _____ AMPERES.

GROUNDING:

21. ALL METAL RACEWAYS, INCLUDING CONDUIT, WIRE TROUGHS, WIREMOLD, ETC., SHALL BE GROUNDED. ALL CONNECTIONS IN METAL RACEWAYS SHALL BE COMPLETED IN SUCH A MANNER AS TO MAINTAIN A CONTINUOUS PATH TO GROUND THROUGHOUT THE ENTIRE LENGTH OF THE RACEWAY.


WIRING:

22. UNLESS NOTED OTHERWISE ON THE DRAWINGS OR ON THE EQUIPMENT WIRING SCHEDULE, EACH BRANCH CIRCUIT HOME RUN SHALL BE THREE (3) #12 AWG THHN/THWN (1 HOT, 1 NEUTRAL & 1 EQUIPMENT GROUND) IN 3/4" EMT CONDUIT. PROTECT EACH CIRCUIT WITH A 20 AMPERE, 1-POLE OVERCURRENT DEVICE UNLESS NOTED OTHERWISE. COMBINED NEUTRALS ARE NOT PERMITTED.


23. THE USE OF 'NM' CABLE FOR BRANCH CIRCUIT WIRING IS ACCEPTABLE WHERE ALLOWED BY THE NEC AND AUTHORITY HAVING JURISDICTION.

BDA SYSTEM:

24. ALL BUILDINGS WITHIN THIS PROJECT SHALL HAVE AN APPROVED THIRD-PARTY PROVIDE A SPECTRUM ANALYSIS GRID TEST OF THE BUILDINGS AND PROVIDE A COPY OF THE ANALYSIS OF THE RADIO SIGNAL STRENGTH AND RECOMMENDATIONS FOR THE REQUIREMENT OF A DAS/BDA SYSTEM (WHETHER NECESSARY TO INSTALL) TO THE G.C. AND A.H.J. IF REQUIRED TO BE ADDED, BASED ON TESTING, DESIGN WILL BE PROVIDED BY OTHERS (DAS/BDA CONTRACTOR) UNDER A SEPARATE PERMIT AND IN CONFORMANCE TO THE FPPC, FAC AND NFPA. FINAL TESTING WILL BE REQUIRED AT COMPLETION OF THE BUILDING CONSTRUCTION PRIOR TO OBTAINING THE CERTIFICATE OF OCCUPANCY. THE SIGNAL STRENGTH SHALL MEET THE REQUIREMENTS OF THE FLORIDA FIRE PREVENTION CODE 6TH EDITION; NFPA 111.10; NFPA 72-2016 EDITION 24.5.2.2, 24.5.2.3; AND MUST BE TESTED IN ACCORDANCE WITH THE PROVISIONS SET FORTH IN NFPA 72-2016 EDITION 14.4.10 (1-6) AND A14.4.10 (1-3).

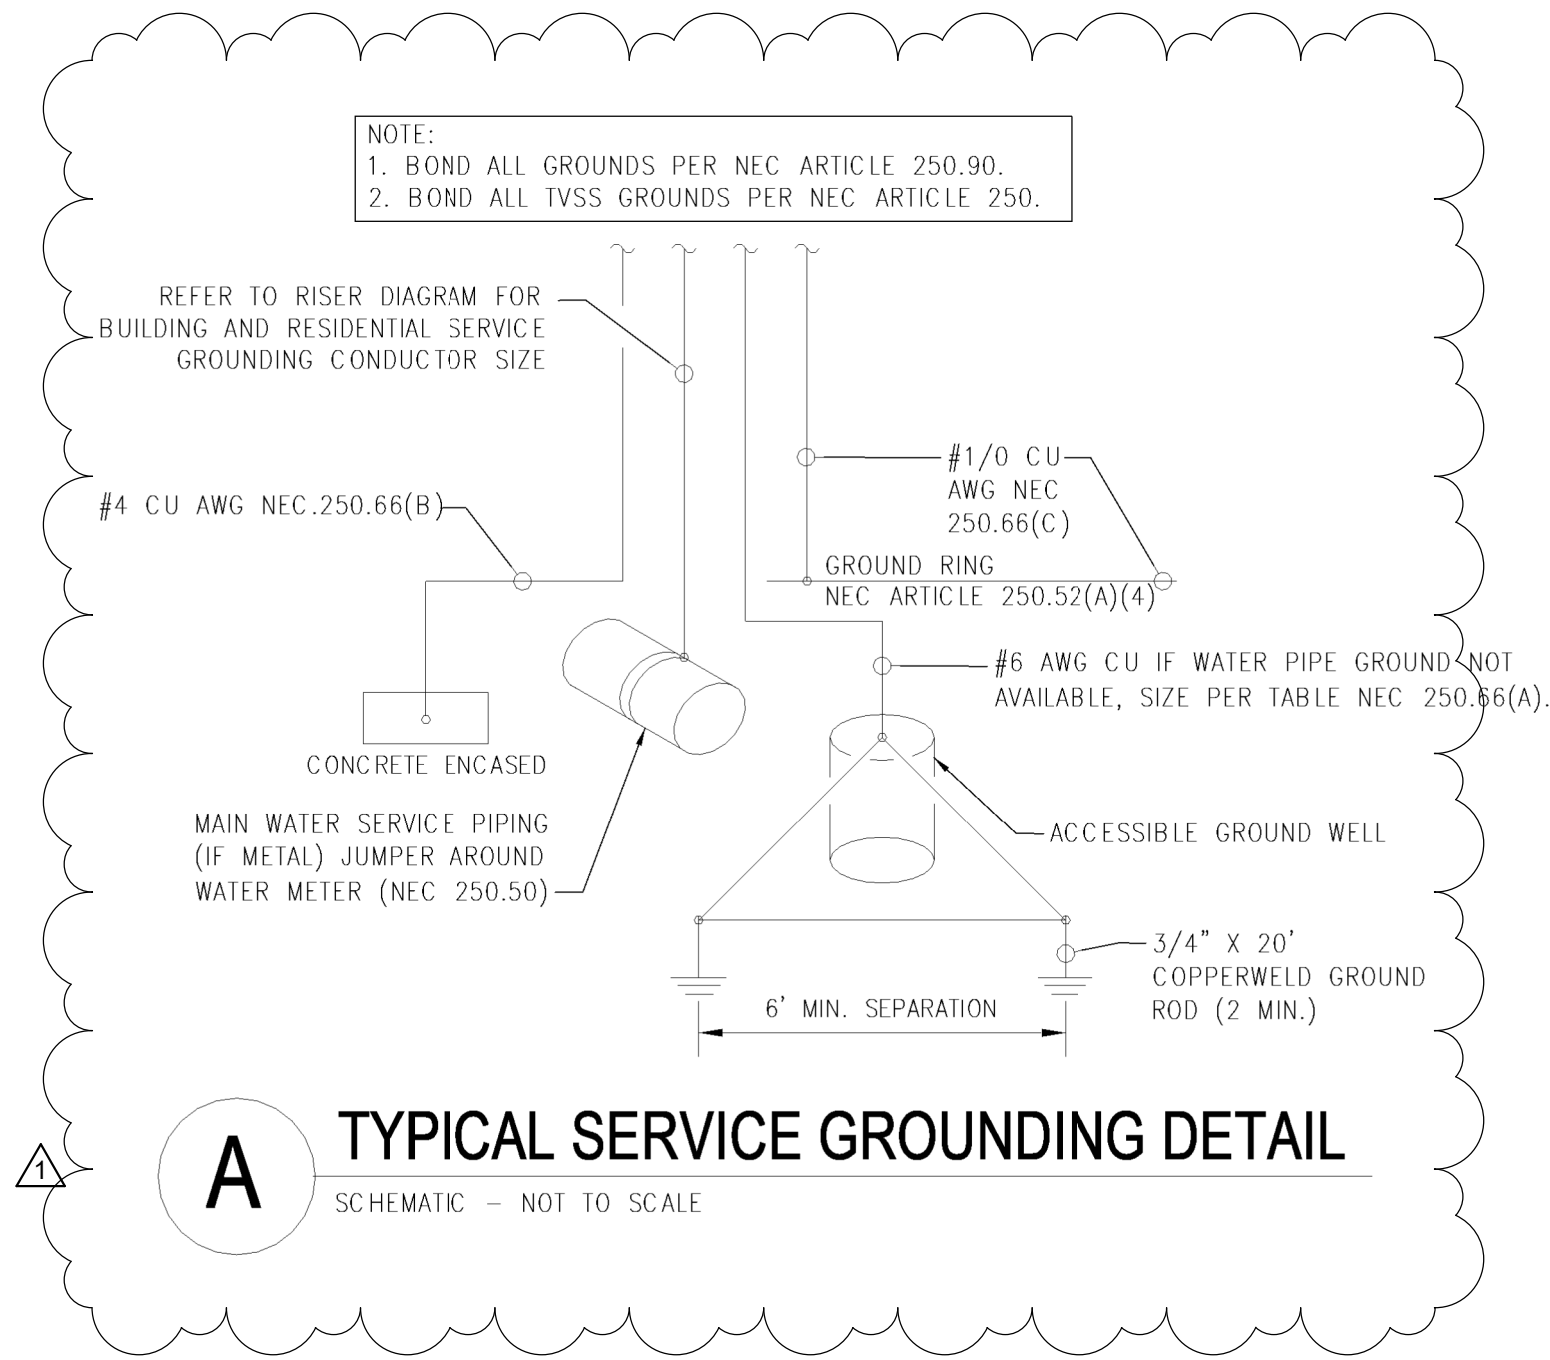

2 Electrical Riser Diagram Sand & Chemical Storage Building 2
1" = 1'-0"

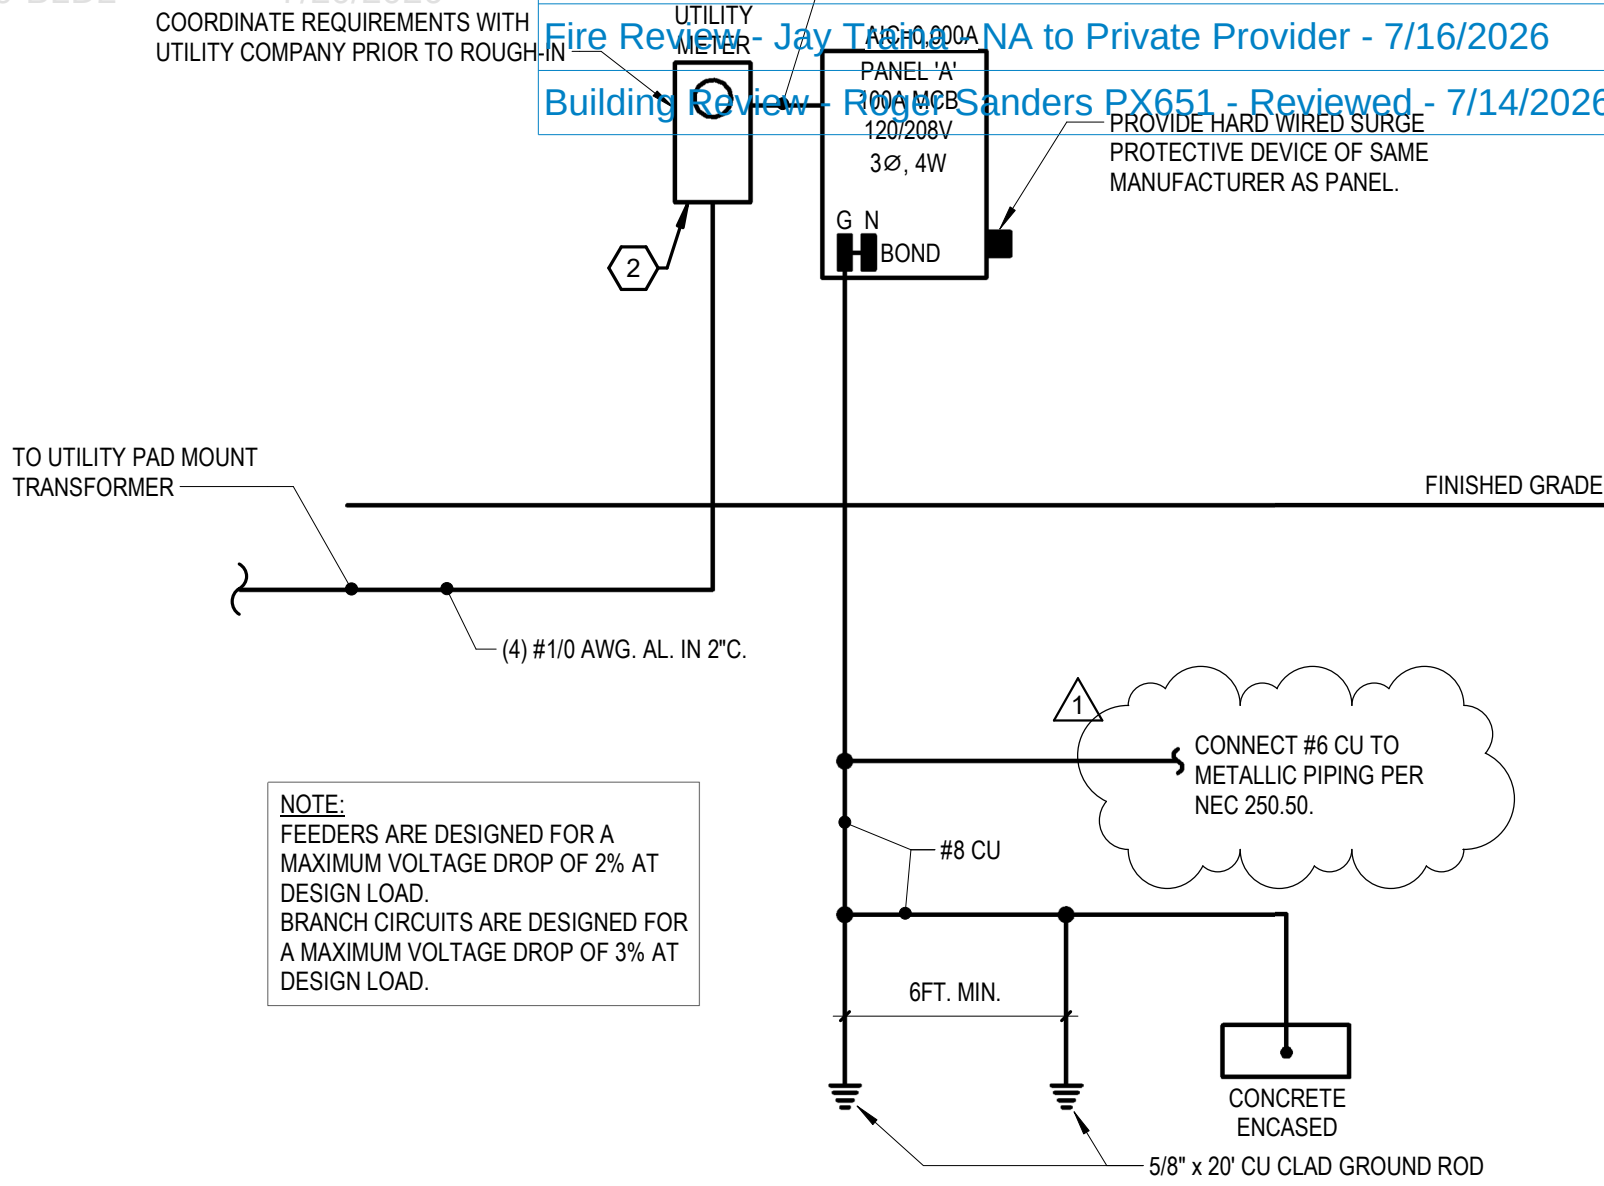


GENERAL NOTES:

- DO NOT SCALE ELECTRICAL DRAWING FOR ANY DIMENSIONS.
- ALL WORK SHALL COMPLY WITH THE LATEST ADOPTED EDITION OF THE NATIONAL ELECTRICAL CODE, STATE, AND LOCAL CODES. PROVIDE GROUNDING AND BONDING PER NEC 250.
- SEE SINGLE LINE DIAGRAM FOR FEEDER WIRE AND CONDUIT SIZE. ALL CIRCUITS NOT SIZED ON DRAWING SHALL BE INSTALLED TO MEET MINIMUM SIZE REQUIRED BY NEC. ALL CONDUCTORS SHALL HAVE AN EQUIPMENT GROUND WIRE SIZED PER NEC.
- FIELD VERIFY EXACT LOCATION OF ALL DEVICES AND EQUIPMENT PRIOR TO ROUGH IN.

REFERENCE NOTES:

- PROVIDE PUSHBUTTON CONTROL AND LOW VOLTAGE WIRING FOR GARAGE DOOR OPENER AS REQUIRED BY OWNER/MANUFACTURER.
- PROVIDE 120V CEILING MOUNTED OUTLET FOR GARAGE DOOR OPENER. COORDINATE LOCATION WITH DOOR INSTALLER PRIOR TO ROUGH-IN. PROVIDE LOW VOLTAGE WIRING AND PUSH BUTTON LOCATED NEAR DOOR AS REQUIRED.
- PROVIDE EXTERIOR GARAGE DOOR KEYPAD. COORDINATE LOCATION AND REQUIREMENTS WITH GARAGE DOOR INSTALLER. PROVIDE LOW VOLTAGE WIRING AS REQUIRED.
- CONNECT CIRCUIT VIA PHOTOCELL FOR AUTOMATIC CONTROL OF LIGHT FIXTURES.
- PROVIDE CEILING MOUNTED OCCUPANCY SENSOR FOR AUTOMATIC CONTROL OF ROOM LIGHTING. SENSOR SHALL OVERRIDE WALL CONTROL AND "TURN OFF" ROOM LIGHTS IF ROOM UNOCCUPIED FOR MORE THAN 30 MINUTES. PROVIDE ADDITIONAL SENSORS, RELAY PACKS, CONTROL WIRING, ETC. AS REQUIRED FOR COMPLETE COVERAGE OF ROOM AND CIRCUITS/SWITCH LEGS SHOWN. CONTROLS SHALL BE "MANUAL ON/AUTOMATIC OFF" WITH THE EXCEPTION OF RESTROOMS, PUBLIC CORRIDORS, AND LOBBIES. THESE AREAS SHALL BE FULLY AUTOMATIC ON/AUTOMATIC OFF" IN ACCORDANCE WITH THE 2023 FLORIDA BUILDING CODE 8TH EDITION.
- PROVIDE WALL MOUNTED, DUAL TECHNOLOGY, LOW VOLTAGE VACANCY SENSOR, WATTSTOPPER #DW-100-24 (OR APPROVED SUBSTITUTION) FOR AUTOMATIC CONTROL OF LIGHTING. CONNECT LIGHTING IN SPACE AS SHOWN ON PLANS VIA WATTSTOPPER LIGHTING POWER PACK #BZ-200 (OR APPROVED SUBSTITUTION). PROVIDE ALL ADDITIONAL POWER PACKS, RELAYS, SENSORS AS REQUIRED FOR COMPLETE COVERAGE OF SPACE AND SWITCHING AS SHOWN ON PLANS. INSTALLATION SHALL COMPLY WITH FLORIDA ENERGY CONSERVATION CODE 2023 8TH EDITION SECTION C405.6.1.
- PROVIDE BUILDING MOUNTED DISCONNECT SWITCHES FOR COMPLETE POWER SHUT-OFF OF LIGHTING AND RECEPTACLE CIRCUITS FED FROM EXISTING PANEL 'A' IN EXISTING MAINTENANCE BUILDING #1. SEE SHEET E1.01.1 FOR PANEL LOCATION AND SHEET E6.01 FOR PANEL SCHEDULE CONFIGURATION.

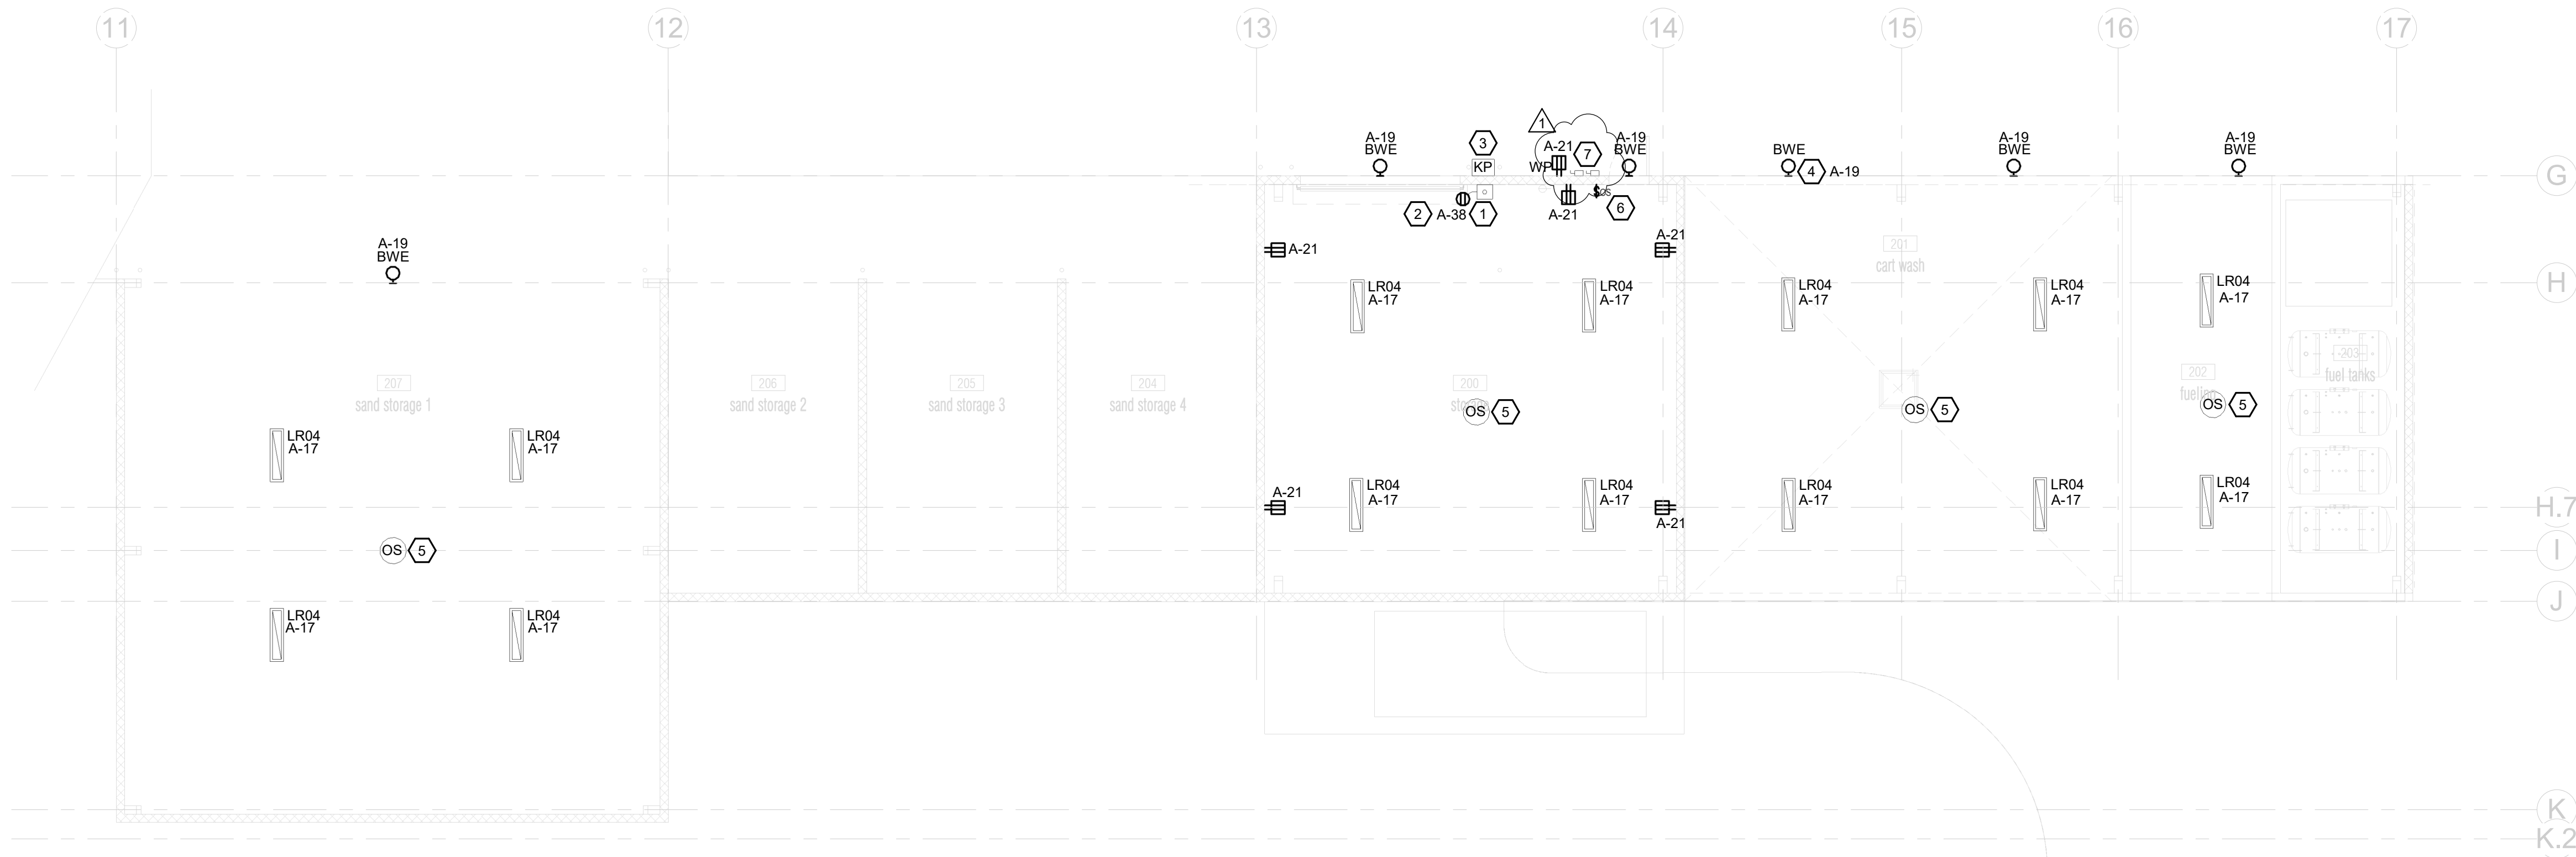


1 SAND AND CHEM STORAGE FLOOR PLAN - ELECTRICAL
1/8" = 1'-0"

OLD MEMORIAL

13600 National Golf Dr
Tampa, FL 33626

no.	description	date
1	PERMIT SET	04.24.26
1	PERMIT COMMENTS	06.19.26

E1.02.1 BUILDING 2 FLOOR PLAN - ELECTRICAL

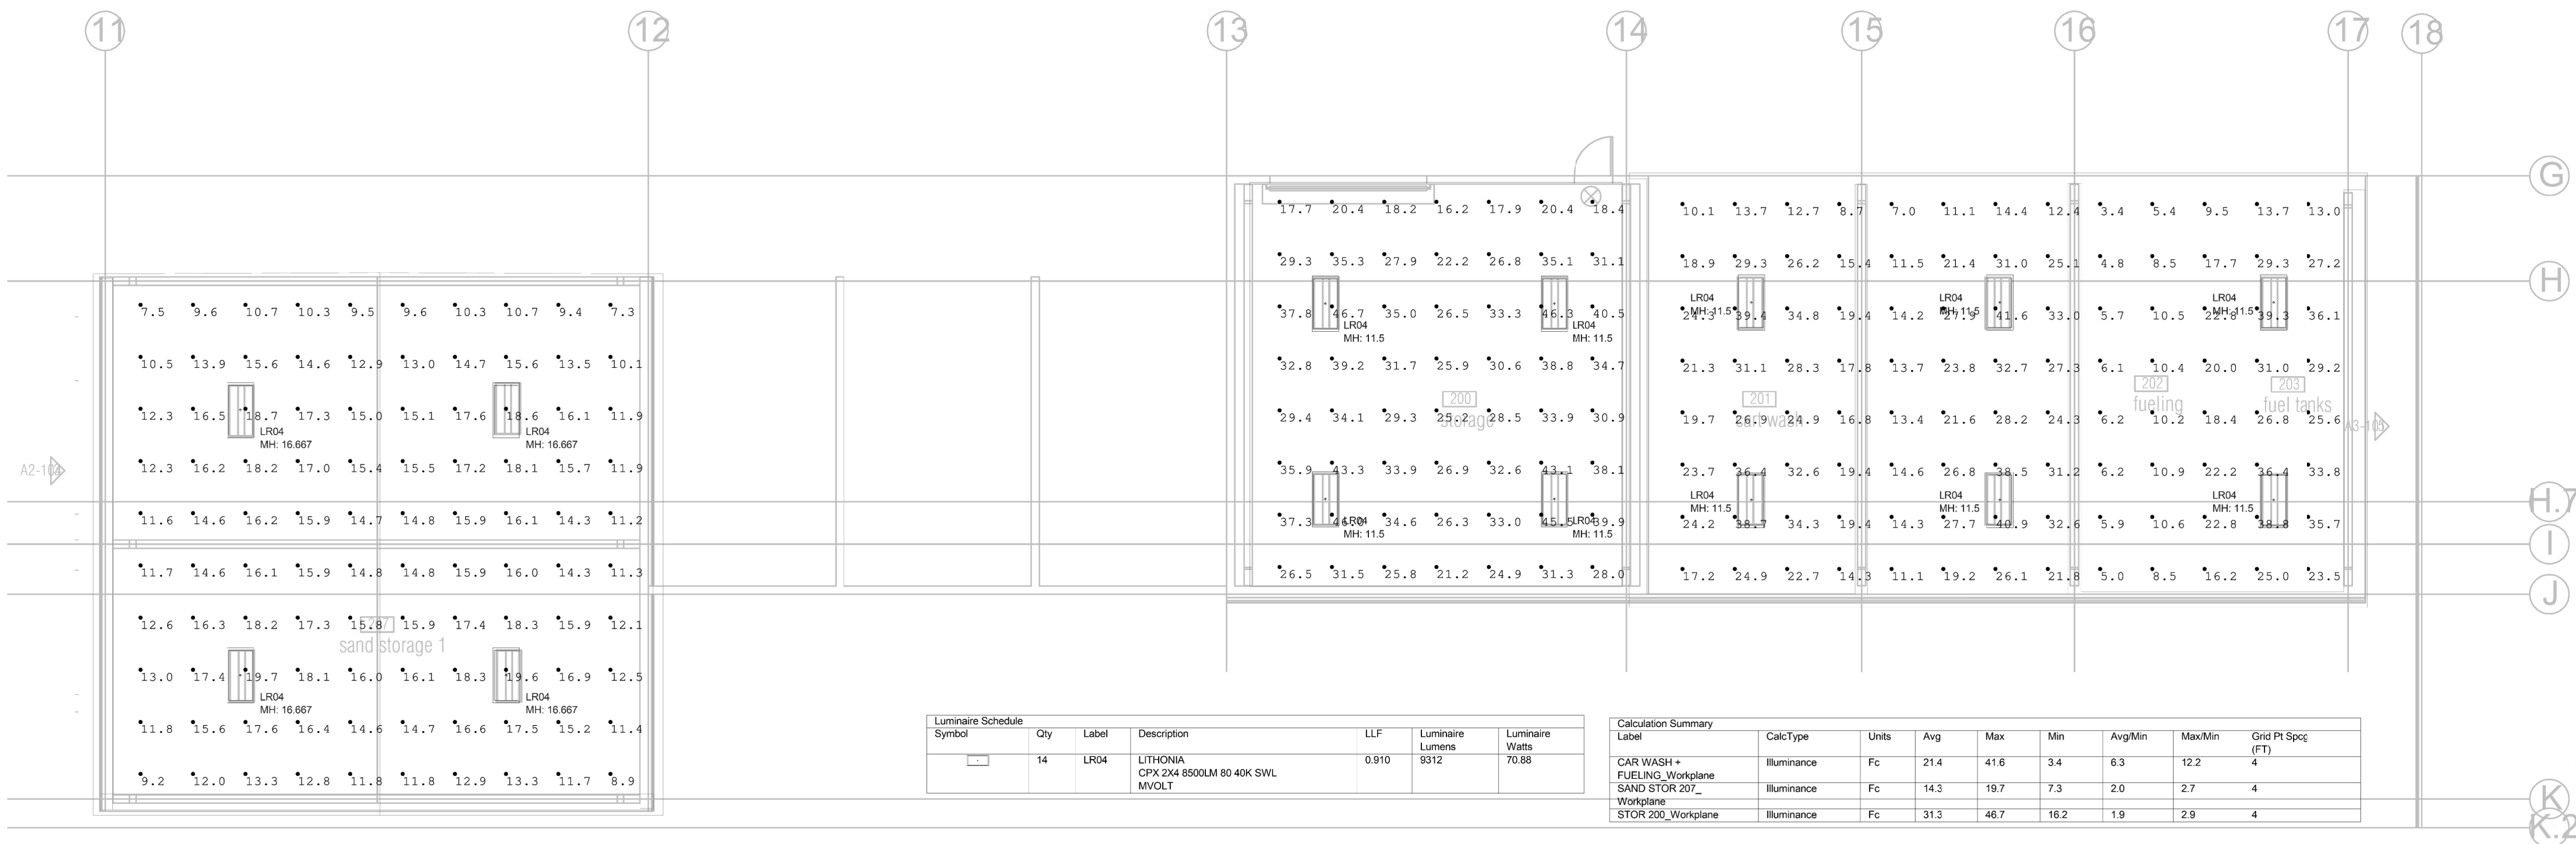

OLD MEMORIAL

13600 National Golf Dr
Tampa, FL 33626

E1.02.2

BUILDING 2 FLOOR
PLAN - ELECTRICAL
LIGHTING
PHOTOMETRY

A

ELECTRICAL LIGHTING FIXTURE SCHEDULE – BUILDING									
TYPE	DESCRIPTION	MANUFACTURER	MODEL	VCLTS	LAMP			FIKTURE	WATTS
					QTY	WATTS	MODEL		
BWE	EXTERIOR FULL CUTOFF LED EGRESS LIGHT, BRONZE FINISH INTEGRAL PHOTOCELL, EMERGENCY BATTERY, SELF DIAGNOSTICS	ROYAL PACIFIC	RELSLED-0B	120	1	18	LED		18
EM	INTERIOR WALL MOUNTED EMERGENCY LIGHT THERMOPLASTIC HOUSING, TWIN HEADS AND INTEGRAL BATTERY BACKUP.	DUAL LITE	EY4-02L	120	2	2	LED		4
X	EXIT SIGN WHITE THERMOPLASTIC HOUSING, RED LETTERING, DIRECTIONAL CHEVRONS AND INTEGRAL BATTERY BACKUP	DUAL LITE	EVE-U-R-W-E	120	1	-	LED		-

NOTES:
1) DIVISION 16 CONTRACTOR SHALL VERIFY ALL FIXTURE TYPES WITH LIGHTING PHOTOMETRY PLANS AND SCHEDULES. VERIFY ALL PROVISIONS WITH OWNER PRIOR TO ORDERING.



Reviewed for Code Compliance
With The Florida Building Code
ECS, Florida LLC
41-**EXISTING PANEL C**

LOCATION: BLDG 1		VOLTAGE: 208Y/120 V 3Ø 4W				MIN. AIC RATING: 10K AIC		NOTES:				
TYPE: SQUARE D		MAINS: 100 A ☒ MLO ☐ MCB				MOUNTING: SURFACE		PROVIDE TYPED WRITTEN DIRECTORY				
FED FROM: 100A SERVICE DISC SW		LUGS: ☐ SUB-FEED ☐ FEED-THRU				ENCLOSURE: NEMA 1		PROVIDE GROUND & NEUTRAL BUS				
CCT.	CIRCUIT DESCRIPTION	NOTES	BRANCH CIRCUIT ● NEUT GND COND	BKR	LOAD KVA	PHASE Φ	LOAD KVA	BKR	BRANCH CIRCUIT ● NEUT GND COND	NOTES	CIRCUIT DESCRIPTION	CCT.
1	BATTERY CHARGER			20/1	1.90	A	1.90	20/1			VERIFY EXISTING LOAD SERVED	2
3	BATTERY CHARGER			20/1	1.90	B	1.90	20/1			VERIFY EXISTING LOAD SERVED	4
5	RECEPTACLE MTD ON LIFT			20/1	0.36	C	1.90	20/1			VERIFY EXISTING LOAD SERVED	6
7	CHEMICAL MIXER BUILDING			30/2	2.00	A	2.88	30/3			AIR COMPRESSOR	8
9	--			--	2.00	B	2.88	--			--	10
11	SPACE			-/2	--	C	2.88	--			--	12
13	--			--	--	A	1.60	20/2			LIFT	14
15	ICE MACHINE 'B'			20/2	1.60	B	1.60	--			--	16
17	--			--	1.60	C	1.60	20/2			ICE MACHINE 'A'	18
19	SPACE			-/2	--	A	1.60	--			--	20
21	--			--	--	B	--	-/2			SPACE	22
23	SPACE			-/1	--	C	--	--			--	24
EQUIPMENT SERVED				CONN. LOAD		L.F.	D.F.	DEMAND LOAD				
LIGHTING				0.00 KVA			125%	0.00 KVA				
RECEPTACLES - GENERAL				9.86 KVA			100%	9.86 KVA				
EQUIPMENT				22.24 KVA			100%	22.24 KVA				
NOTES										TOTAL DEMAND LOAD: 32.10 KVA		
										TOTAL DEMAND AMPS: 89.10 AMPS		

A

PANEL P																			
LOCATION: UTILITY ROOM		VOLTAGE: 120/240 V				1 Ø 3W		MIN. AIC RATING:		65K AIC SURFACE		NOTES: PROVIDE TYPED WRITTEN DIRECTORY PROVIDE GROUND & NEUTRAL BUS							
TYPE: SQUARE-D "NQ"		MAINS: 600 A				☒ MLO ☐ MCB		MOUNTING:		ENCLOSURE:									
FED FROM: MAIN DISC SWITCH		LUGS: ☐ SUB-FEED ☐ FEED-THRU								NEMA 1									
CCT.	CIRCUIT DESCRIPTION	NOTES	BRANCH CIRCUIT		BKR	LOAD KVA	PHASE Φ	LOAD KVA	BKR	BRANCH CIRCUIT		NOTES	CIRCUIT DESCRIPTION	CCT.					
			NEUT	GND COND						NEUT	GND COND								
1	STORAGE LIGHTING	1	12	12	12	12"	20/1	1.00	A	4.15	50/2	6	6	8	1"	AIR COMPRESSOR	2		
3	STORAGE LIGHTING	1	12	12	12	12"	20/1	1.20	B	4.15	6	6	8	8			4		
5	BREAKROOM LIGHTING	1	12	12	12	12"	20/1	1.00	A	1.50	20/1	12	12	12	12"	RESTROOM RECEPTACLE	6		
7	BREAKROOM LIGHTING	1	12	12	12	12"	20/1	1.00	B	0.84	20/1	12	12	12	12"	FRIDGE	8		
9	EXTERIOR LIGHTING	1	12	12	12	12"	20/1	0.50	A	0.84	20/1	12	12	12	12"	FRIDGE	10		
11	MICROWAVE/HOOD		12	12	12	12"	20/1	1.20	B	4.00		40/2	8	8	10	1"	RANGE	12	
13	MICROWAVE/HOOD		12	12	12	12"	20/1	1.20	A	4.00							14		
15	MICROWAVE/HOOD		12	12	12	12"	20/1	1.20	B	0.72	20/1	12	12	12	12"	STORAGE RECEPTACLES	16		
17	MICROWAVE/HOOD		12	12	12	12"	20/1	1.20	A	0.72	20/1	12	12	12	12"	STORAGE RECEPTACLES	18		
19	FRIDGE		12	12	12	12"	20/1	0.84	B	4.00		40/2	8	8	10	1"	RANGE	20	
21	FRIDGE		12	12	12	12"	20/1	0.84	A	4.00			8	8	10	1"	RANGE	22	
23	FRIDGE		12	12	12	12"	20/1	0.84	B	4.00		40/2	8	8	10	1"	RANGE	24	
25	WATER FOUNTAIN		12	12	12	12"	20/1	1.50	A	4.00			8	8	10	1"	RANGE	26	
27	GARBAGE DISPOSAL		12	12	12	12"	20/1	1.50	B	4.00		40/2	8	8	10	1"	RANGE	28	
29	DISHWASHER/DISPOSAL		12	12	12	12"	20/1	1.50	A	4.00			8	8	10	1"	RANGE	30	
31	DISHWASHER/DISPOSAL		12	12	12	12"	20/1	1.50	B	1.50	20/1	12	12	12	12"	BREAKROOM RECEPTACLES	32		
33	COMMON AREA LIGHTING	1	12	12	12	12"	20/1	1.20	A	1.50	20/1	12	12	12	12"	BREAKROOM RECEPTACLES	34		
35	COMMON AREA LIGHTING	1	12	12	12	12"	20/1	1.20	B	2.25		30/2	10	10	10	3/4"	EWI-2	36	
37	DISHWASHER/DISPOSAL		12	12	12	12"	20/1	1.50	A	2.25								38	
39	DISHWASHER		12	12	12	12"	20/1	1.20	B	2.25		30/2	10	10	10	3/4"	EWI-3	40	
41	FRIDGE		12	12	12	12"	20/1	0.84	A	2.25								42	
43	FRIDGE		12	12	12	12"	20/1	0.84	B	3.00		40/2	8	8	10	1"	INDUCTION COOKER	44	
45	COMMON AREA RECEPTACLE		12	12	12	12"	20/1	0.72	A	3.00								46	
47	RESTROOM RECEPTACLE		12	12	12	12"	20/1	0.72	B	2.50		30/2	10	10	10	3/4"	DRYER	48	
49	RESTROOM RECEPTACLE		12	12	12	12"	20/1	0.72	A	2.50								50	
51	ROOM RECEPTACLE		12	12	12	12"	20/1	0.54	B	1.50	20/1	12	12	12	12"	WASHER	52		
53	ROOM RECEPTACLE		12	12	12	12"	20/1	0.54	A	2.50		30/2	10	10	10	3/4"	DRYER	54	
55	ROOM RECEPTACLE		12	12	12	12"	20/1	0.54	B	2.50			10	10	10	3/4"	DRYER	56	
57	ROOM RECEPTACLE		12	12	12	12"	20/1	0.54	A	1.50	20/1	12	12	12	12"	WASHER	58		
59	ROOM RECEPTACLE		12	12	12	12"	20/1	0.54	B	5.37			4	4	8	1 1/4"	AHU-4.1	60	
61	ROOM RECEPTACLE		12	12	12	12"	20/1	0.54	A	5.37		60/2	4	4	8	1 1/4"	AHU-4.1	62	
63	ROOM RECEPTACLE		12	12	12	12"	20/1	0.54	B	5.37			4	4	8	1 1/4"	AHU-4.2	64	
65	ROOM RECEPTACLE		12	12	12	12"	20/1	0.54	A	5.37		60/2	4	4	8	1 1/4"	AHU-4.2	66	
67	RESTROOM RECEPTACLE		12	12	12	12"	20/1	0.72	B	5.37		60/2	4	4	8	1 1/4"	AHU-4.3	68	
69	RESTROOM RECEPTACLE		12	12	12	12"	20/1	0.72	A	5.37			4	4	8	1 1/4"	AHU-4.3	70	
71	SPARE						20/1		B			20/1					SPARE	72	
73	SPARE						20/1		A			20/1					SPARE	74	
75	SPARE						20/1		B			20/1					SPARE	76	
77	SPARE						20/1		C			20/1					SPARE	78	
79	SPARE						20/1		A			20/1					SPARE	80	
81	SPARE						20/1		B			20/1					SPARE	82	
83	SPARE						20/1		A			20/1					SPARE	84	
85	CU-1.1 (NON-CONCURRENT)		6	6	8	1"	50/2	3.23	B	4.22		50/2	6	6	8	1"	AHU-4.4	86	
87	CU-1.1 (NON-CONCURRENT)		6	6	8	1"	50/2	3.23	A	4.22			6	6	8	8		88	
89	CU-1.2 (NON-CONCURRENT)		6	6	8	1"	50/2	3.23	B	4.22		50/2	6	6	8	1"	AHU-4.5	90	
91	CU-1.2 (NON-CONCURRENT)		6	6	8	1"	50/2	3.23	A	4.22			6	6	8	8		92	
93	CU-1.3 (NON-CONCURRENT)		6	6	8	1"	50/2	3.23	B	4.22		50/2	6	6	8	1"	AHU-4.6	94	
95	CU-1.3 (NON-CONCURRENT)		6	6	8	1"	50/2	3.23	A	4.22			6	6	8	8		96	
97	CU-1.4 (NON-CONCURRENT)		6	6	8	1"	50/2	3.06	B			20/2					SPARE	98	
99	CU-1.4 (NON-CONCURRENT)		6	6	8	1"	50/2	3.06	A								SPARE	100	
101	CU-1.5 (NON-CONCURRENT)		6	6	8	1"	50/2	3.06	B			30/2					SPARE	102	
103	CU-1.5 (NON-CONCURRENT)		6	6	8	1"	50/2	3.06	A								SPARE	104	
105	CU-1.6 (NON-CONCURRENT)		6	6	8	1"	50/2	3.06	B			50/2					SPARE	106	
107	CU-1.6 (NON-CONCURRENT)		6	6	8	1"	50/2	3.06	A								SPARE	108	
109	SPACE								B								SPACE	110	
111	SPACE								A								SPACE	112	
113	SPACE								B								SPACE	114	
115	SPACE								A								SPACE	116	
117	SPACE								B								SPACE	118	
119	SPACE								A								SPACE	120	
121	SPACE								B								SPACE	122	
123	SPACE								A								SPACE	124	
125	SPACE								B								SPACE	126	
EQUIPMENT SERVED										CONN. LOAD		D.F.		DEMAND LOAD					
LIGHTING										7.10 KVA		125%		8.88 KVA					
RECEPTACLES - GENERAL										12.42 KVA		**		11.21 KVA		**FIRST 10KVA + 50% OF REMAINING			
EQUIPMENT										64.00 KVA		100%		64.00 KVA					
COOLING										0.00 KVA		100%		0.00 KVA					
KITCHEN										57.32 KVA		65%		37.26 KVA					
NOTES:												TOTAL DEMAND LOAD:		121.34 KVA					
1) ROUTE CIRCUIT THRU CONTACTOR FOR AUTOMATIC CONTROL OF LIGHTING, SEE DETAIL E7.01.												TOTAL DEMAND AMPS:		505.59 AMPS					

Product Information

Firestop Putty Pad
(CP 617, CP 617L and CP 617XL)


Product description
■ A moldable firestop putty designed to help protect electrical outlet boxes.

Product features
■ Applied by hand
■ Fast installation

Areas of application
■ Protection of electrical outlet boxes

For use with
■ Gypsum wall assemblies with wood or metal studs

Examples
■ Where two outlets are within a single stud/cavity or within 24" measured horizontally (not back to back unless specified by the specific UL approval)

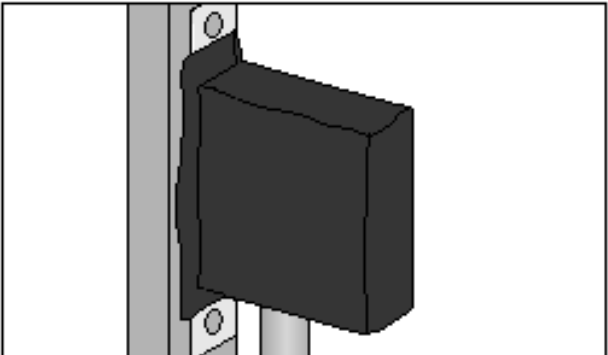

Technical Data*	CP 617
Dimensions (LxWxH)	CP 617: 6" x 7" x 1/8" (15 x 18 x 0.3 cm) CP 617L: 7" x 7" x 1/8" (18 x 18 x 0.3 cm) CP 617XL: 9" x 9" x 1/8" (23 x 23 x 0.3 cm)
Consistency	Moldable putty
Use	Real
Color	Gray
Application temperature	40°F (5°C) to 95°F (35°C)
Storage temperature	40°F (5°C) to 104°F (40°C)
Curing time	Non-curing
Density	1.48 g/cm³
Flame retardant activation	Approx. 320°F to 325°F (154°C to 121°C)
Volatiles solvents	None
Adhesive fibers	None
Surface burning characteristics (ASTM E 84-05)	Flame Spread: 15 Smoke development: 10
Sealant transmission classification (ASTM E 96-97)	99 (Plastic to specific construction)
Tested in accordance with	UL 253, ASTM E 84, ASTM E 81
	*At 70°F (21°C) and 50% relative humidity



Installation instructions for CP 617

Notes:
• Before handling, read Material Safety Data Sheet and product label for safe usage and health information.
• Instructions below are general guidelines — always refer to the applicable listing (CLN) in the UL Fire Resistance Directory or Hilti Firestop Systems Guide for complete installation information.

Application of firestop putty:
1. After annular hole is cleaned of loose debris, dirt, oil, moisture, frost and wax, remove label from one side of pad. For a 1 to 1 hour fire rating, one CP 617 pad is required. Exposed side of pad is placed against box.
2. CP 617 Firestop Putty Pads are to be installed to completely cover the exterior surfaces of the outlet box (except for the side of the outlet box against the

stud) and completely seal against the stud within the stud cavity.




3. Reshape CP 617 to fit around conduit or cable.
4. Press CP 617 to all sides of electrical box.
5. Remove other side of label.

Not for use:
• In areas exposed to water.
Storage:
• Store only in the original packaging in a location at temperature: 40°F (5°C) to 104°F (40°C)



Hilti. Outperform. Outlast.

Hilti, Inc. (U.S.) 1-800-875-8000 • www.us.hilti.com • en español 1-800-875-5000 • Hilti Firestop Systems Guide

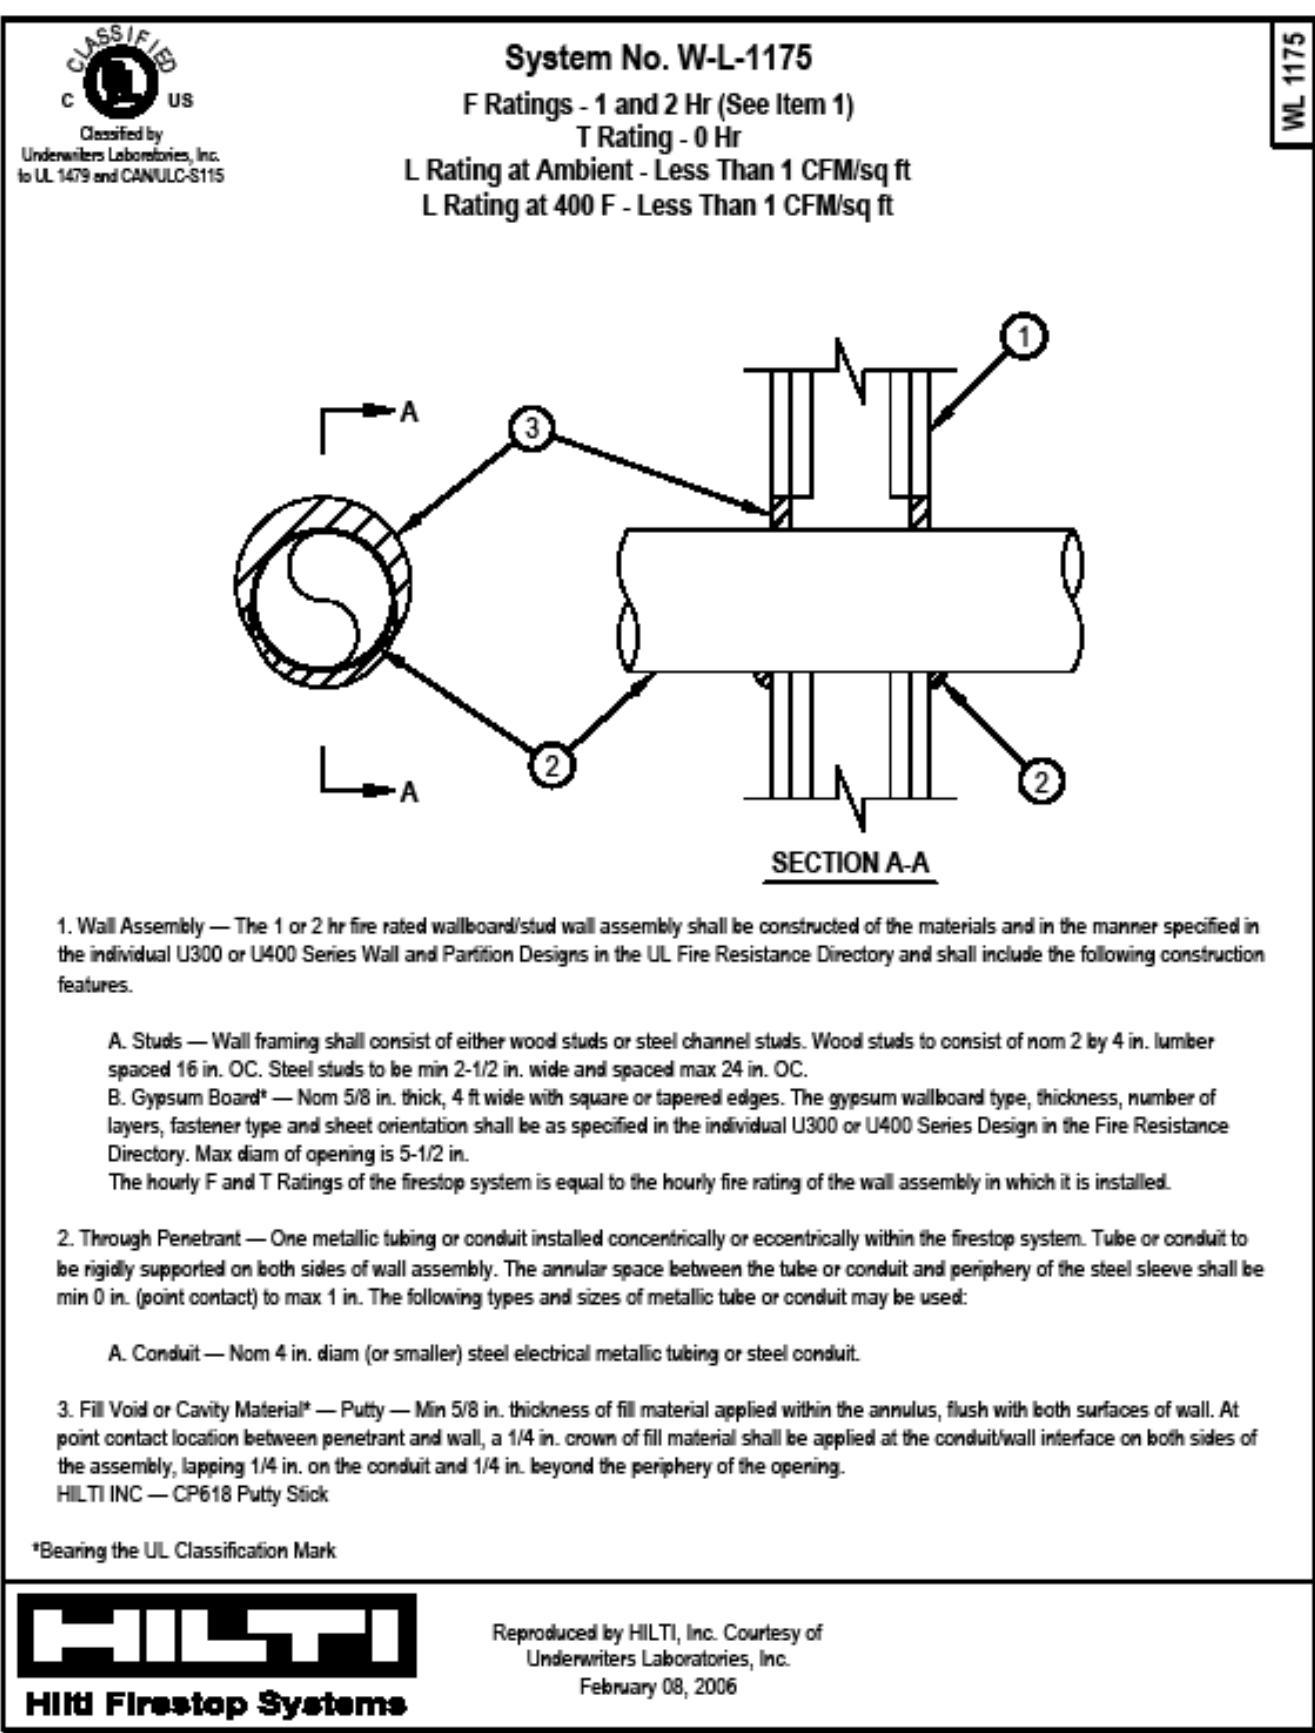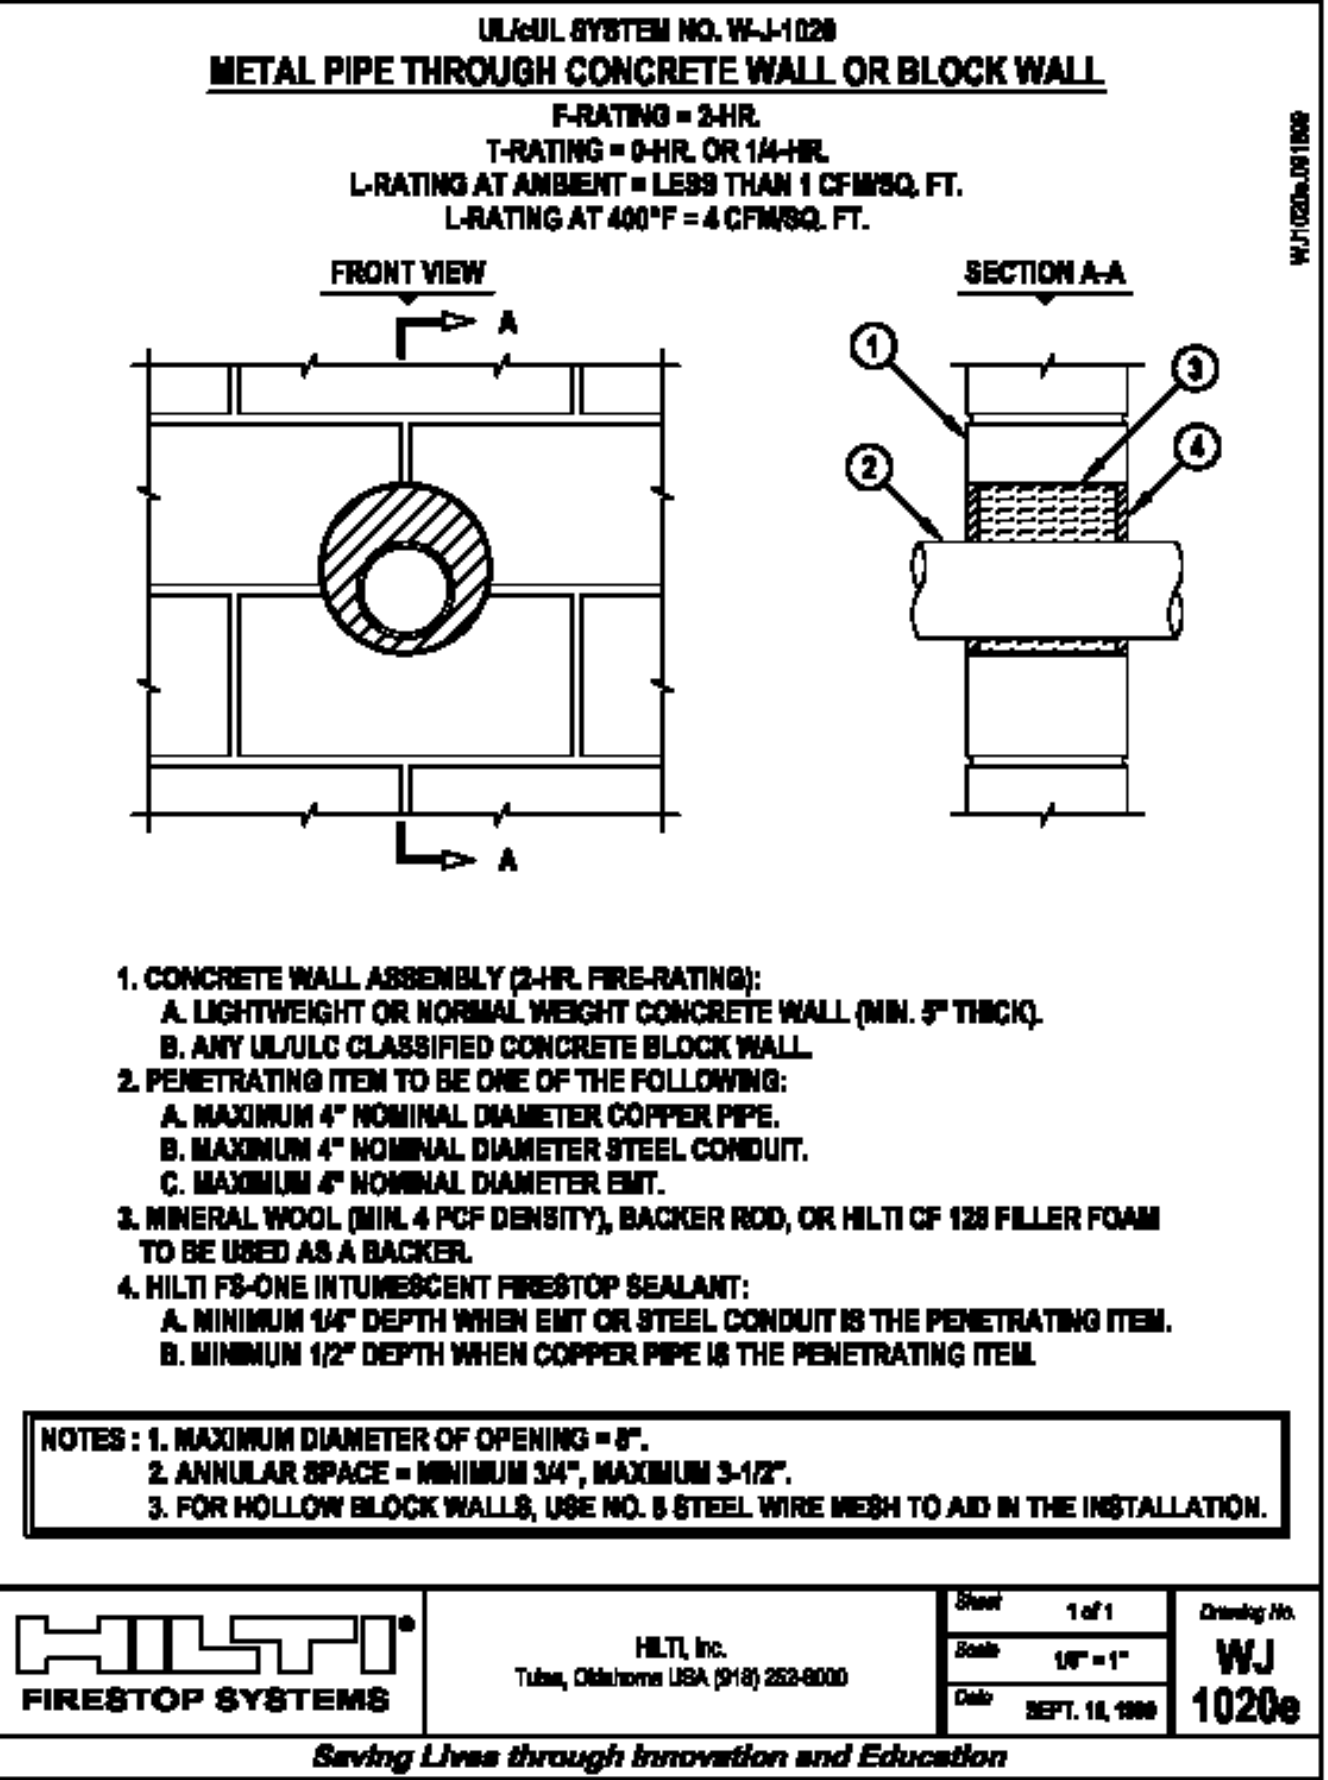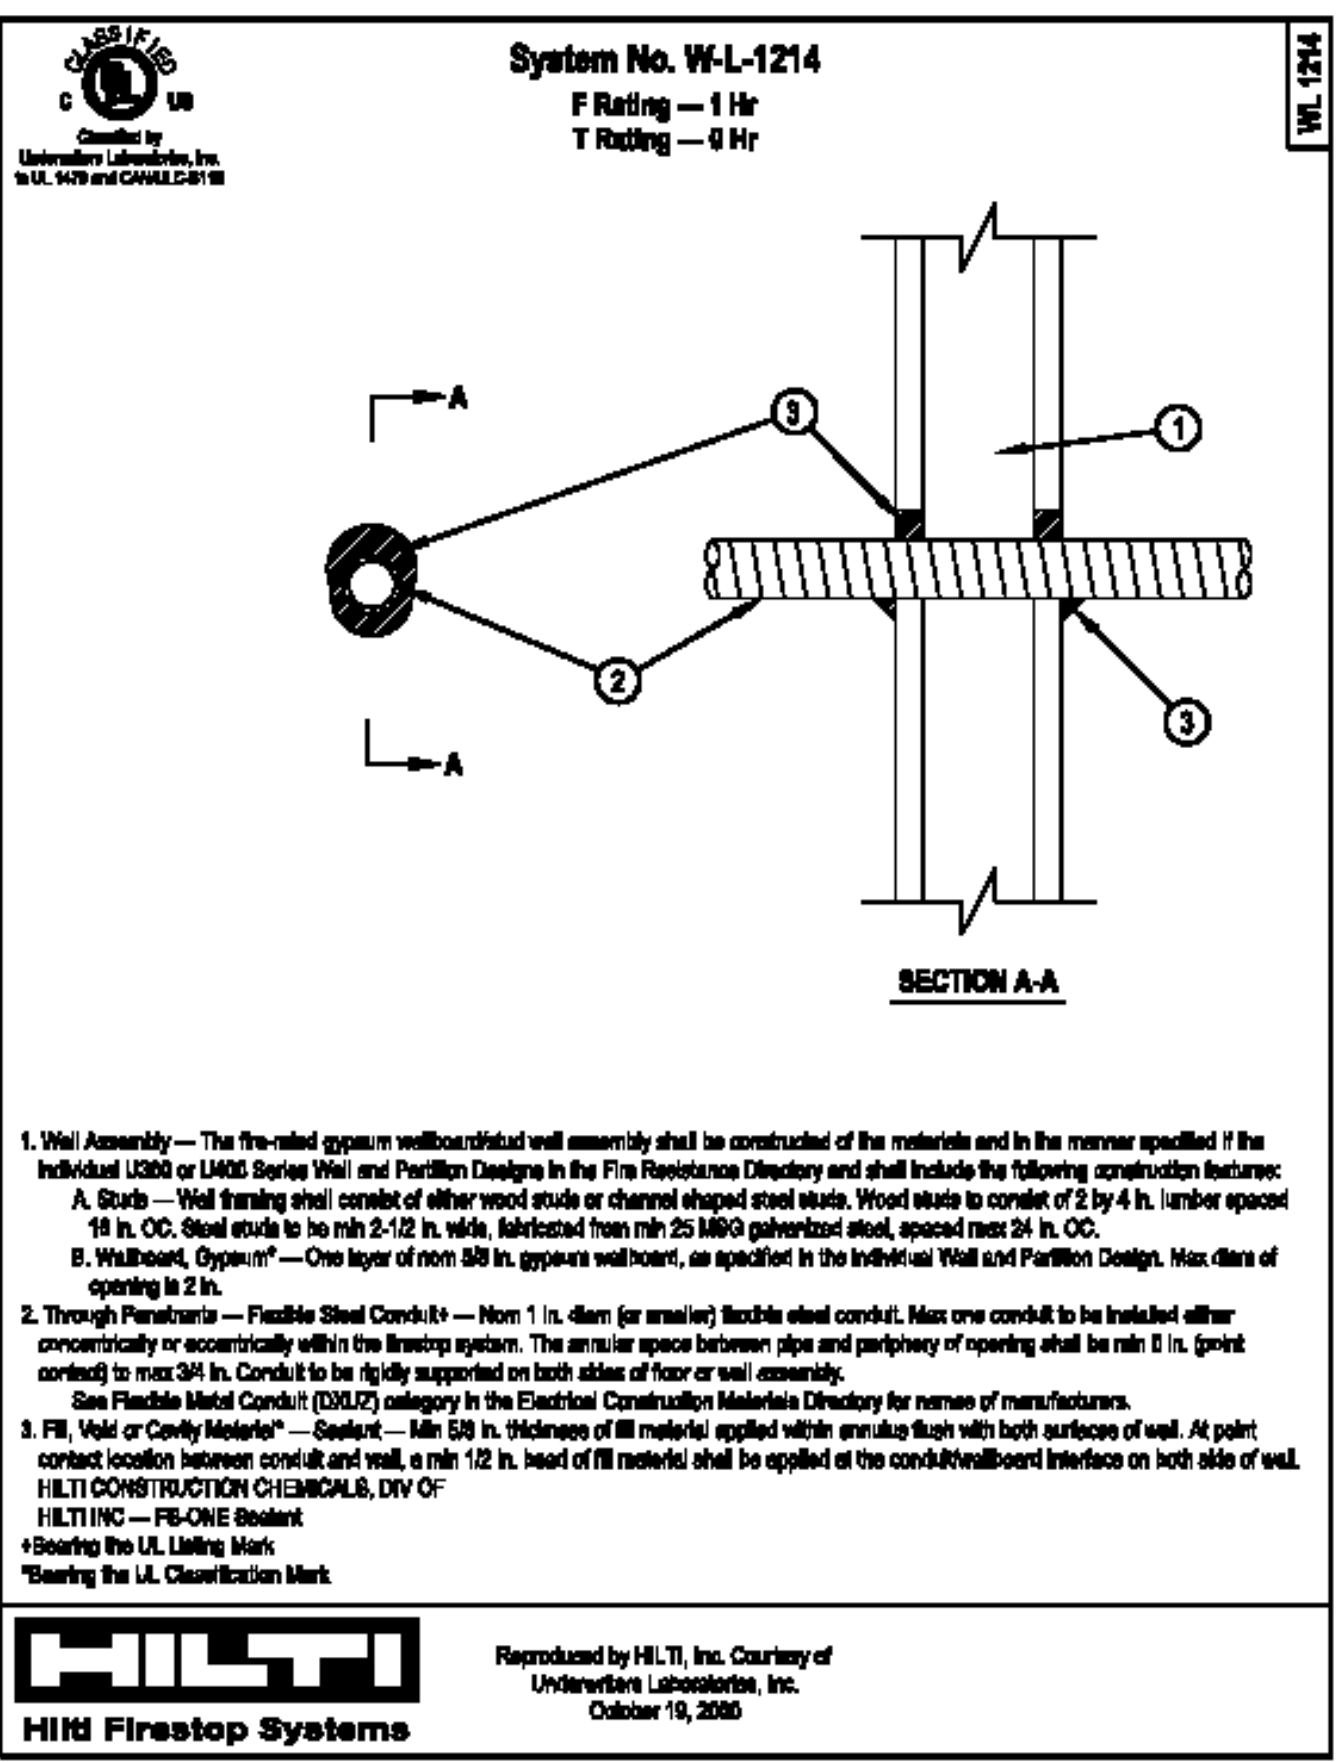


4 FIRE STOP PUTTY PAD DETAIL - WOOD FRAMING
NTS


3 UL FIRE RATED DETAIL (W-L-1214)
NTS

2 UL FIRE RATED DETAIL (W-J-1020)
NTS


1 UL FIRE RATED DETAIL (W-L-1175)
NTS

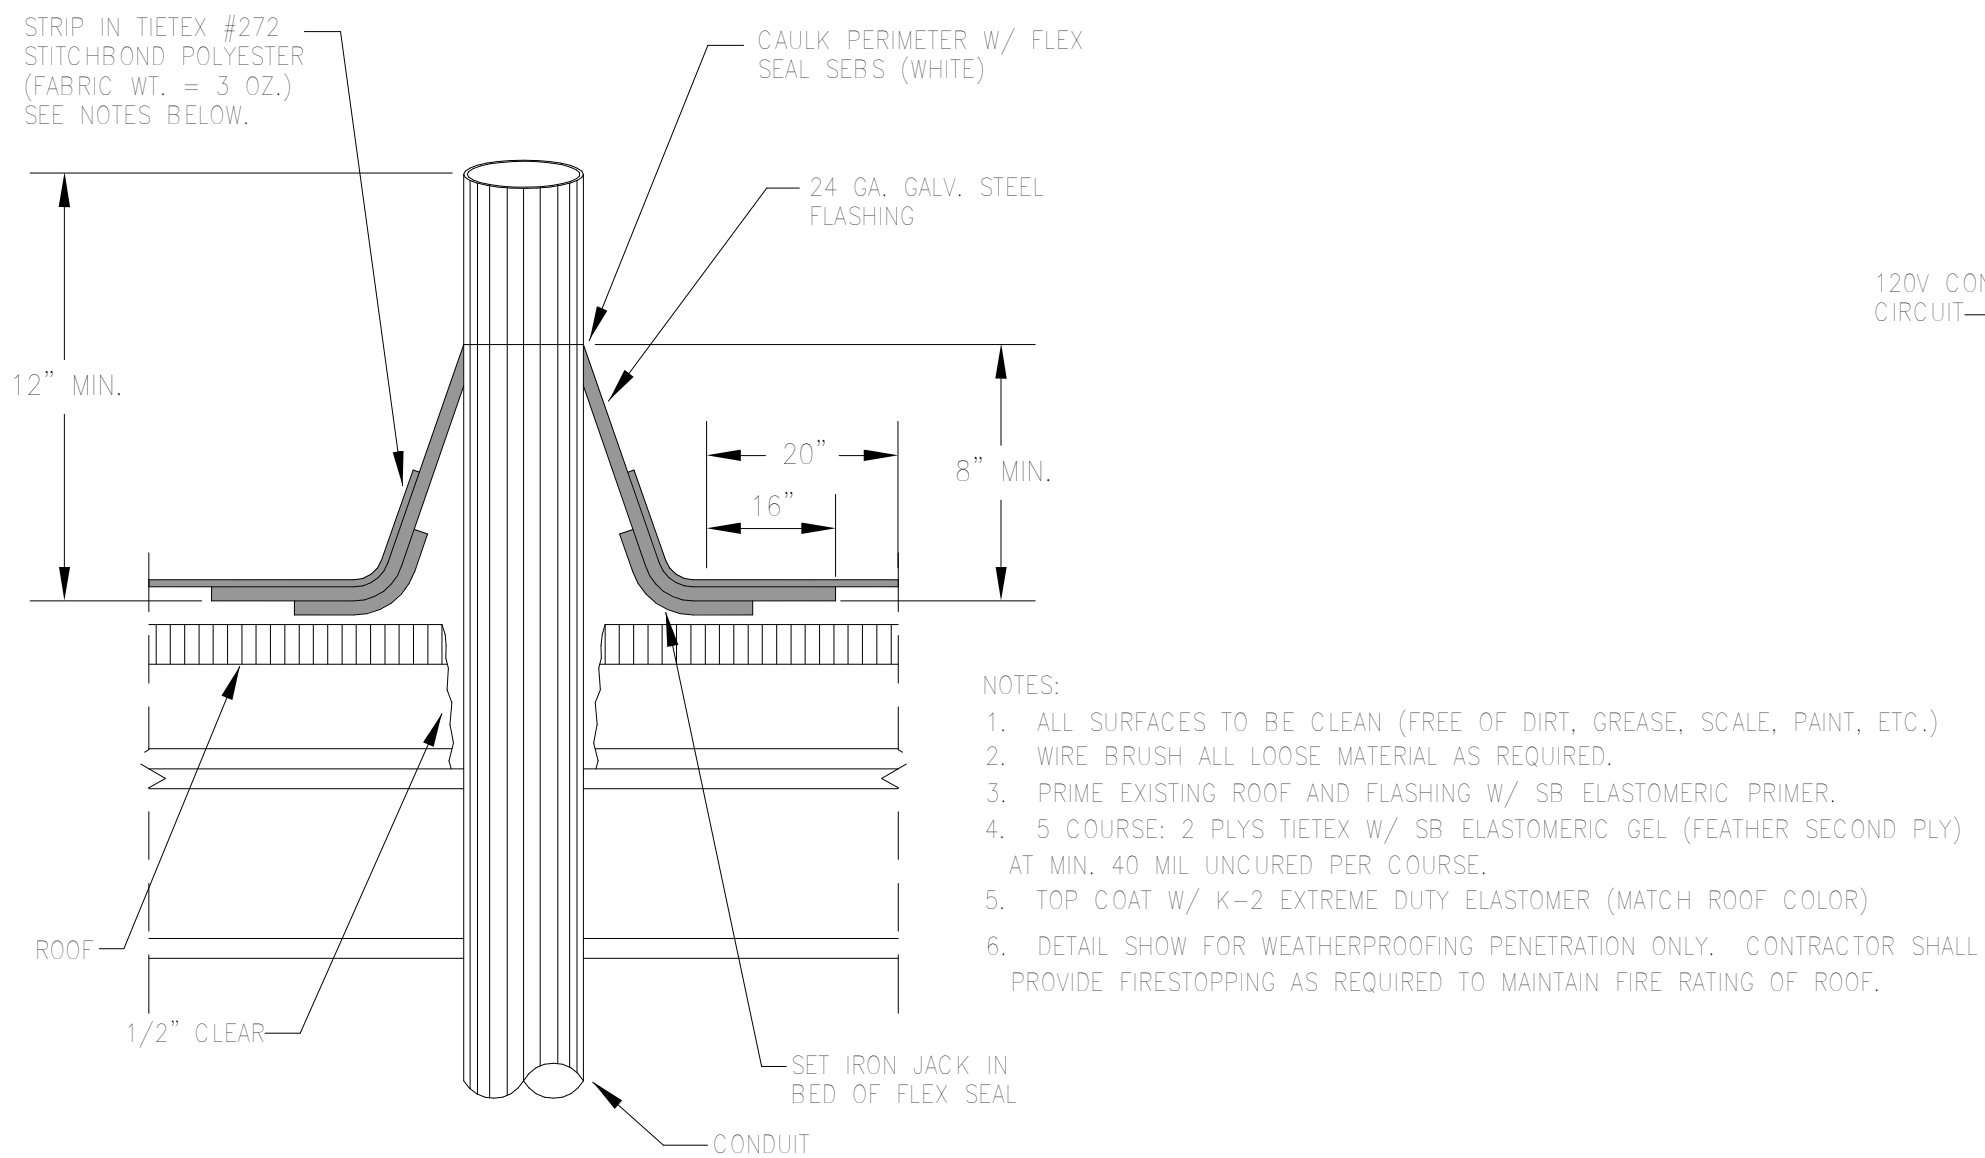

5 ROOF PENETRATION WEATHERPROOF DETAIL
NTS

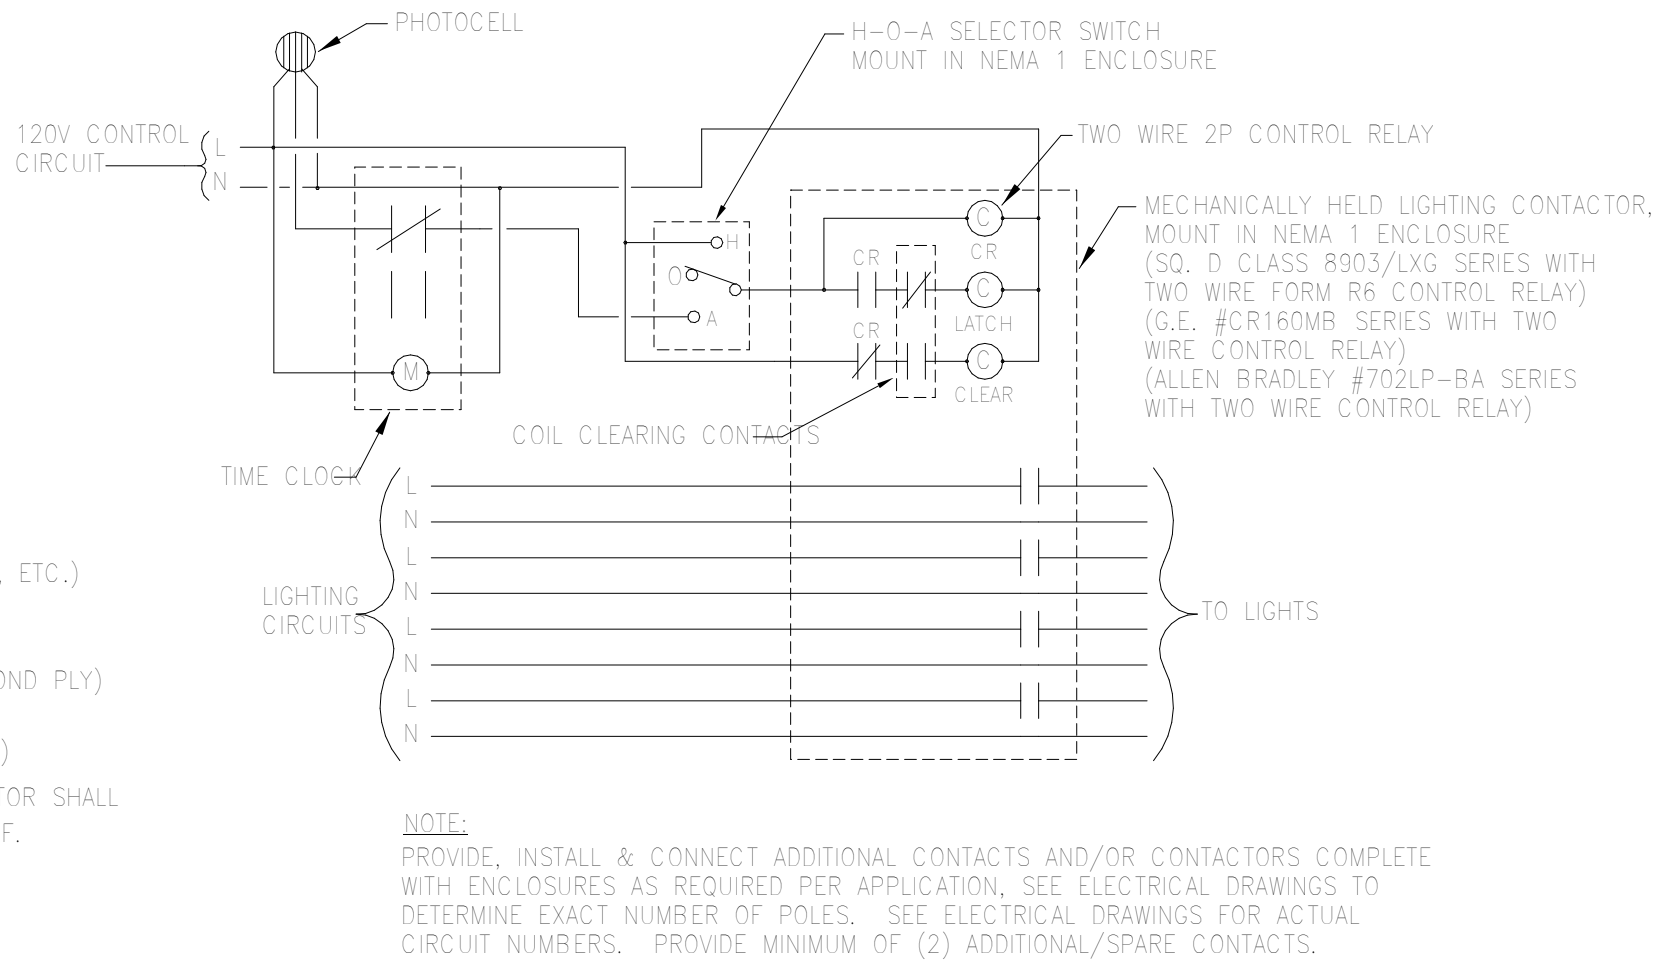

6 CONTACTOR 'LC1' SCHEMATIC - PHOTOCELL & TIMECLOCK CONTROLLED
NTS

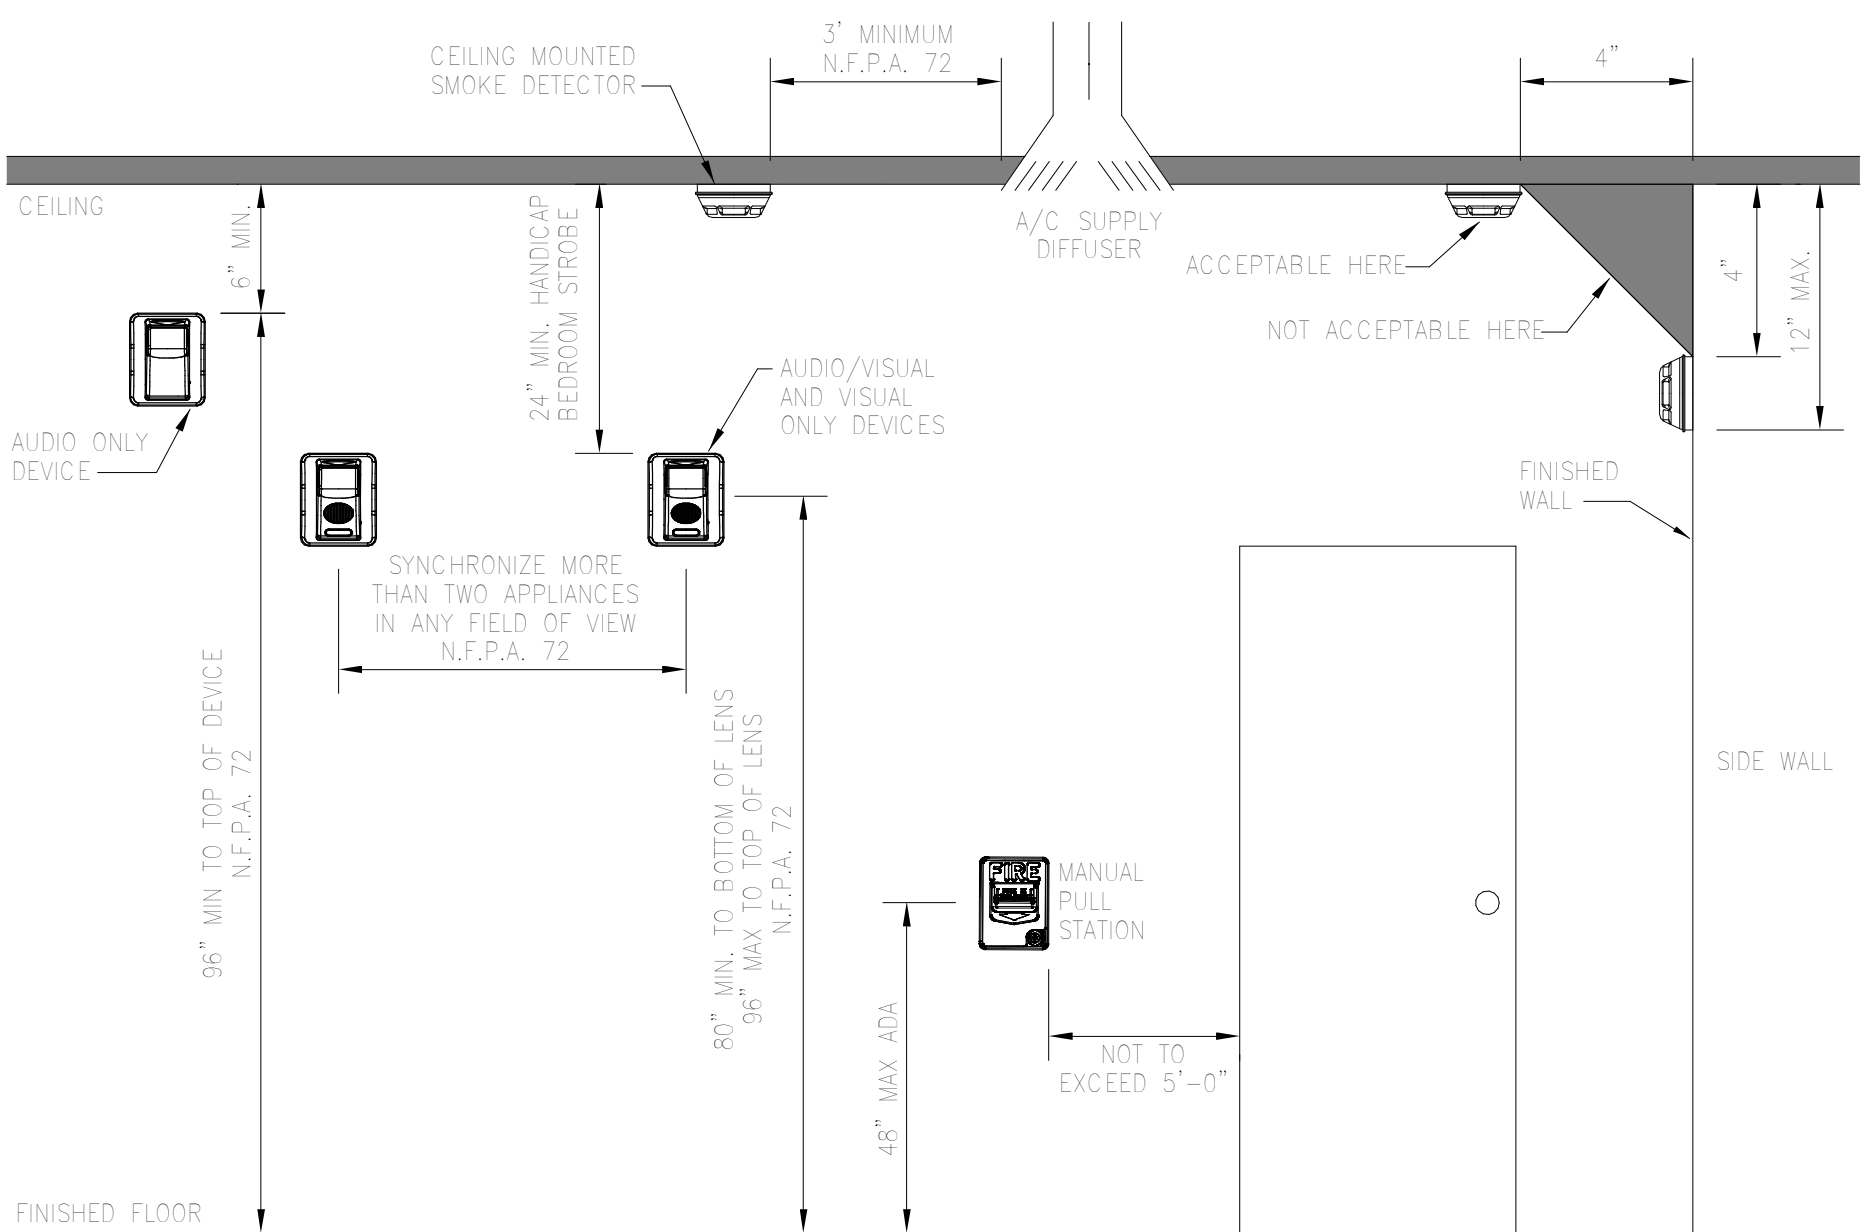


7 STANDARD MOUNTING HEIGHT DETAIL
NTS

OLD MEMORIAL

13600 National Golf Dr
Tampa, FL 33626

no.	description	date
PERMIT SET		04.24.26

E7.01
ELECTRICAL
DETAILS

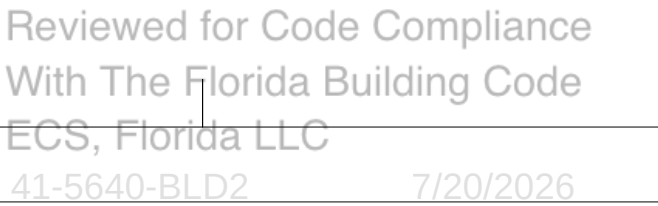

Electrical Review - Roger Sanders PX651 - Reviewed - 7/14/2026


Mechanical Review - Roger Sanders PX651 - Reviewed - 7/14/2026

Plumbing Review - Roger Sanders PX651 - Reviewed - 7/14/2026

Fire Review - Jay Traina - NA to Private Provider - 7/16/2026

Building Review - Roger Sanders PX651 - Reviewed - 7/14/2026

sheet size 24" x 36

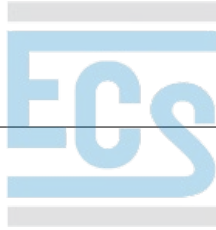


Reviewed for Code Compliance
With The Florida Building Code
ECS, Florida LLC
41-5640-BLD2 7/20/2026

Electrical Review - Roger Sanders PX651 - Reviewed - 7/14/2026
Mechanical Review - Roger Sanders PX651 - Reviewed - 7/14/2026
Plumbing Review - Roger Sanders PX651 - Reviewed - 7/14/2026
Fire Review - Jay Traina - NA to Private Provider - 7/16/2026
Building Review - Roger Sanders PX651 - Reviewed - 7/14/2026

LAFATE WILSON
a r c h i t e c t s

1030 arlington ave n, st petersburg fl 33705
(727) 490-9483
studio@lafatewilson.com

THE ARCHITECT'S COMMON LAW COPYRIGHT AND OTHER
PROPERTY RIGHTS ARE HEREBY RESERVED IN THE IDEAS, DESIGNS,
PLANS, DRAWINGS, AND SPECIFICATIONS SHALL NOT BE
REPRODUCED OR CONVEYED IN ANY MANNER NOR ASSIGNED TO
ANY THIRD PARTY WITHOUT FIRST OBTAINING THE EXPRESS
WRITTEN PERMISSION OF THE ARCHITECT.

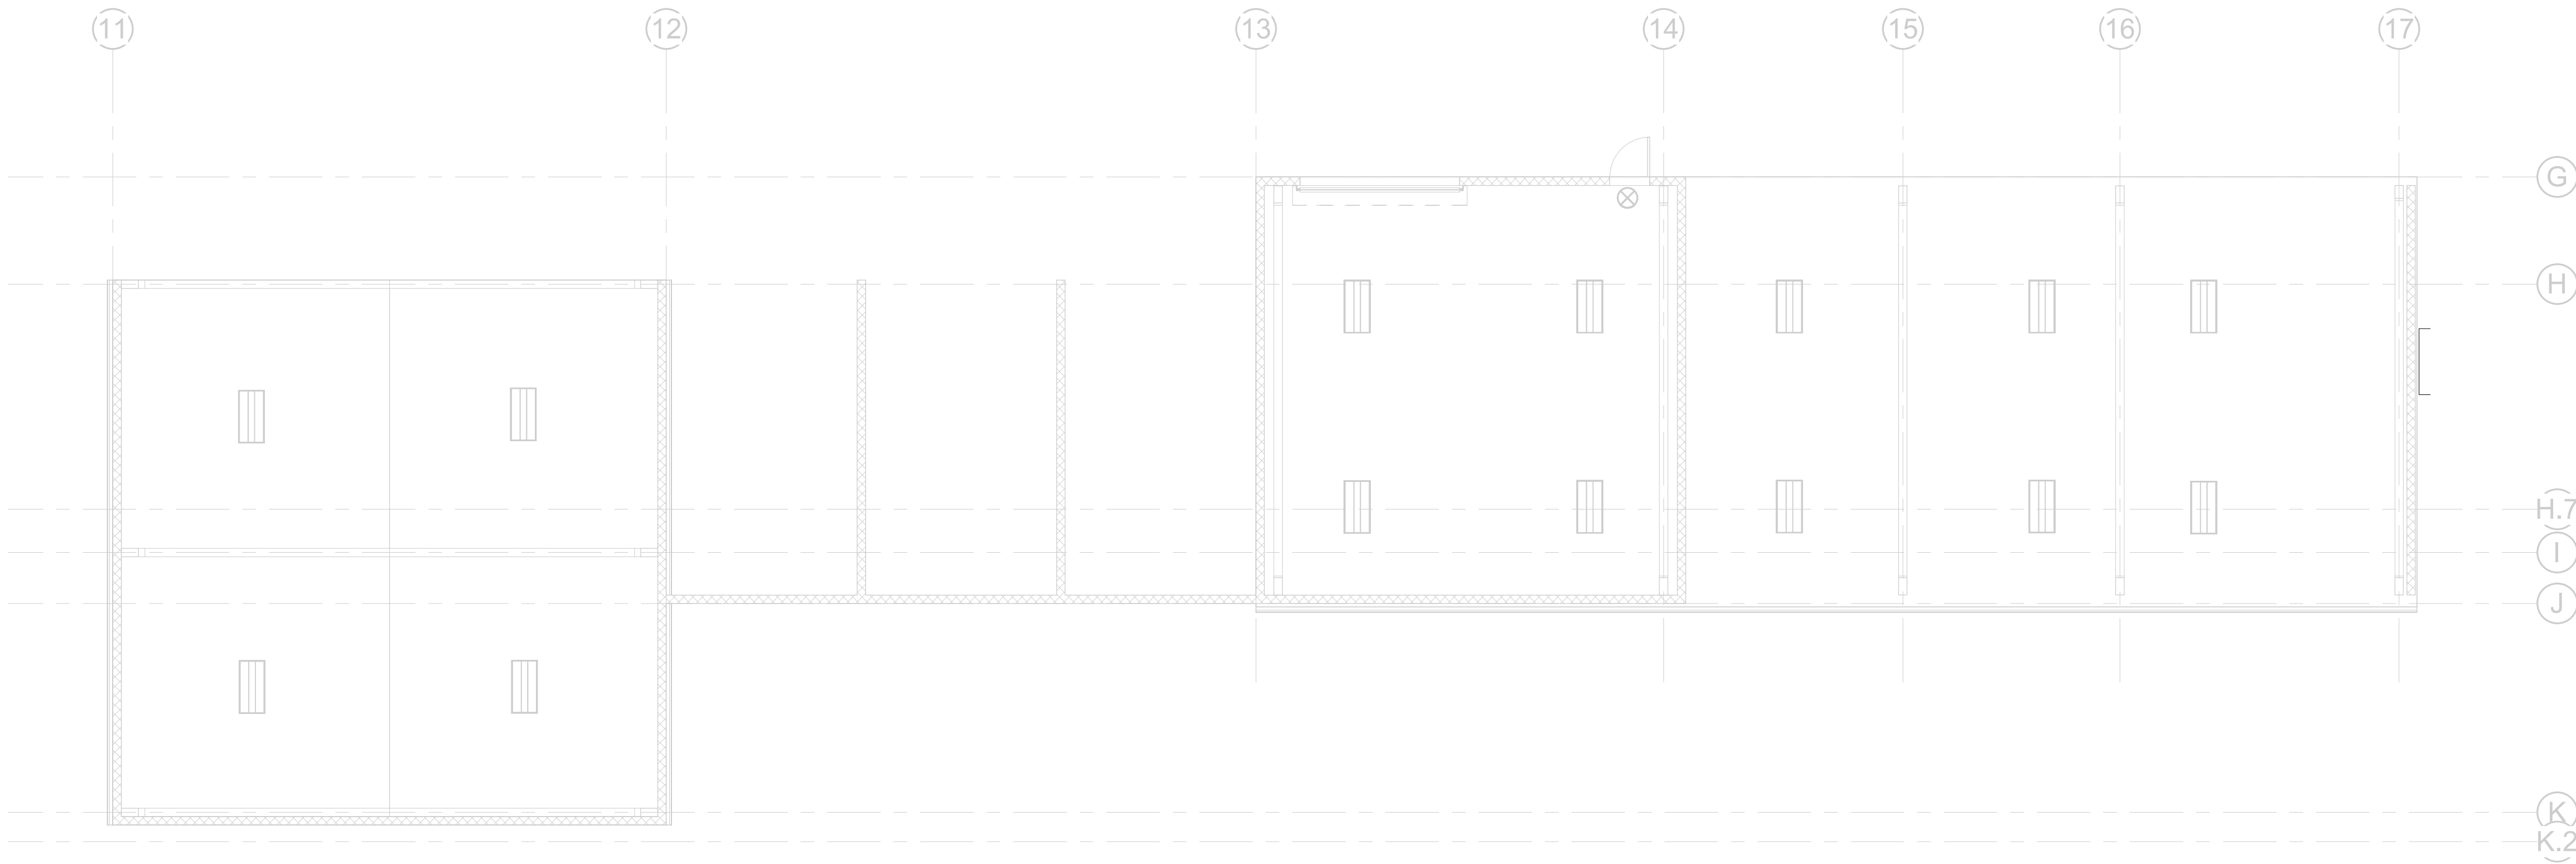




1 SAND AND CHEM STORAGE FLOOR PLAN - MECHANICAL
1/8" = 1'-0"

OLD MEMORIAL

13600 National Golf Dr
Tampa, FL 33626

no.	description	date
1	PERMIT SET	04.24.26

M1.02.1
BUILDING 2 FIRST
FLOOR PLAN -
MECHANICAL

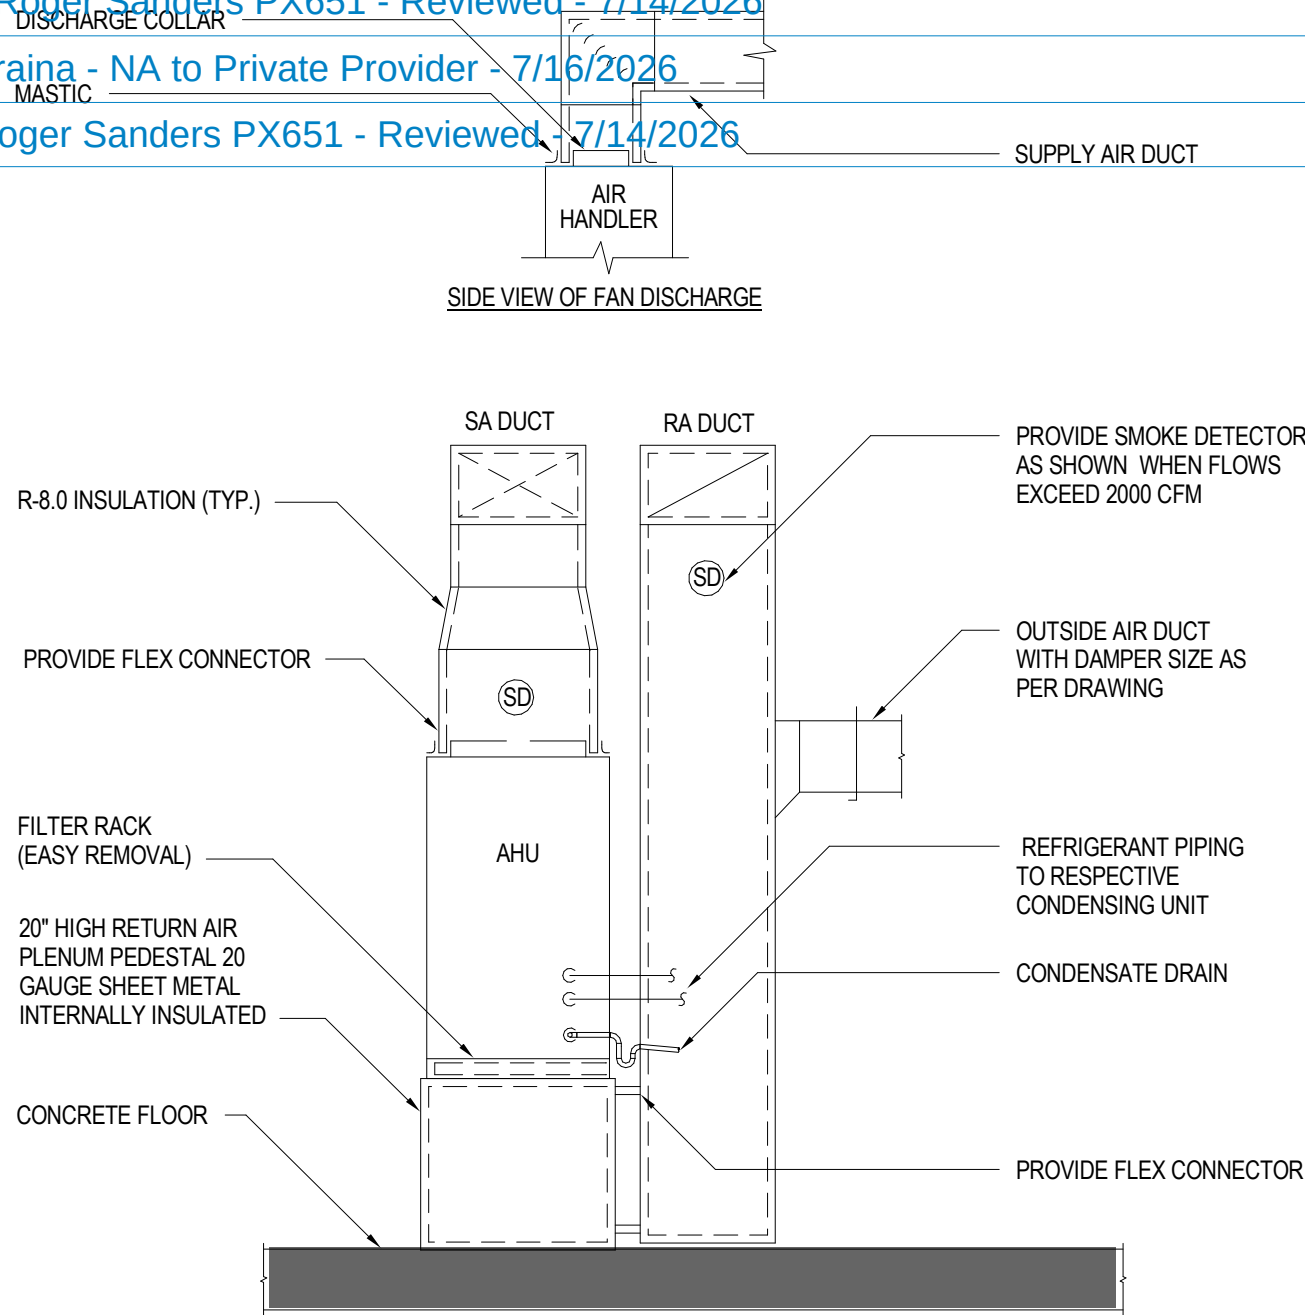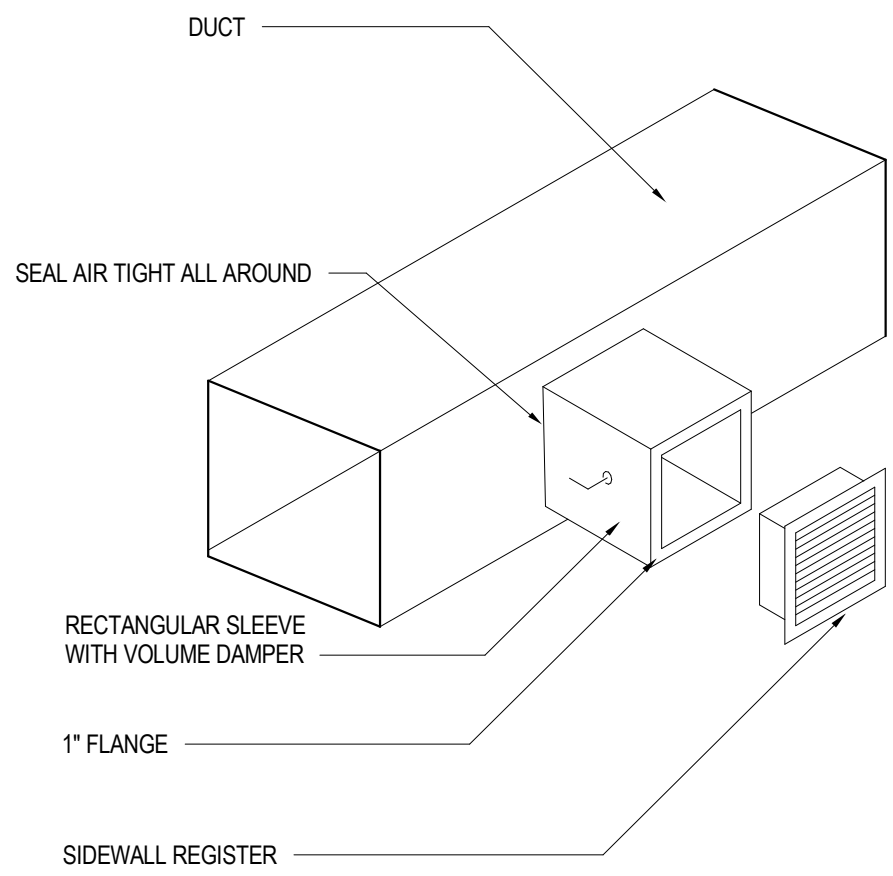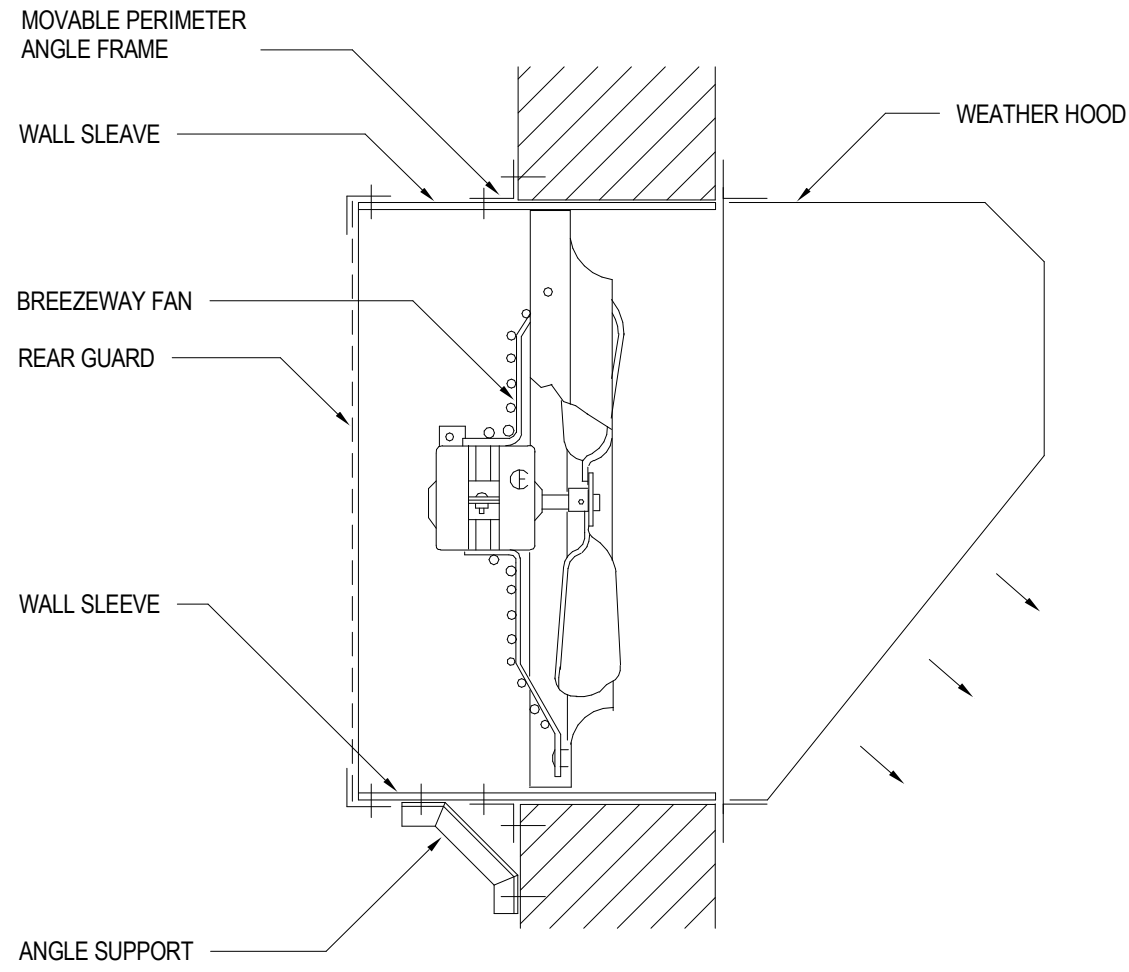

WALL MOUNTED BREEZEWAY FAN DETAIL




I

SIDEWALL GRILLE DUCT CONNECTION

F

VERTICAL AIR HANDLER DIAGRAM

C

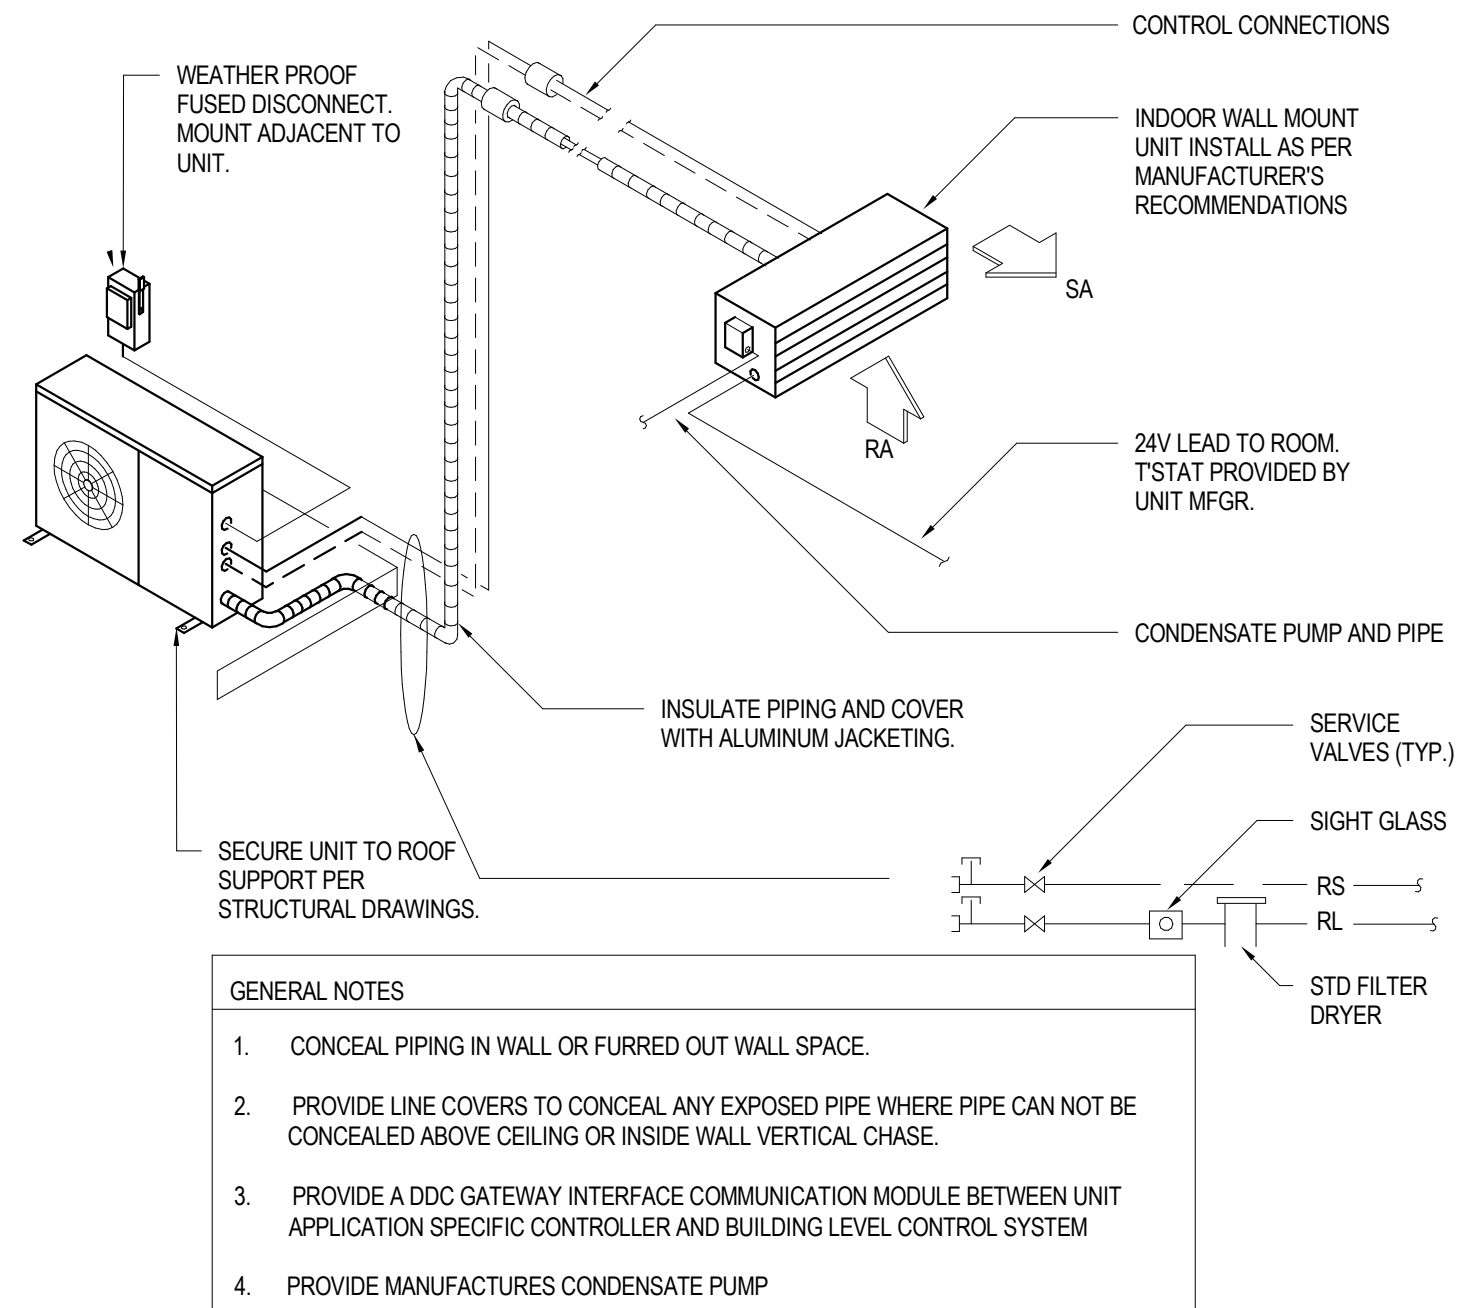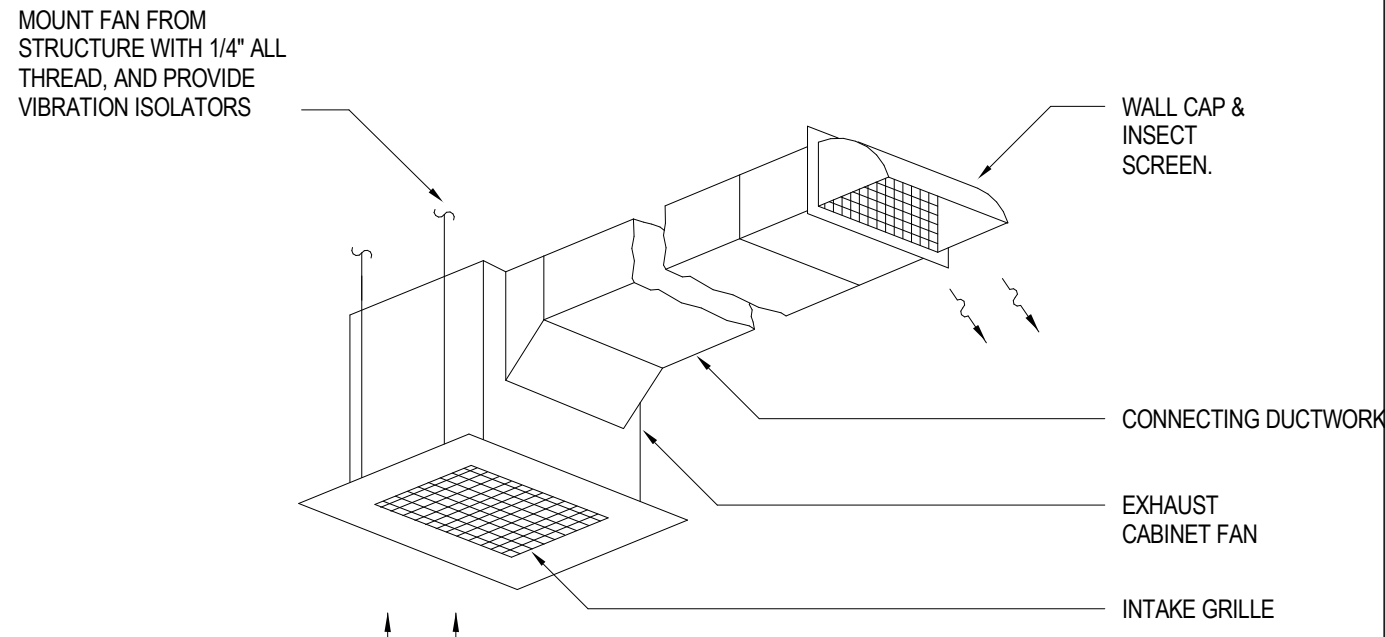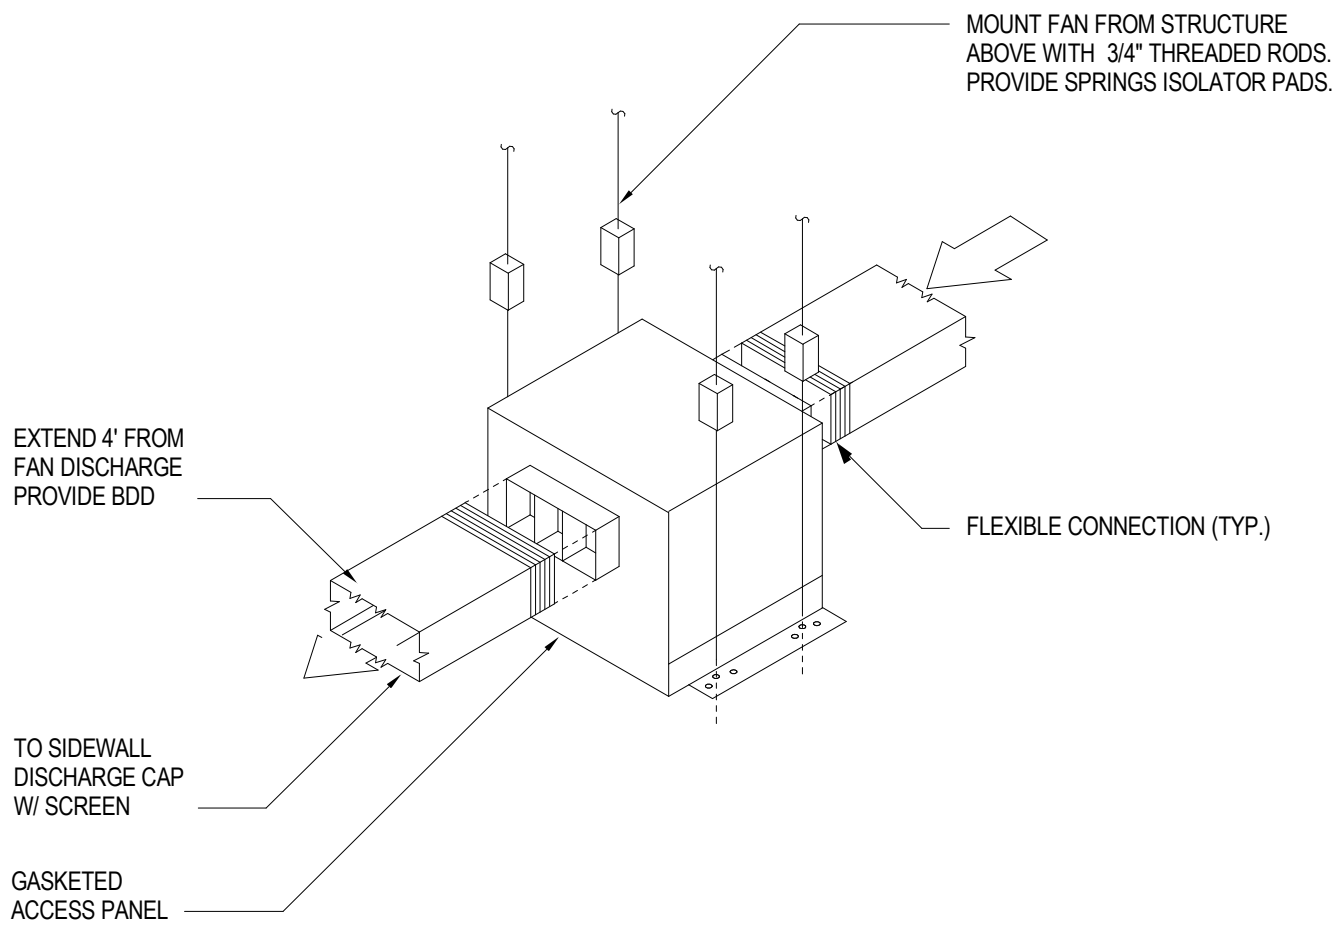

IN-LINE CEILING EXHAUST FAN DETAIL




H

CEILING EXHAUST FAN DETAIL

E

DUCTLESS AIR CONDITIONER UNIT DETAIL

B

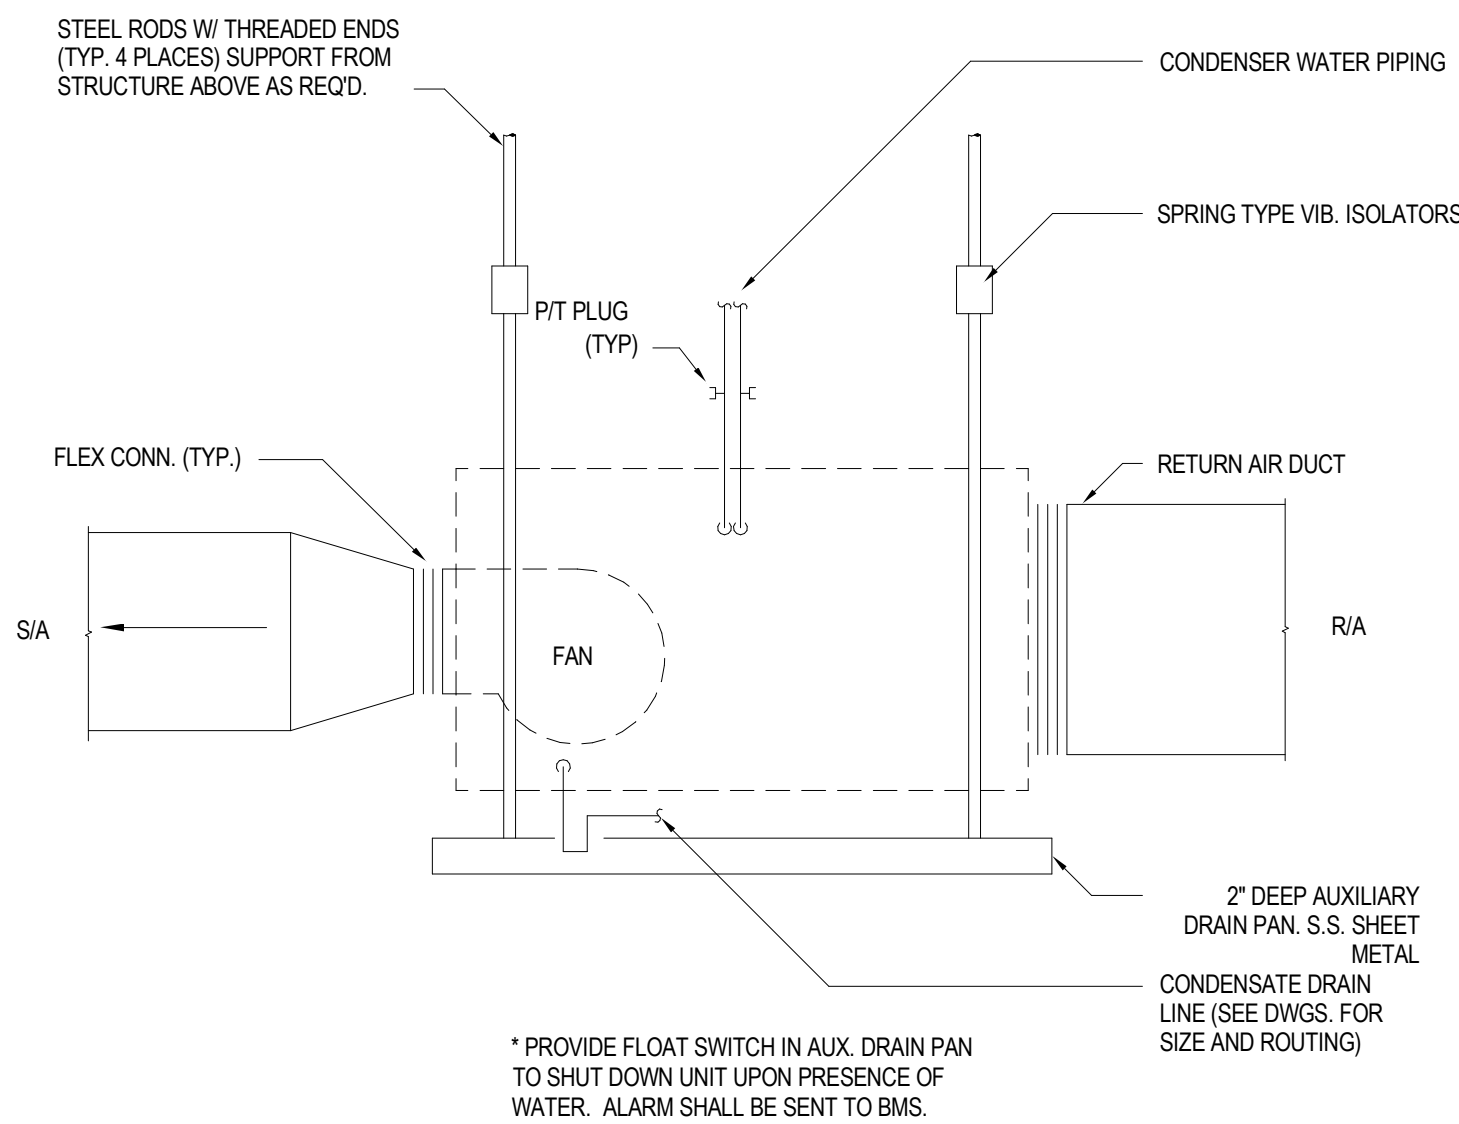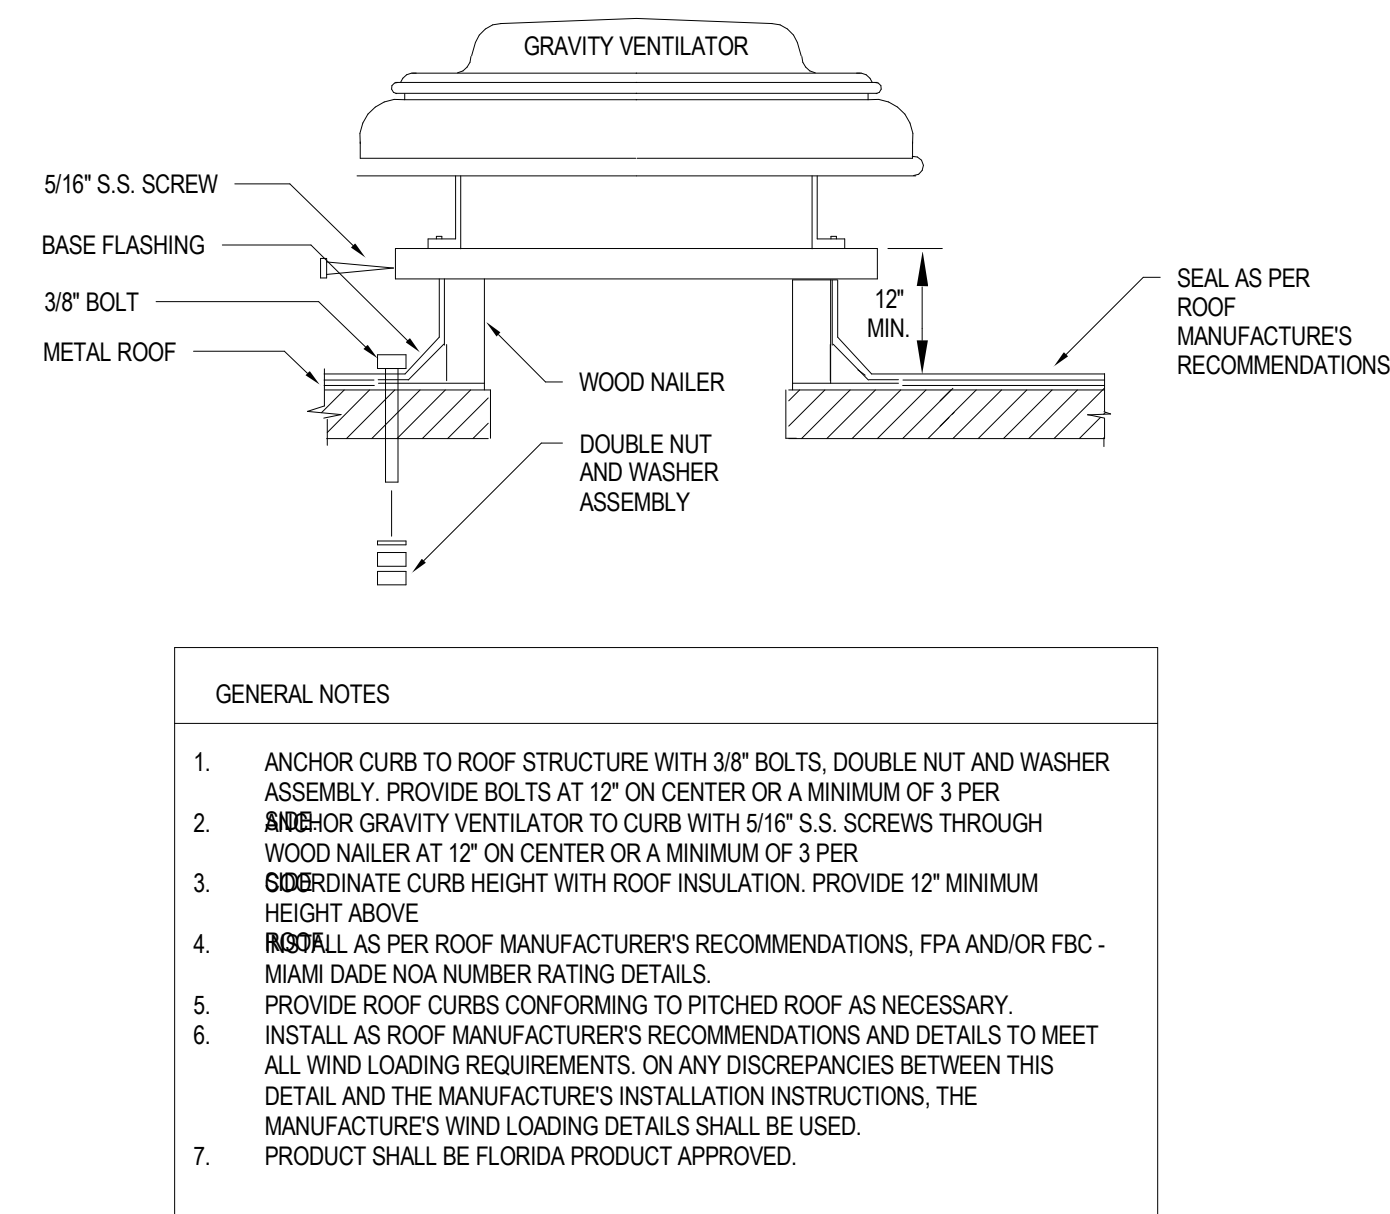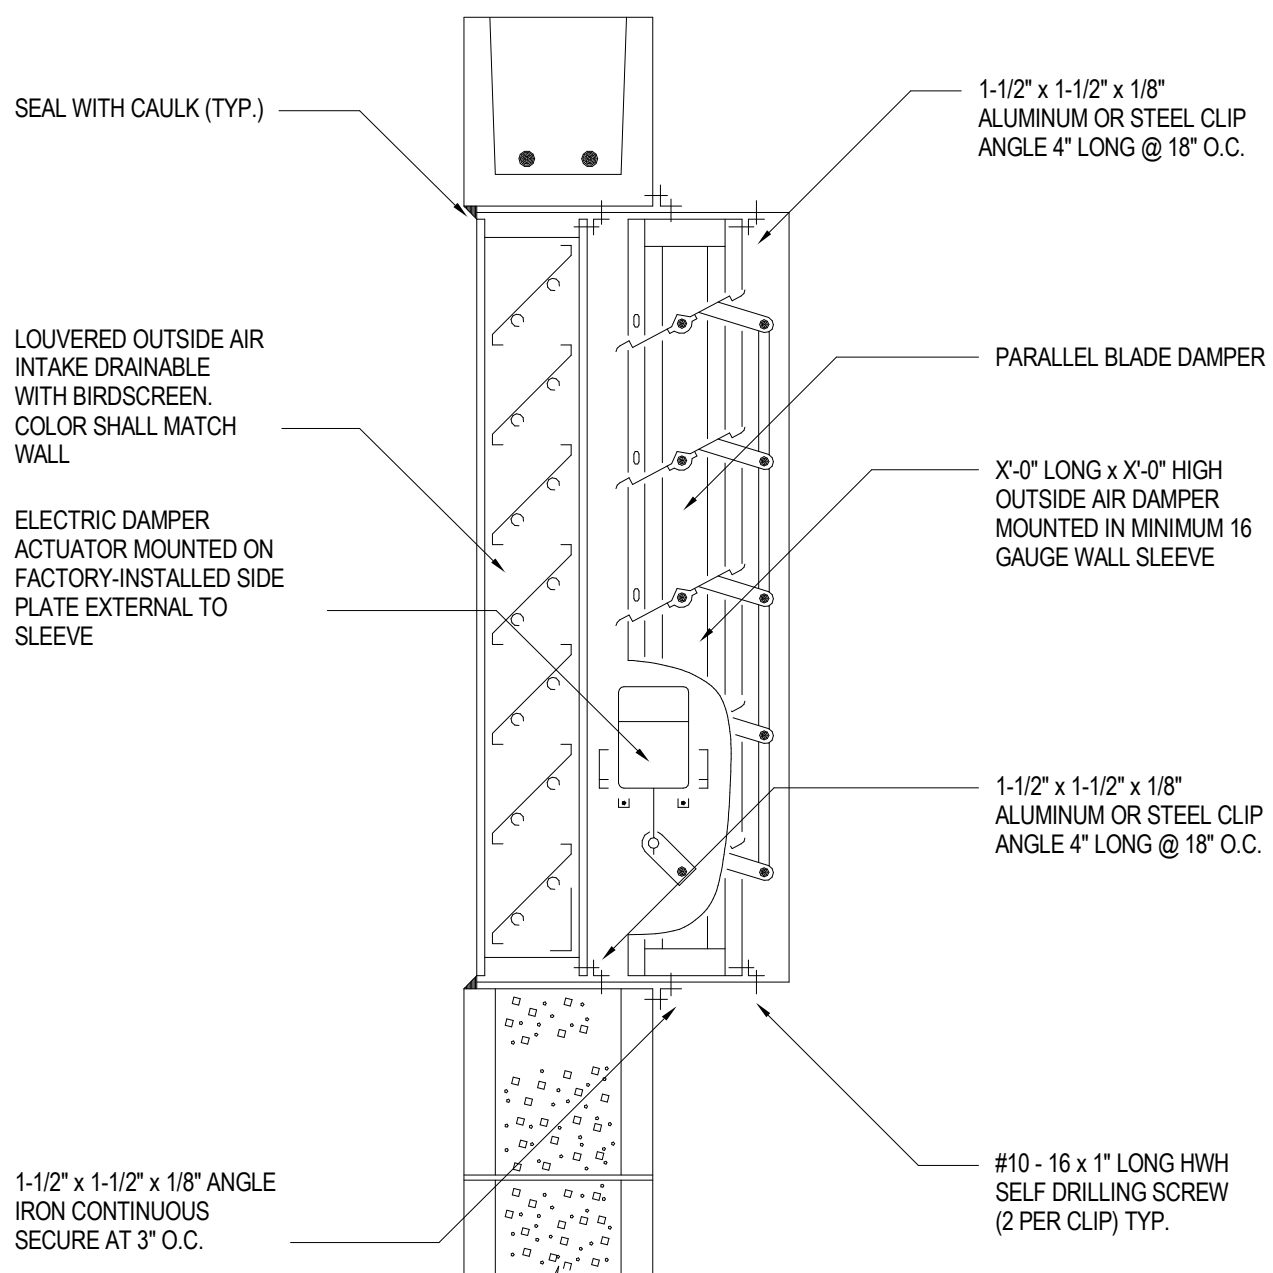

OUTSIDE AIR LOUVER W/MOTORIZED DAMPER

G


GRAVITY VENTILATOR DETAIL

D

HORIZONTAL AHU DETAIL


A

no.	description	date
	PERMIT SET	04.24.26

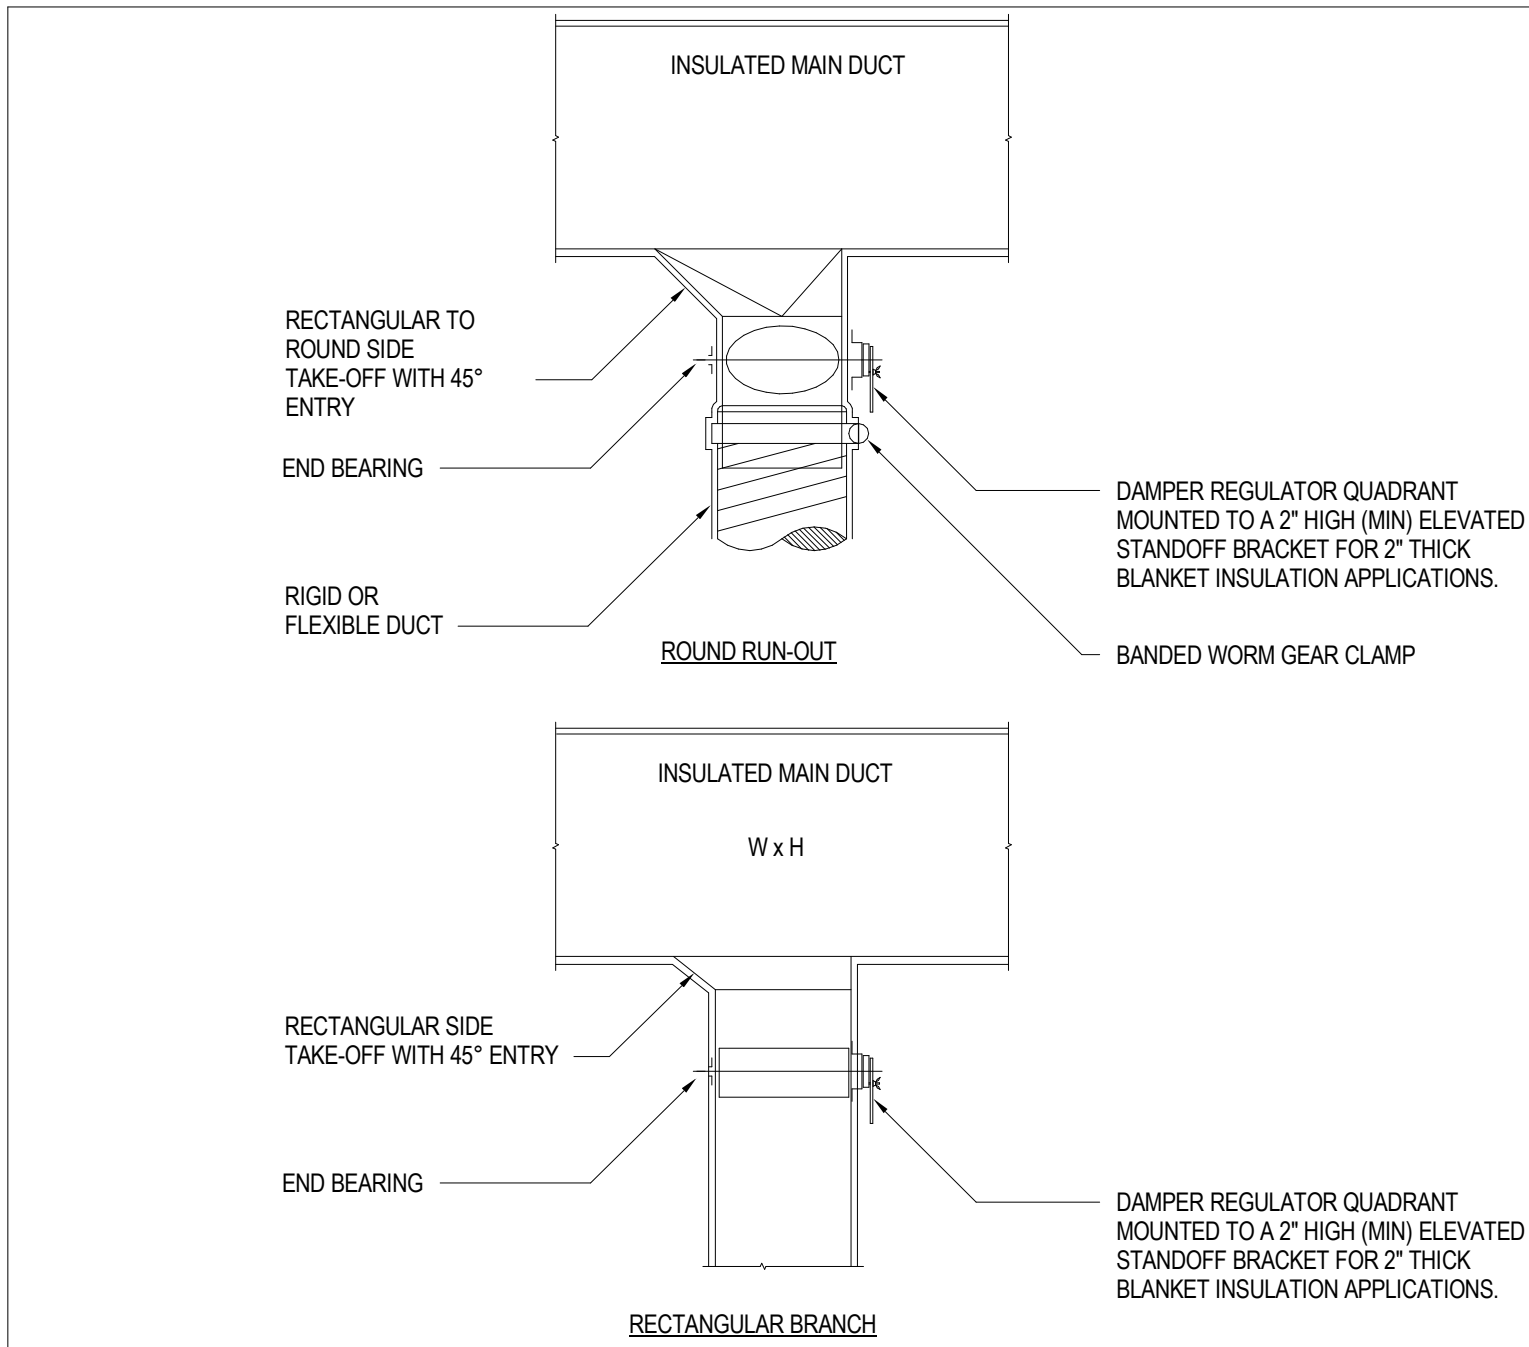


BRANCH TAKE-OFFS

I

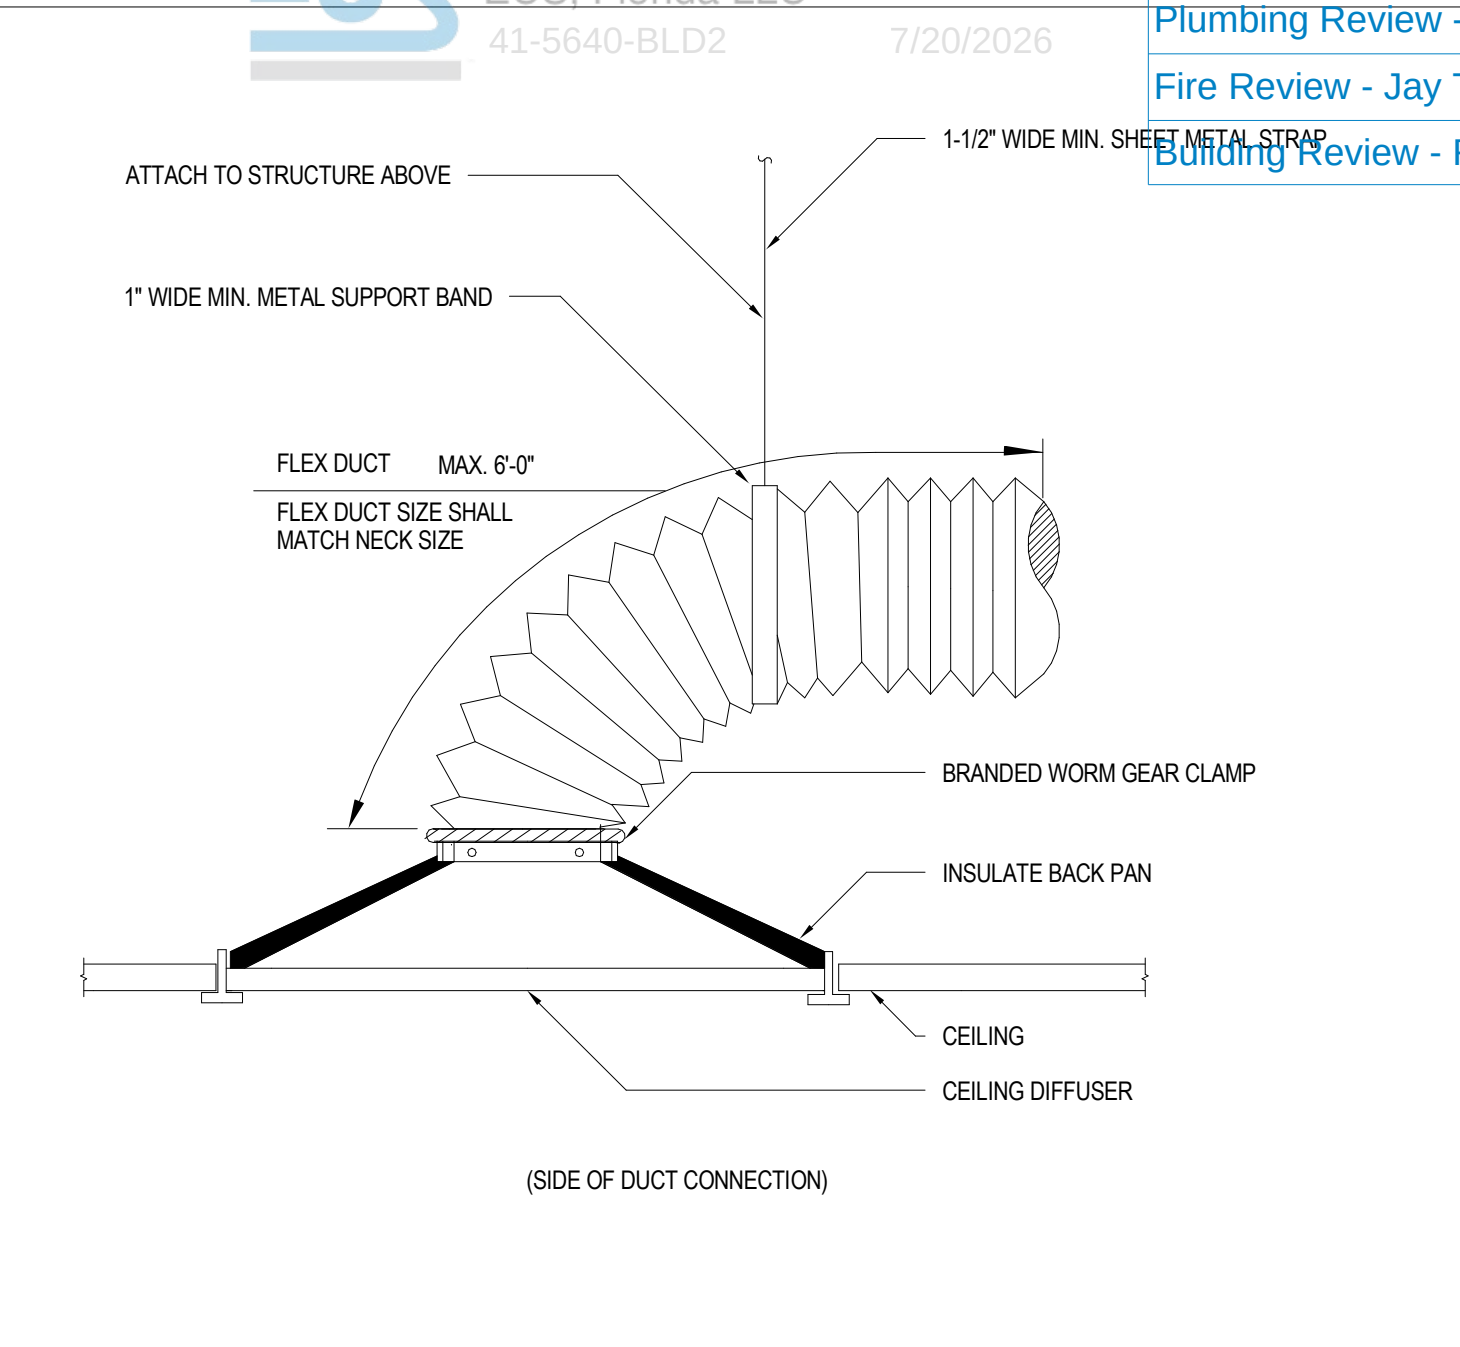


TYPICAL SUPPLY DIFFUSER CONNECTION

F

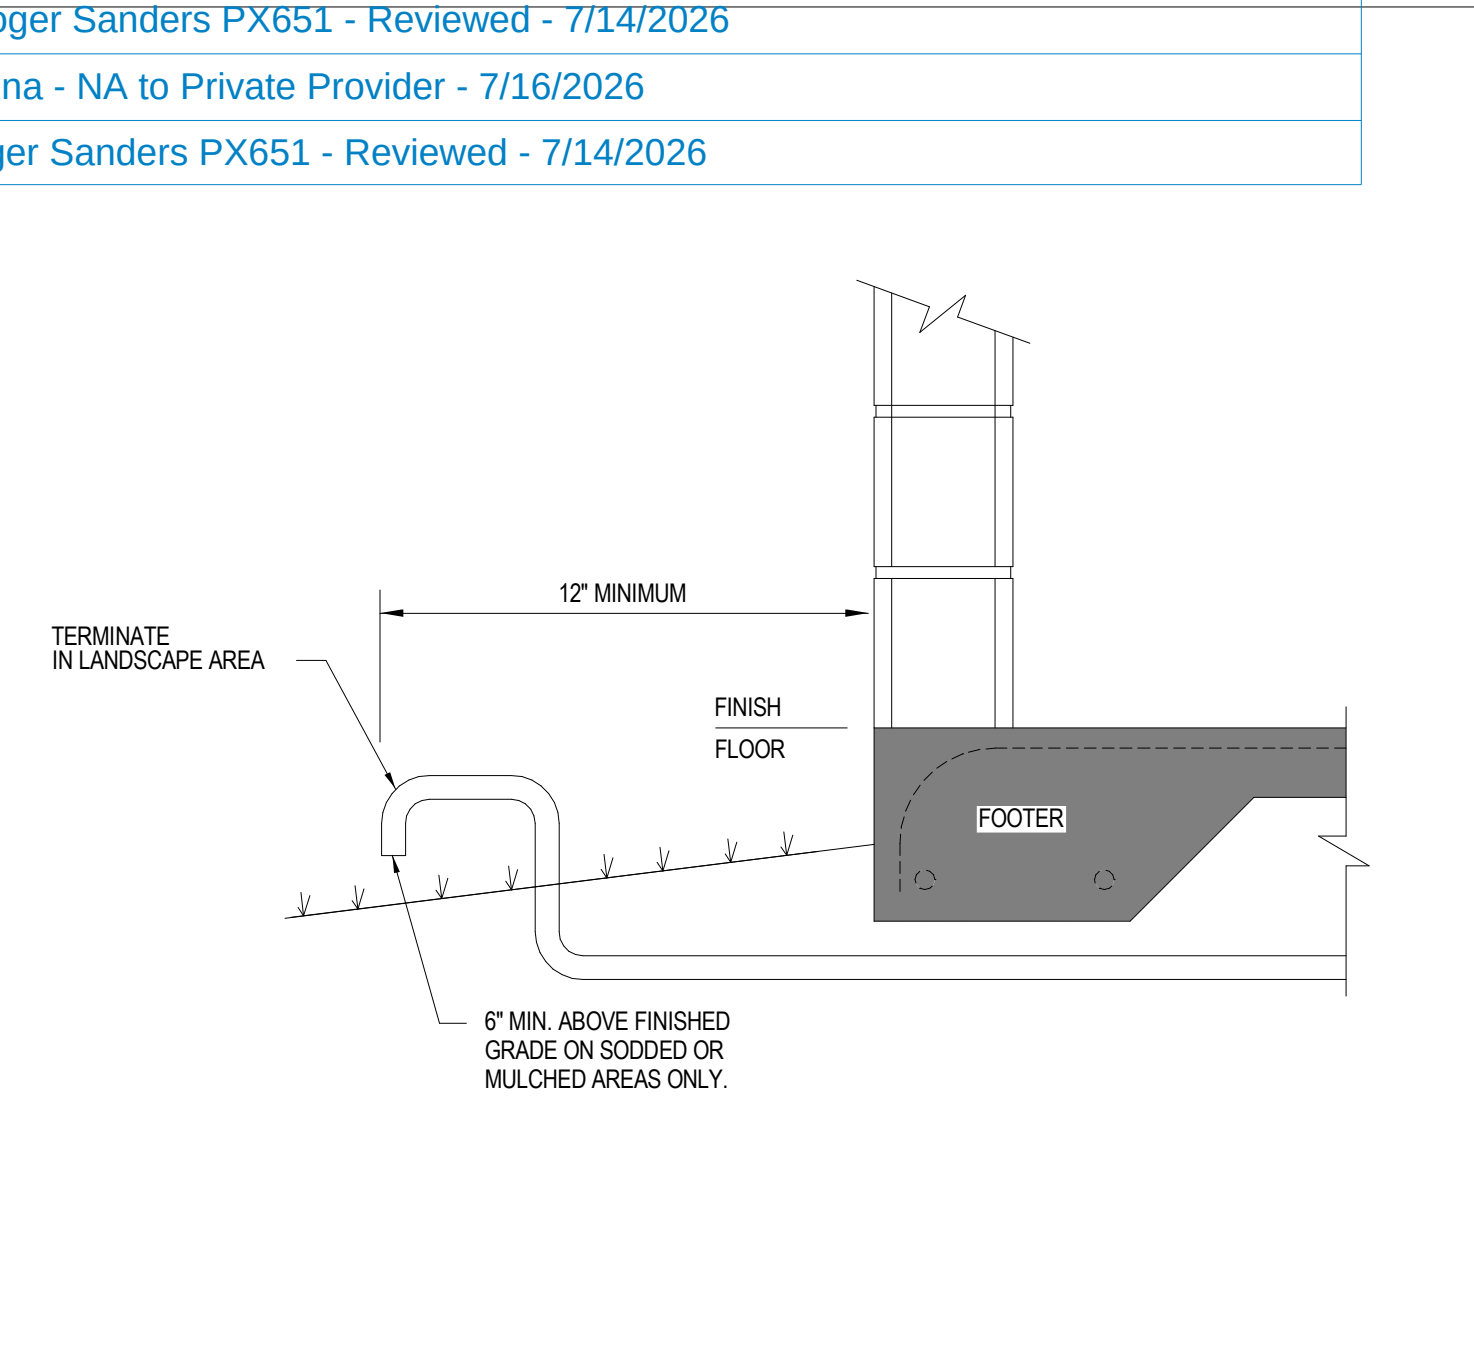


CONDENSATE DISCHARGE TERMINATION DETAIL

C

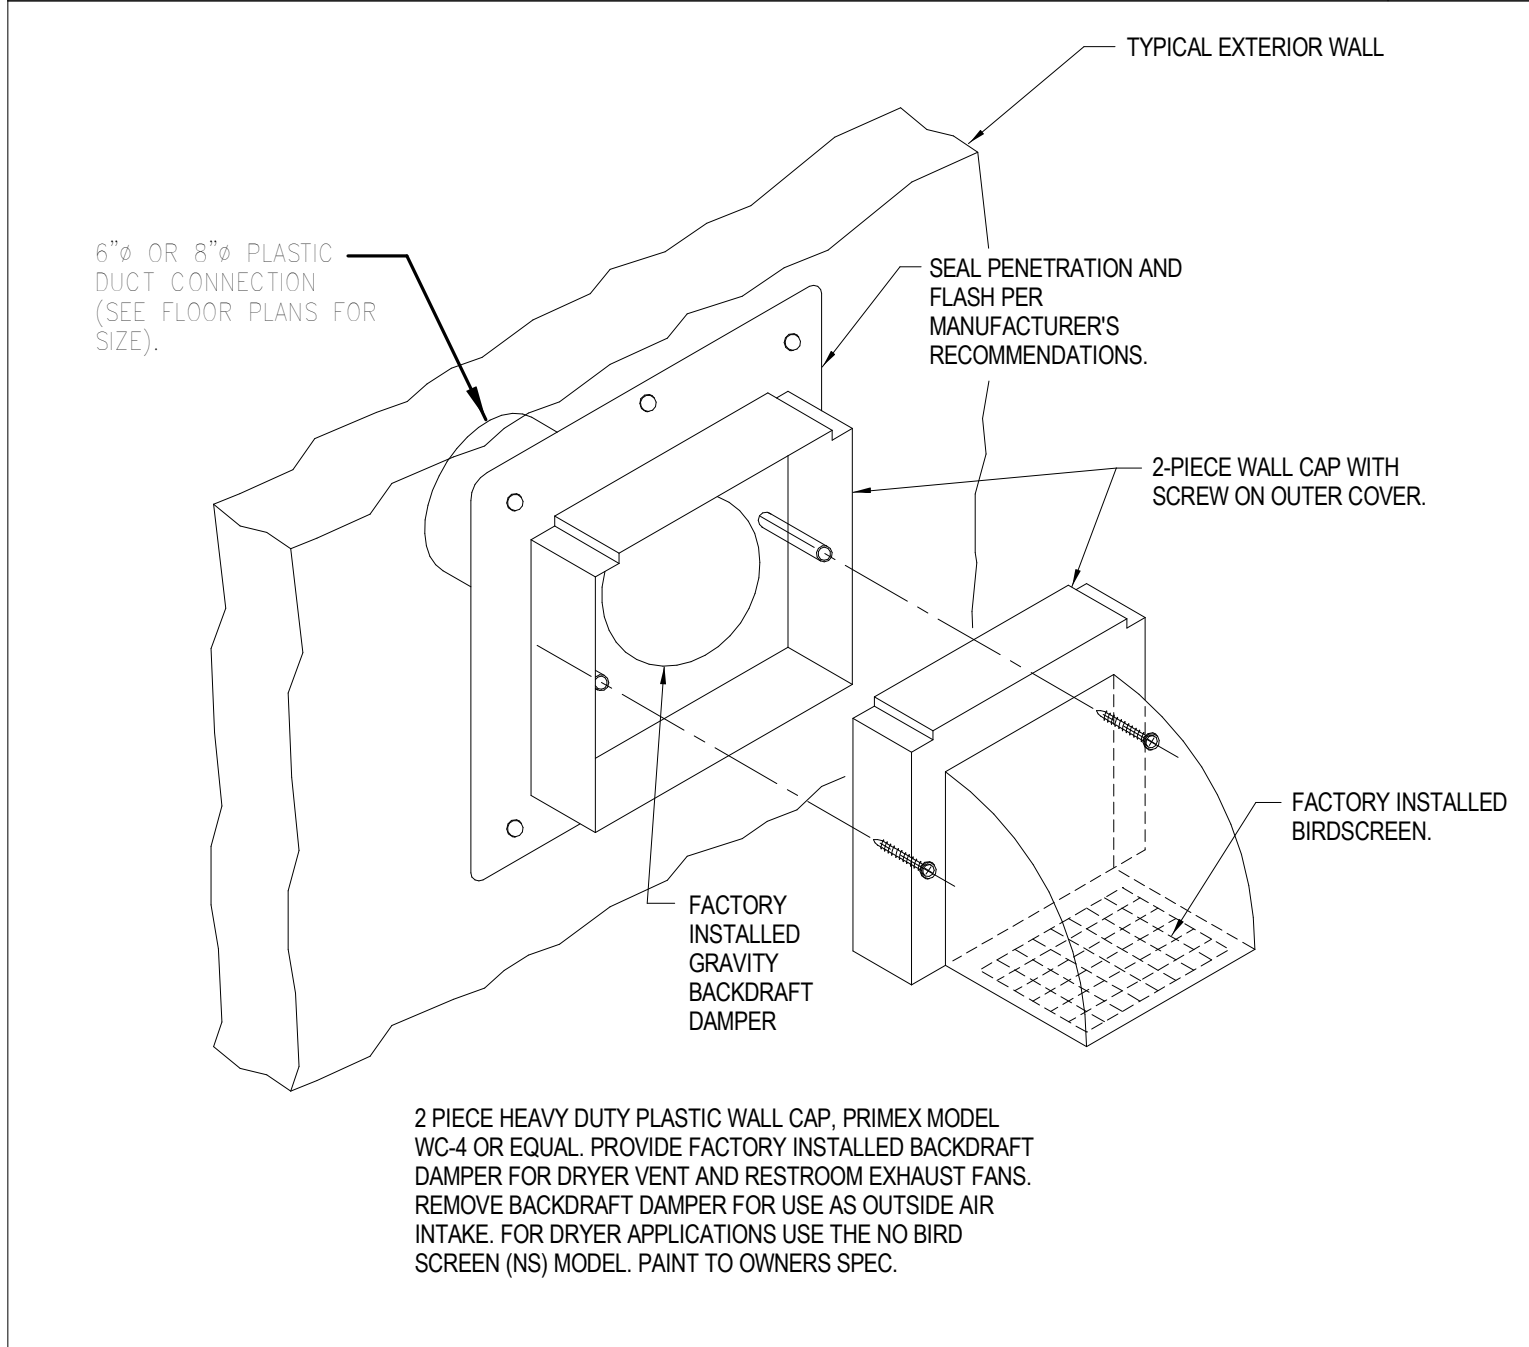


TYPICAL WALL CAP DETAIL

H

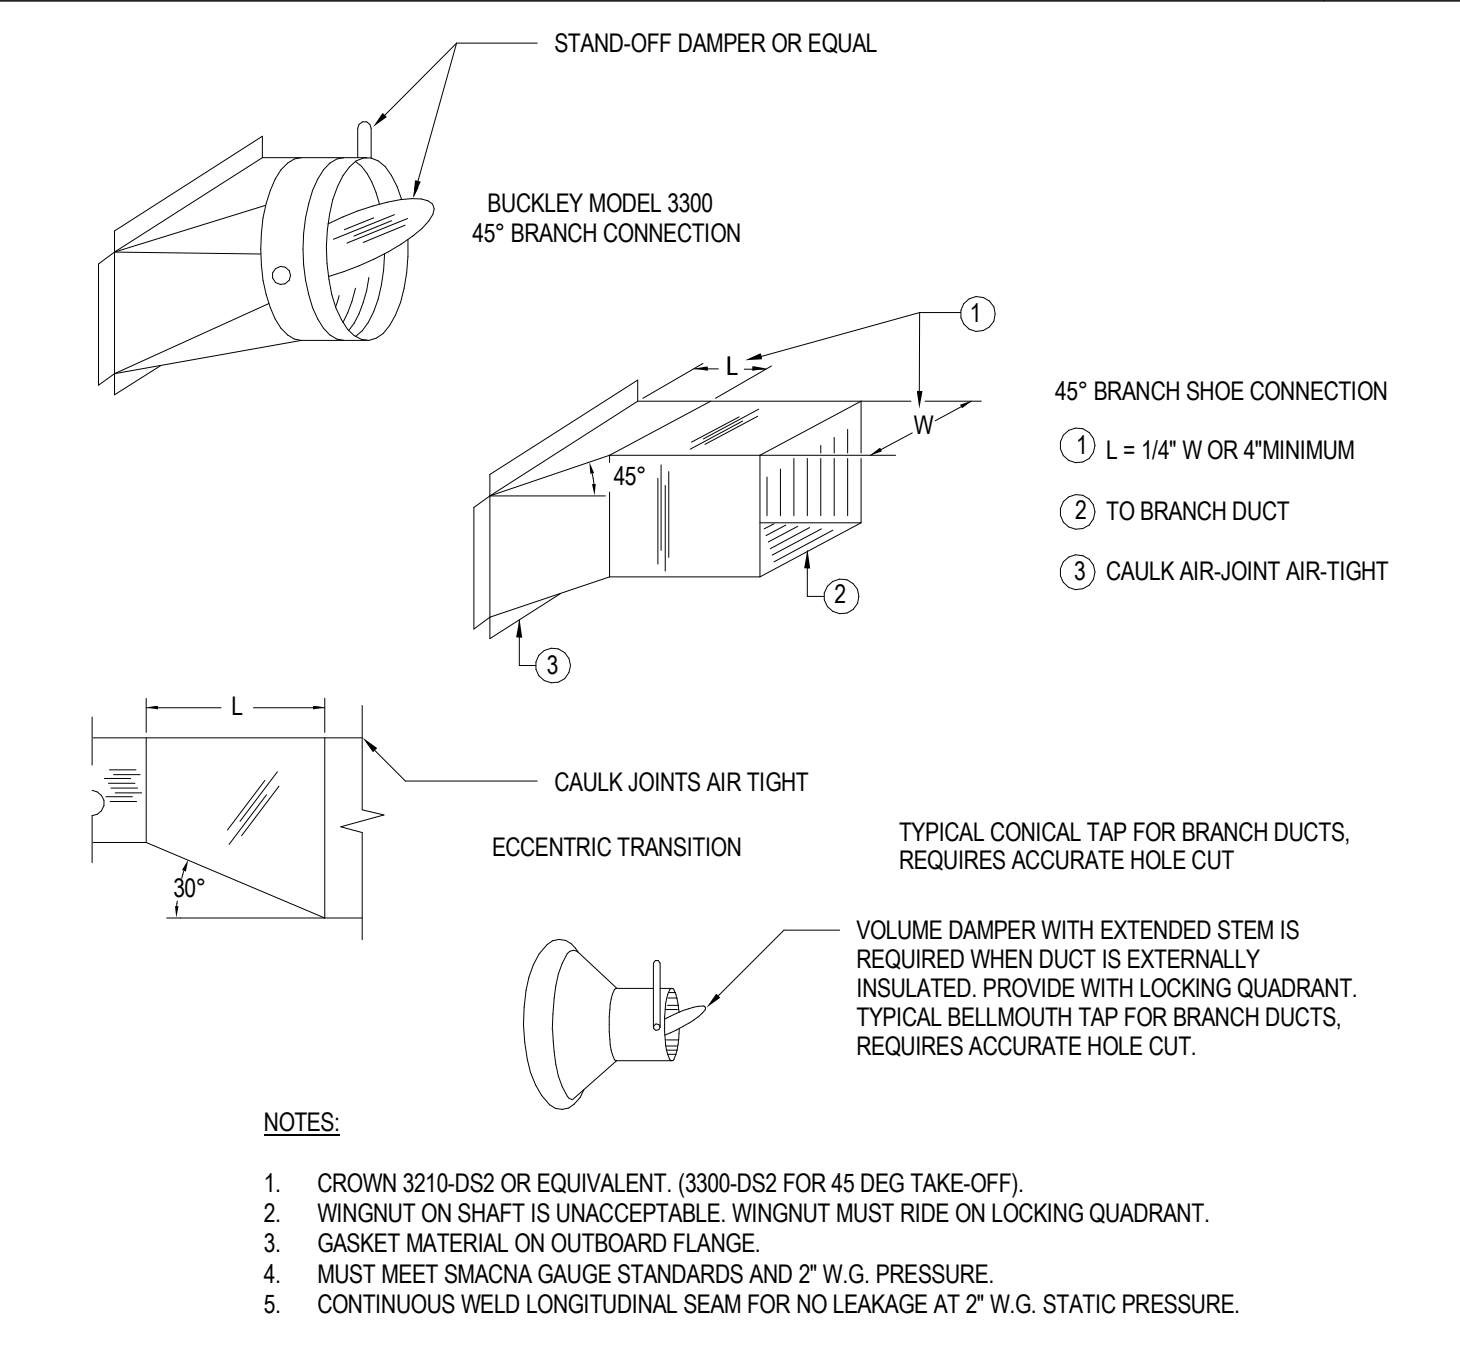


TAKEOFF FITTING DETAIL

E

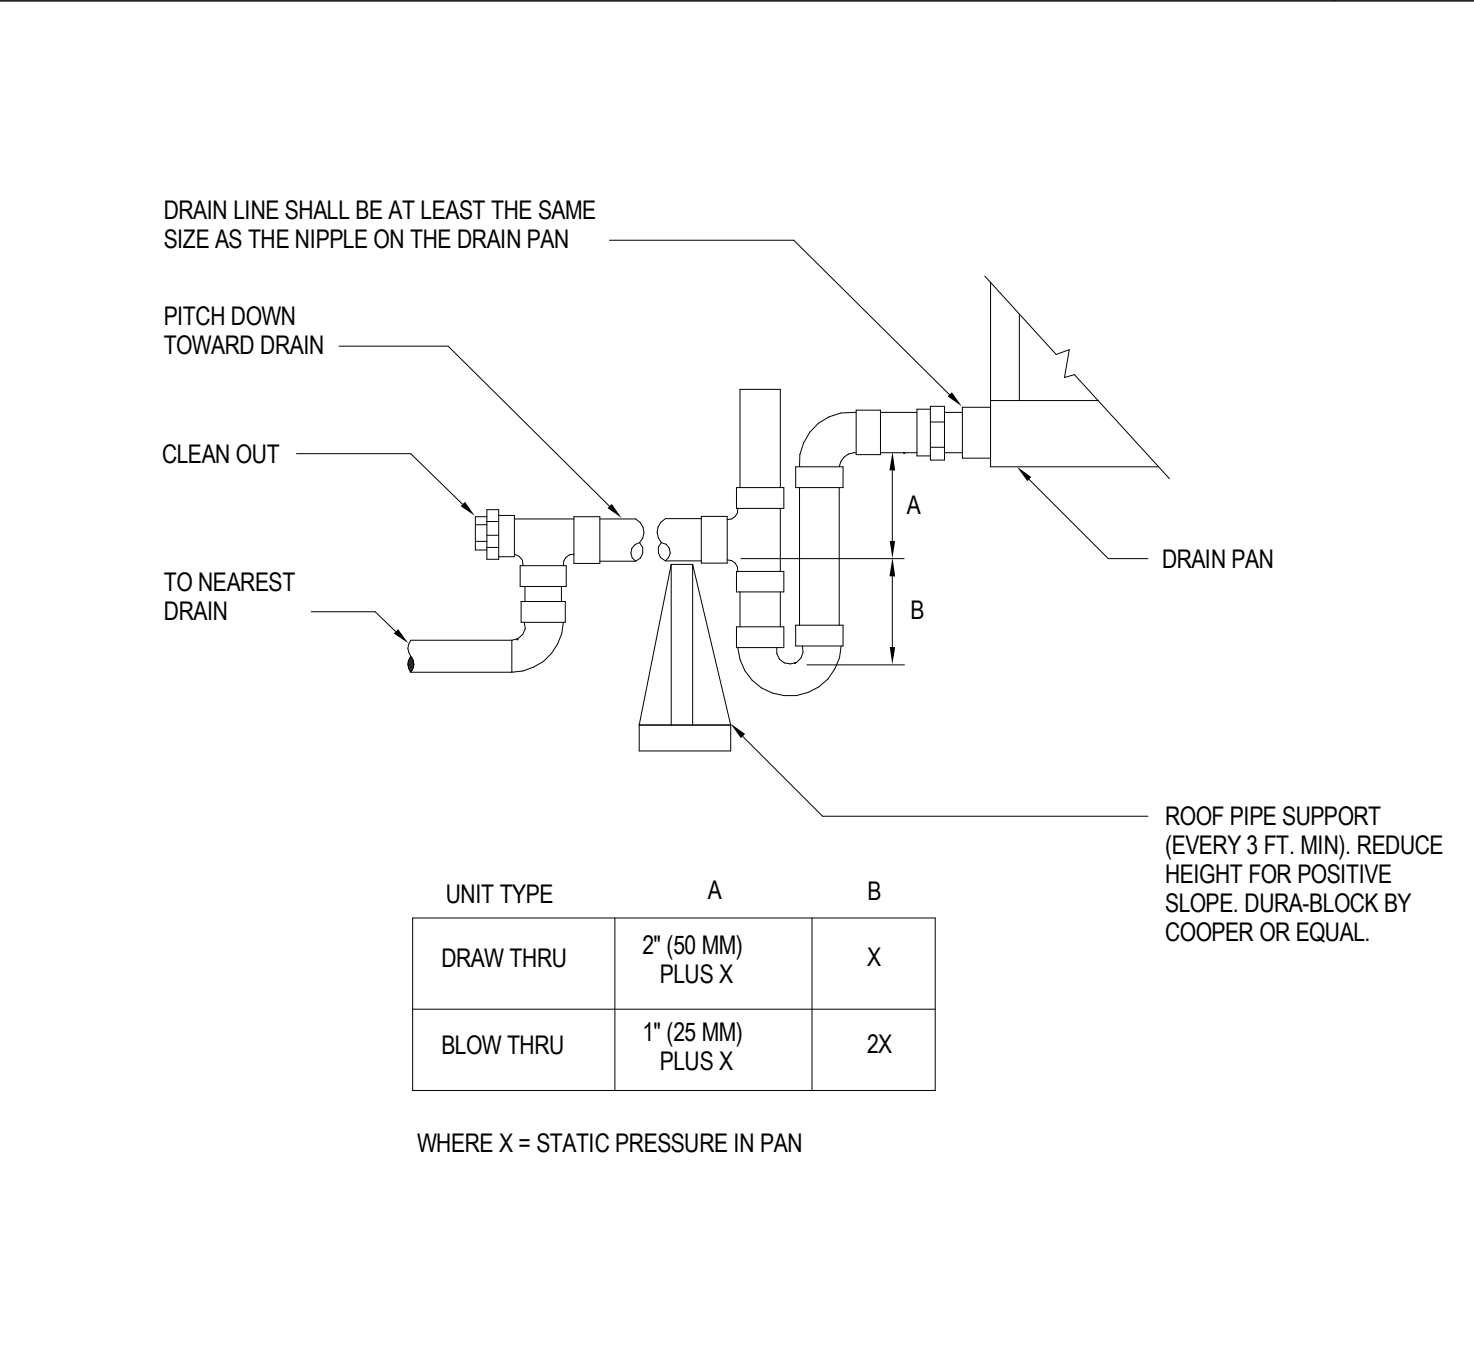


AIR HANDLING UNIT DRAIN TRAP DETAIL

B

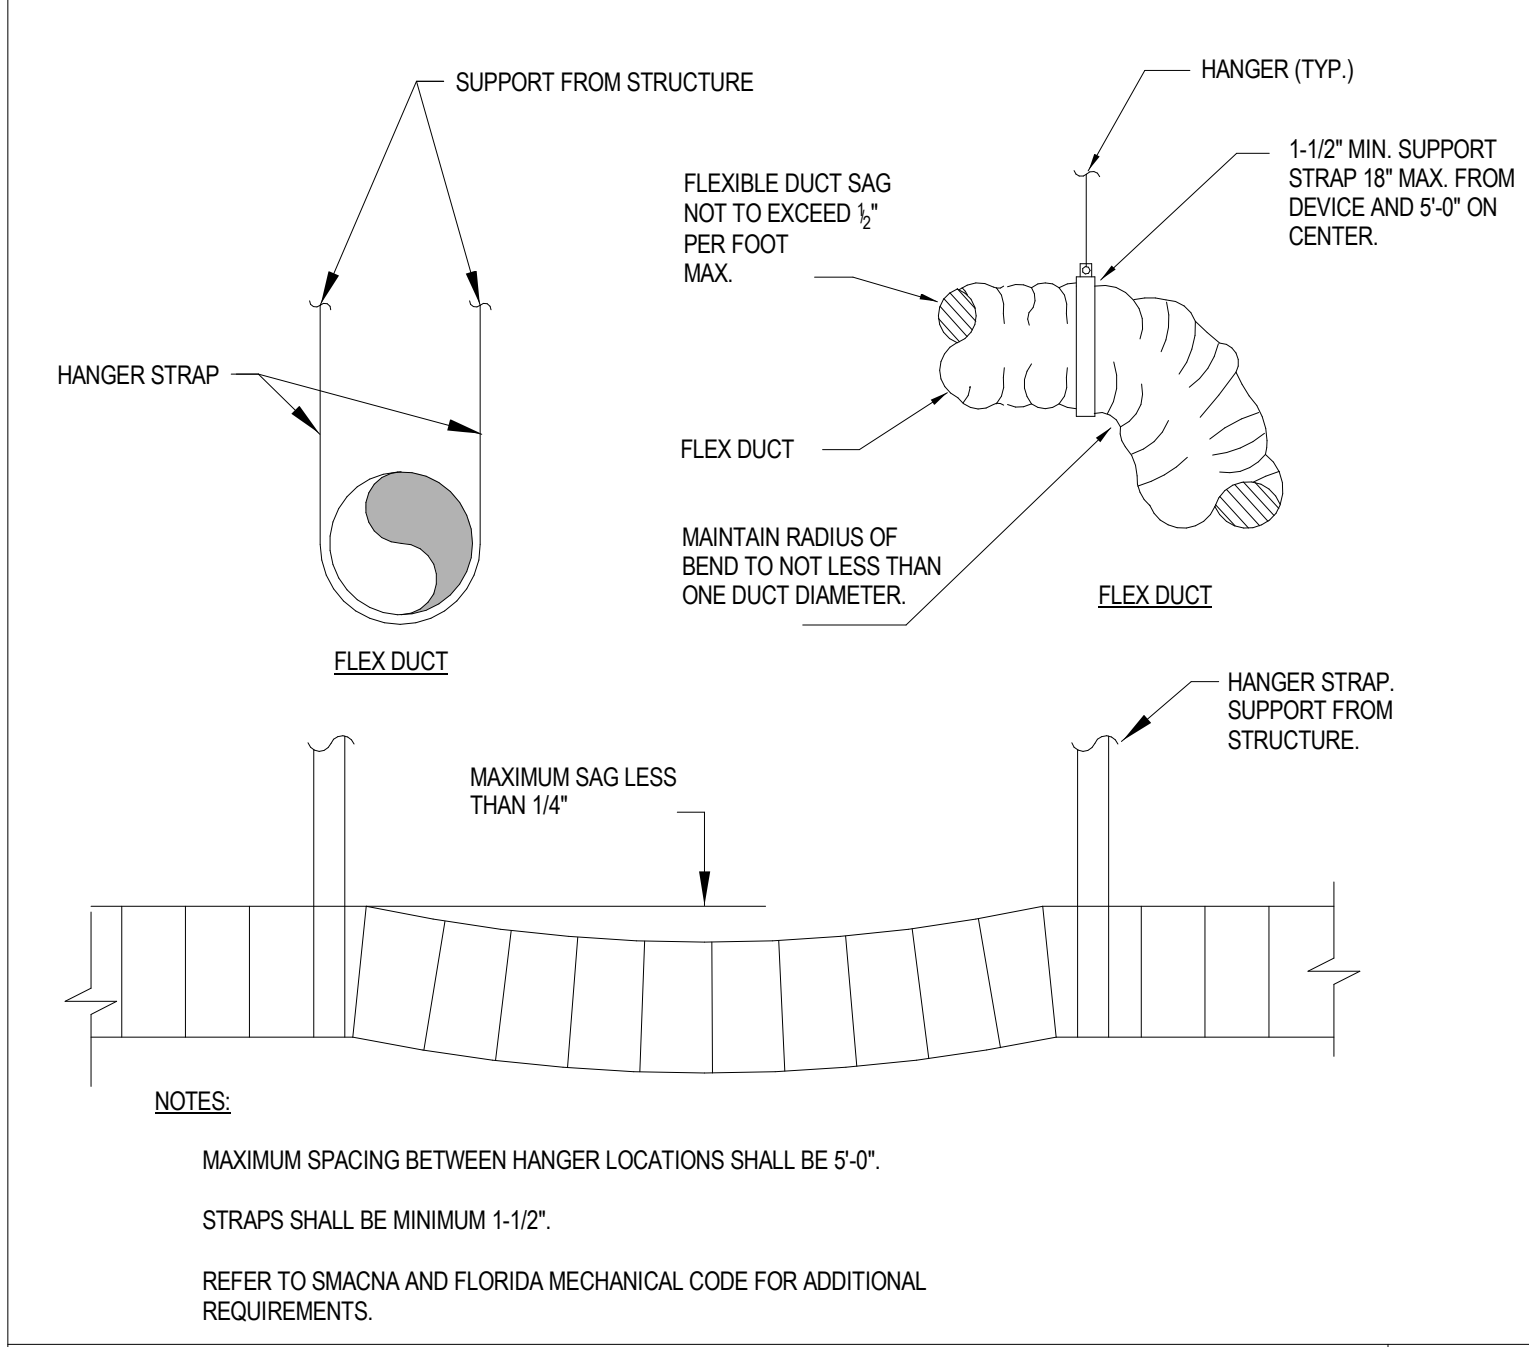


FLEX DUCT HANGAR DETAIL

G

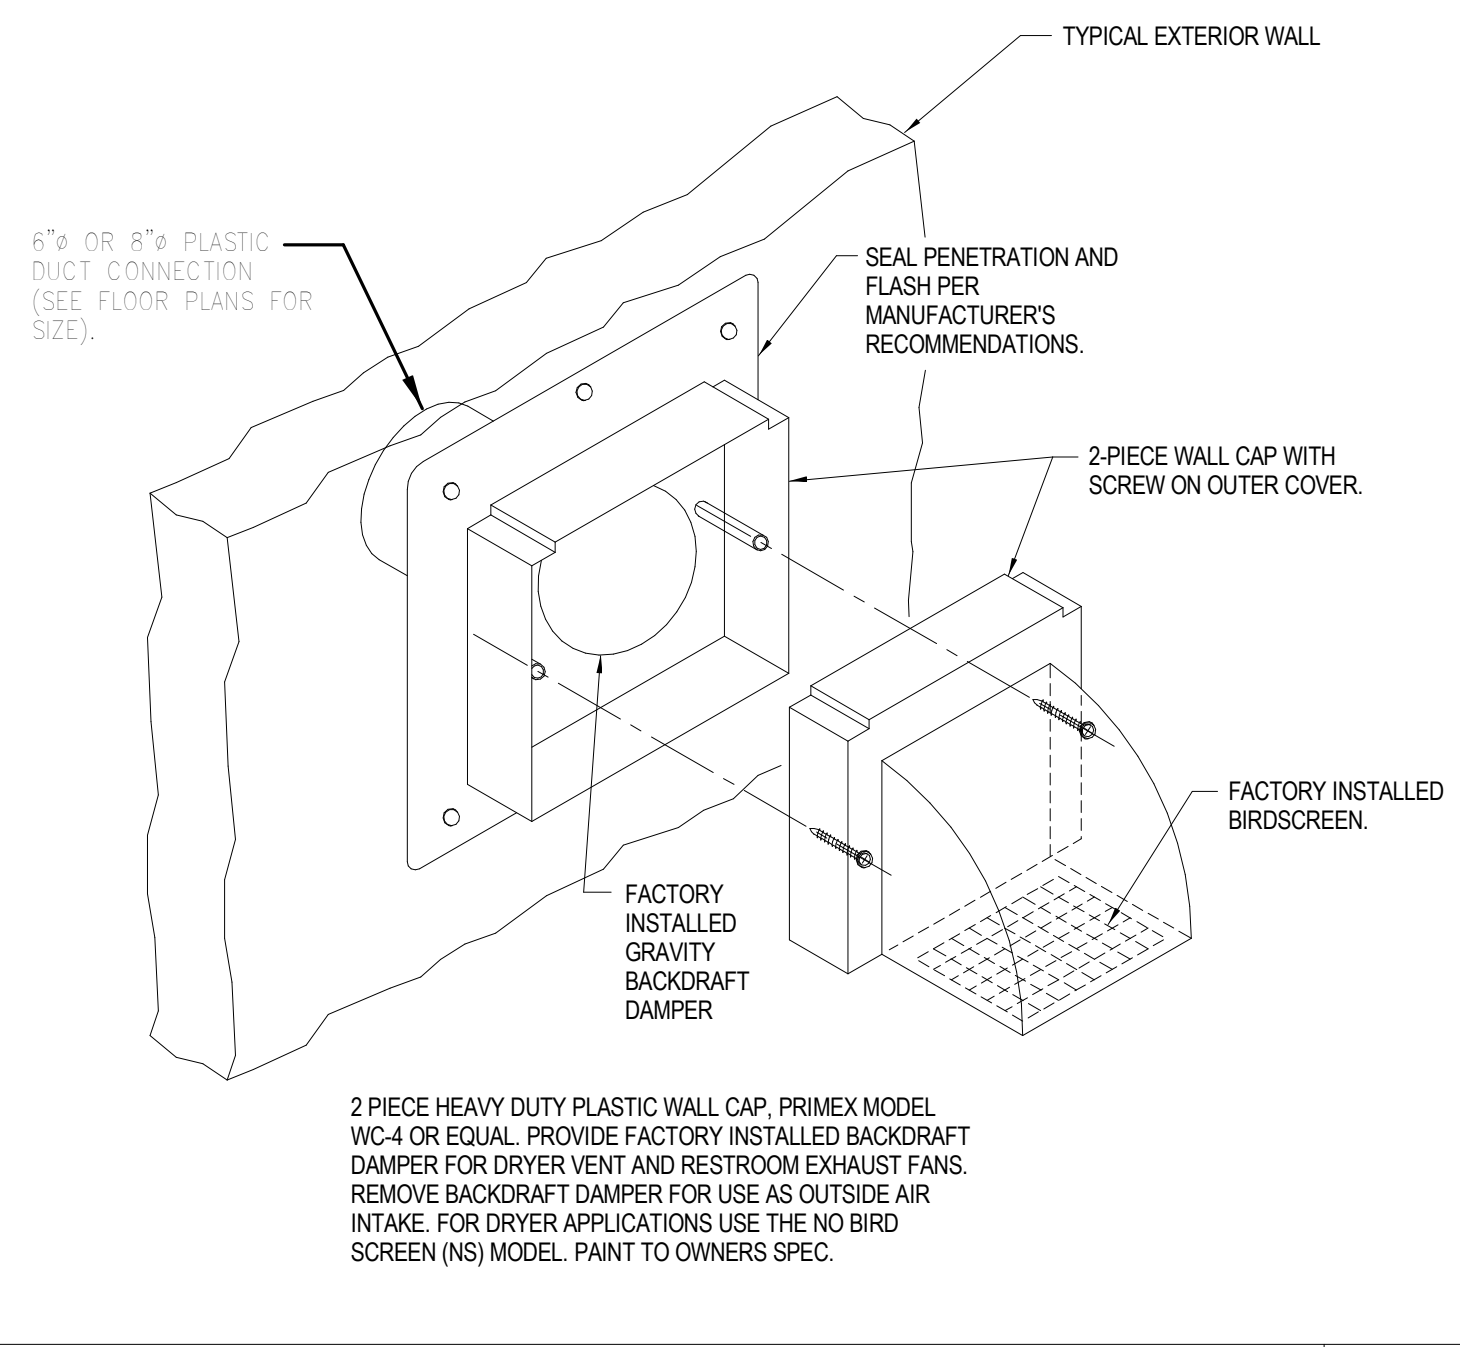

TYPICAL WALL CAP DETAIL

D

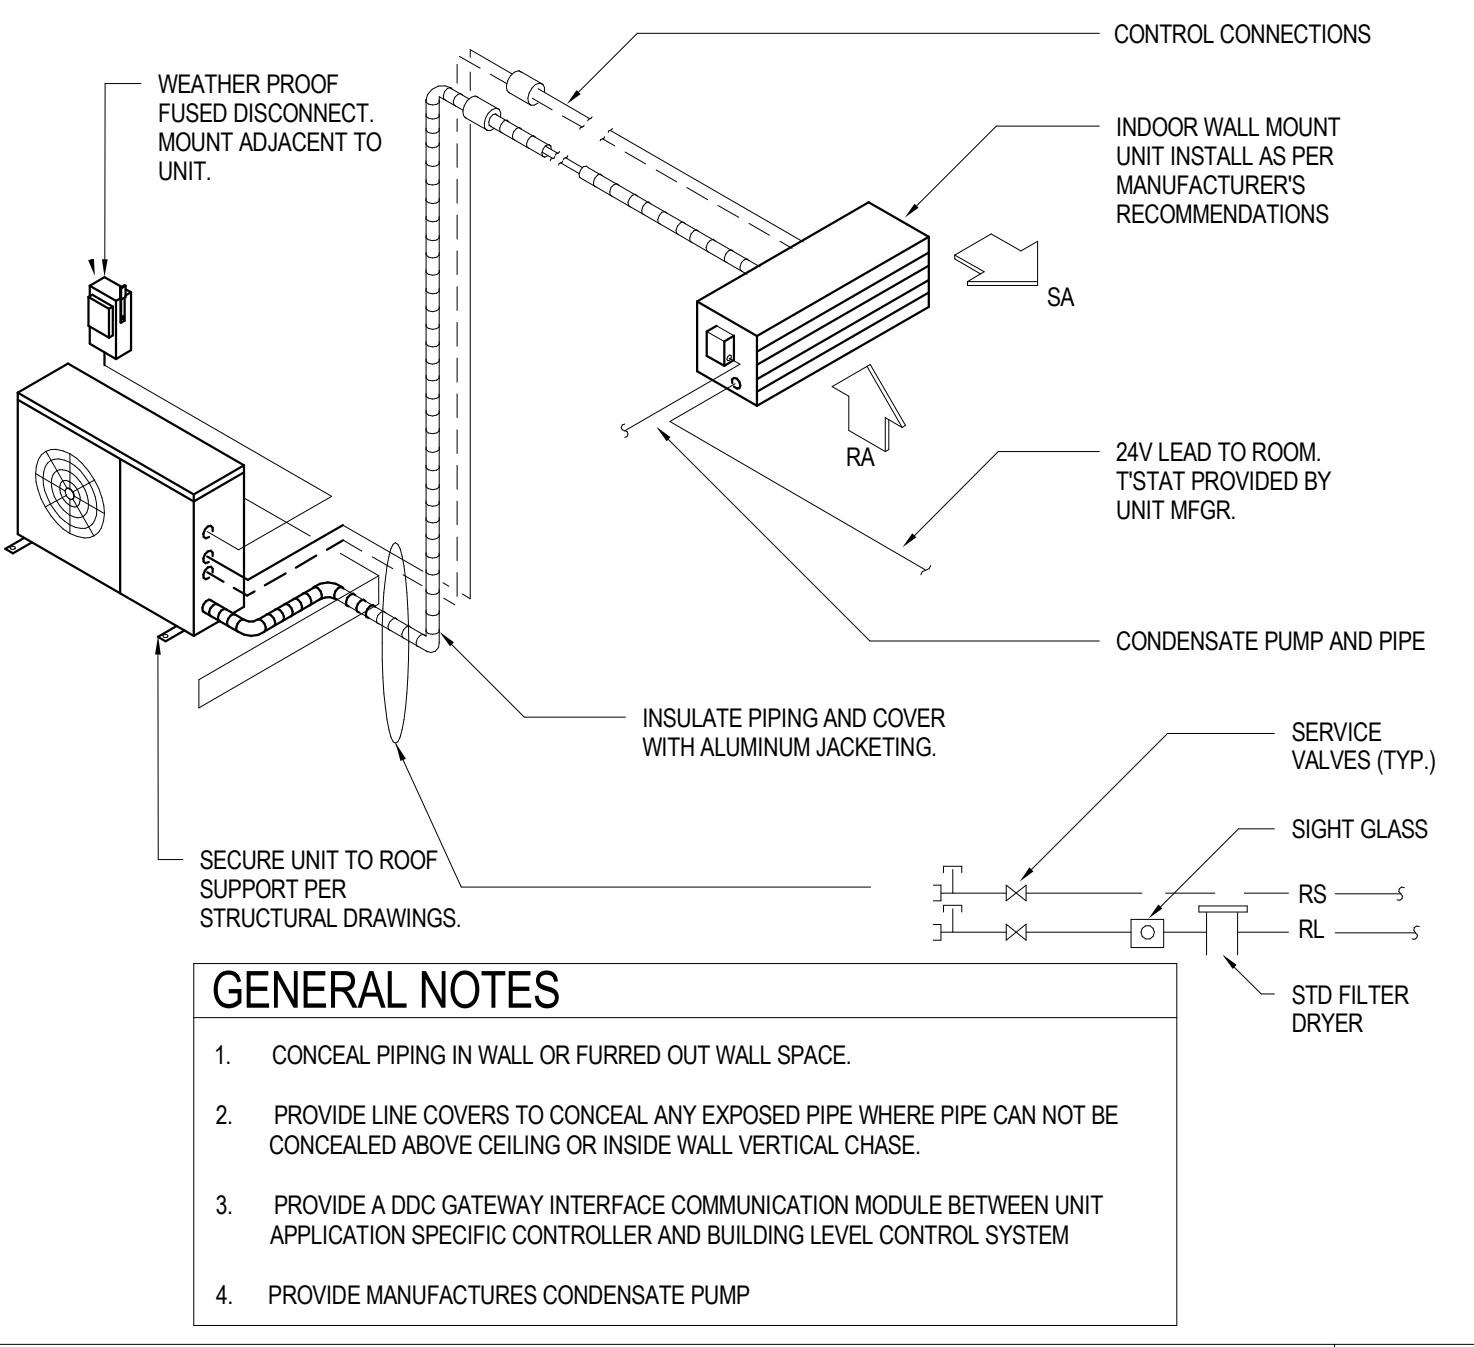

DUCTLESS AIR CONDITIONER UNIT DETAIL


A

OLD MEMORIAL


13600 National Golf Dr
Tampa, FL 33626

no.	description	date
	PERMIT SET	04.24.26


M6.02
DETAILS -
MECHANICAL

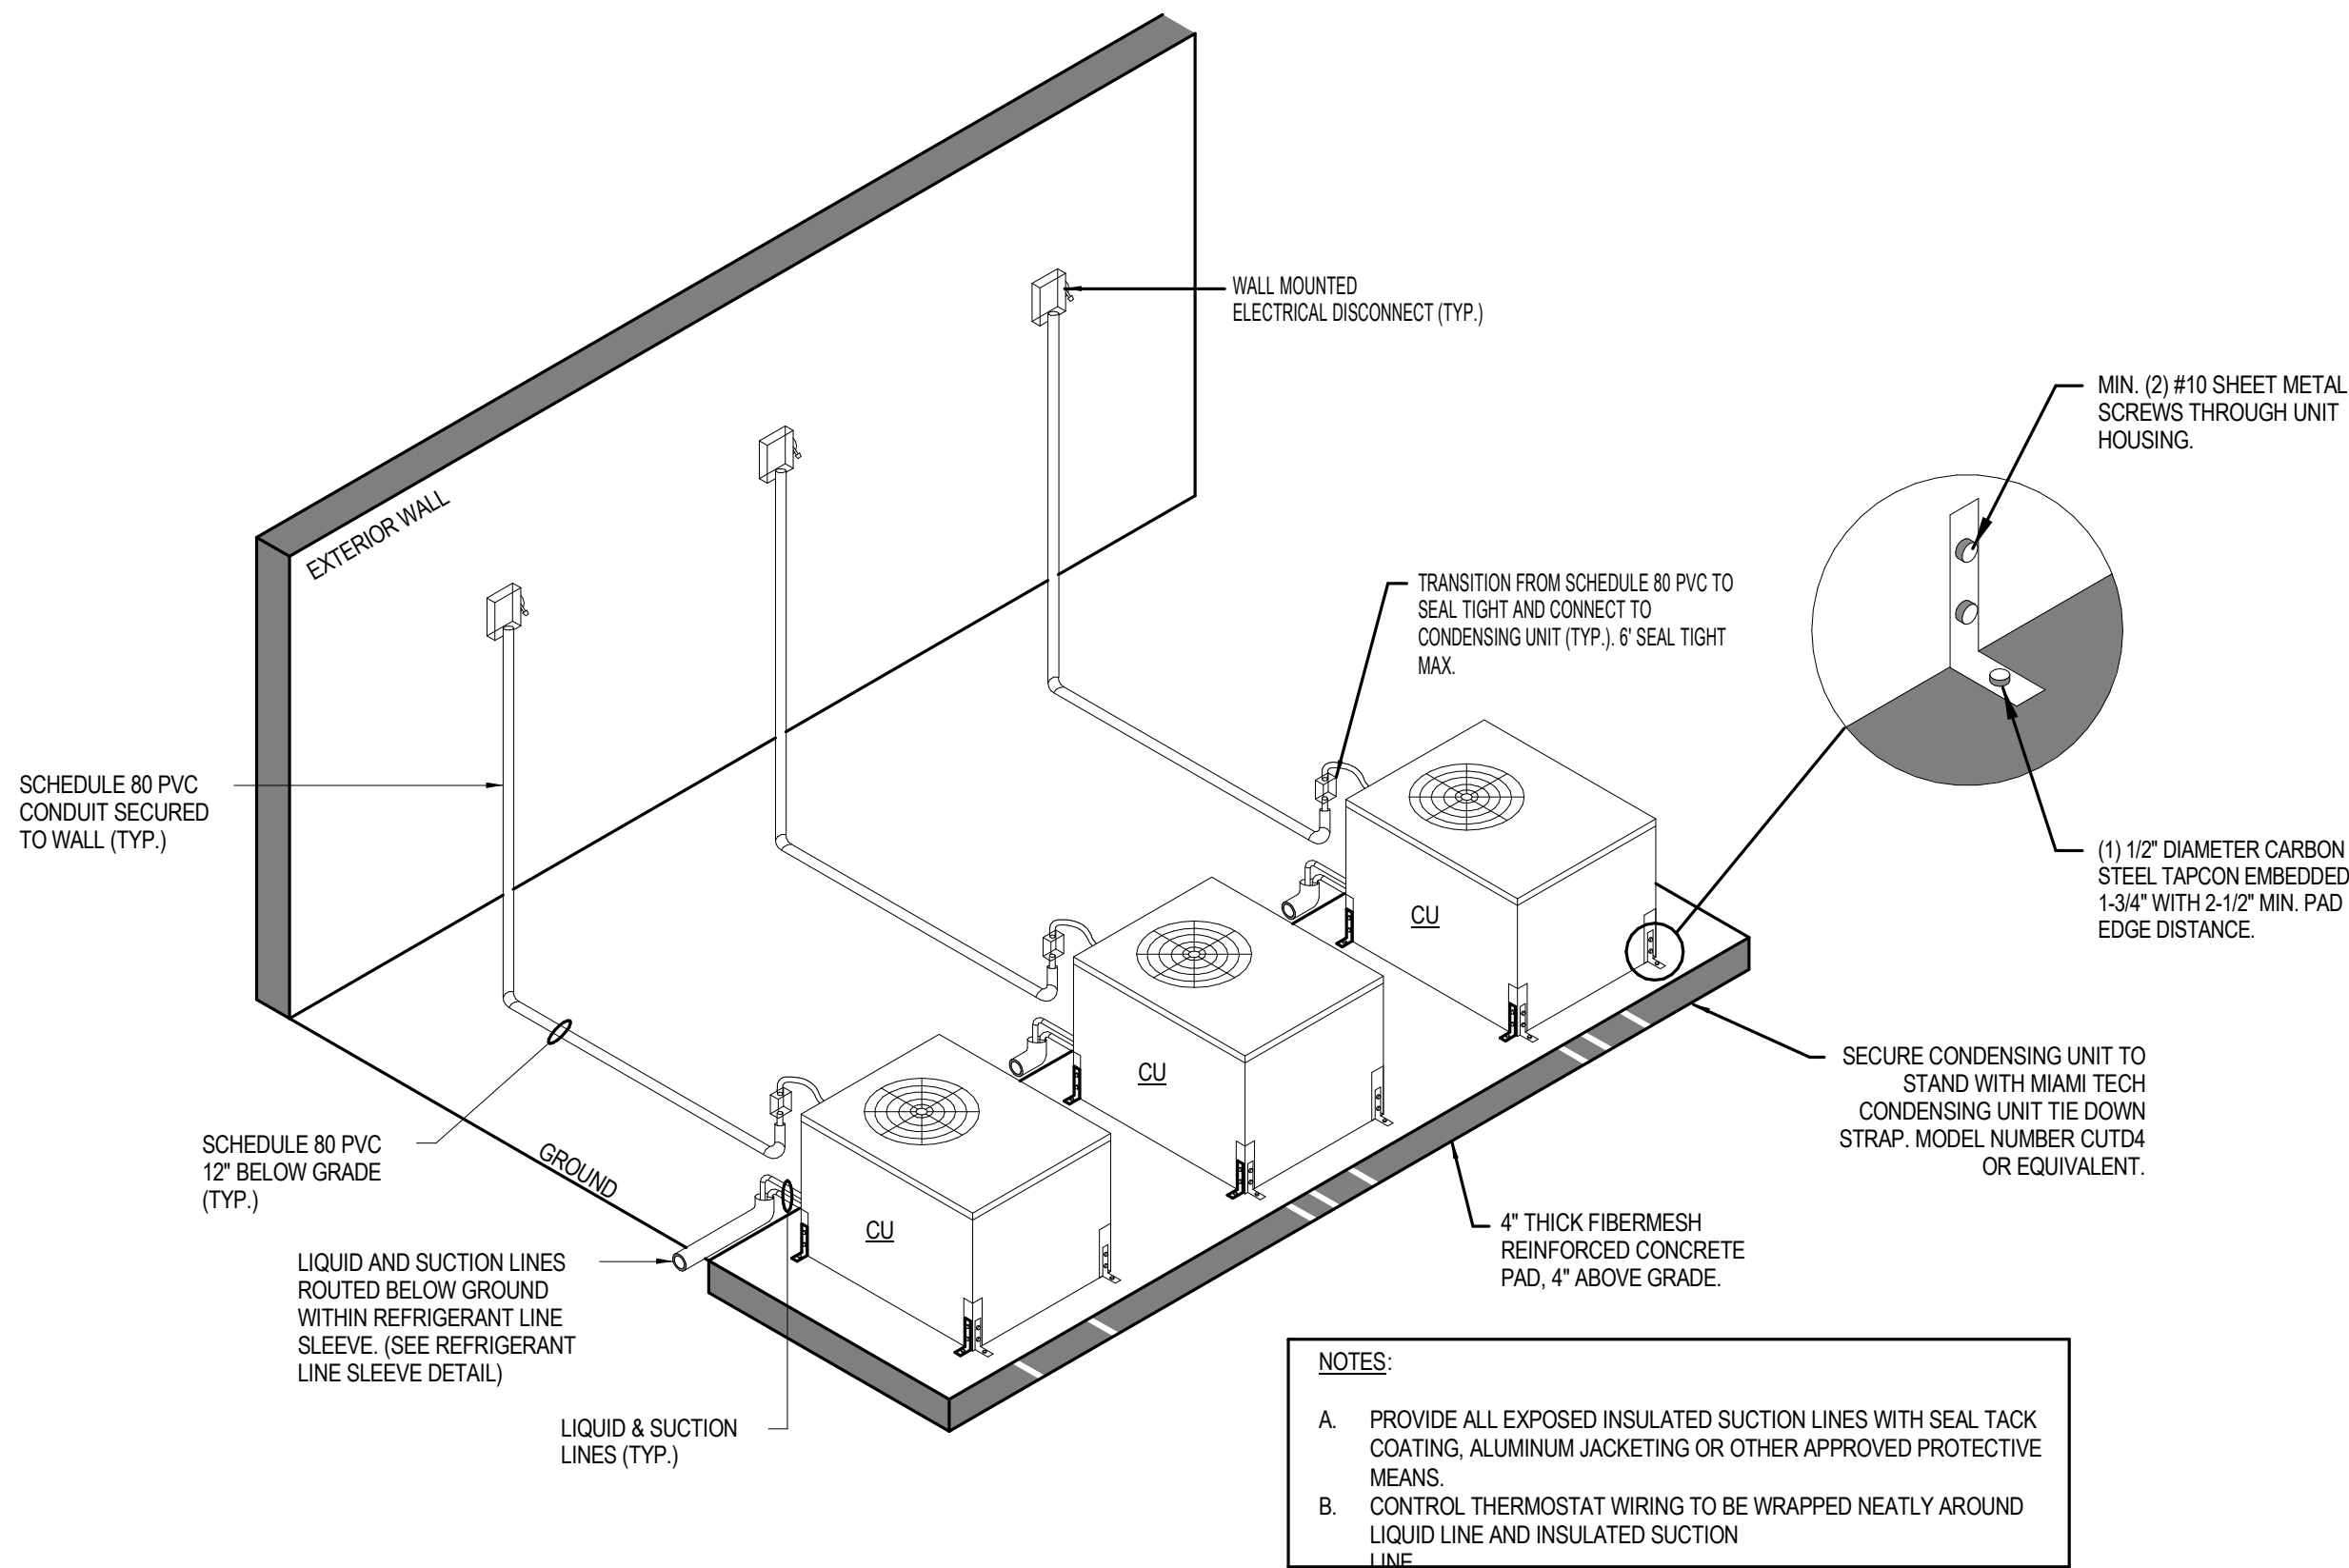

GROUND MOUNTED CONDENSING UNIT PIPING DETAIL (REFRIGERANT AND ELECTRICAL BELOW GRADE.)

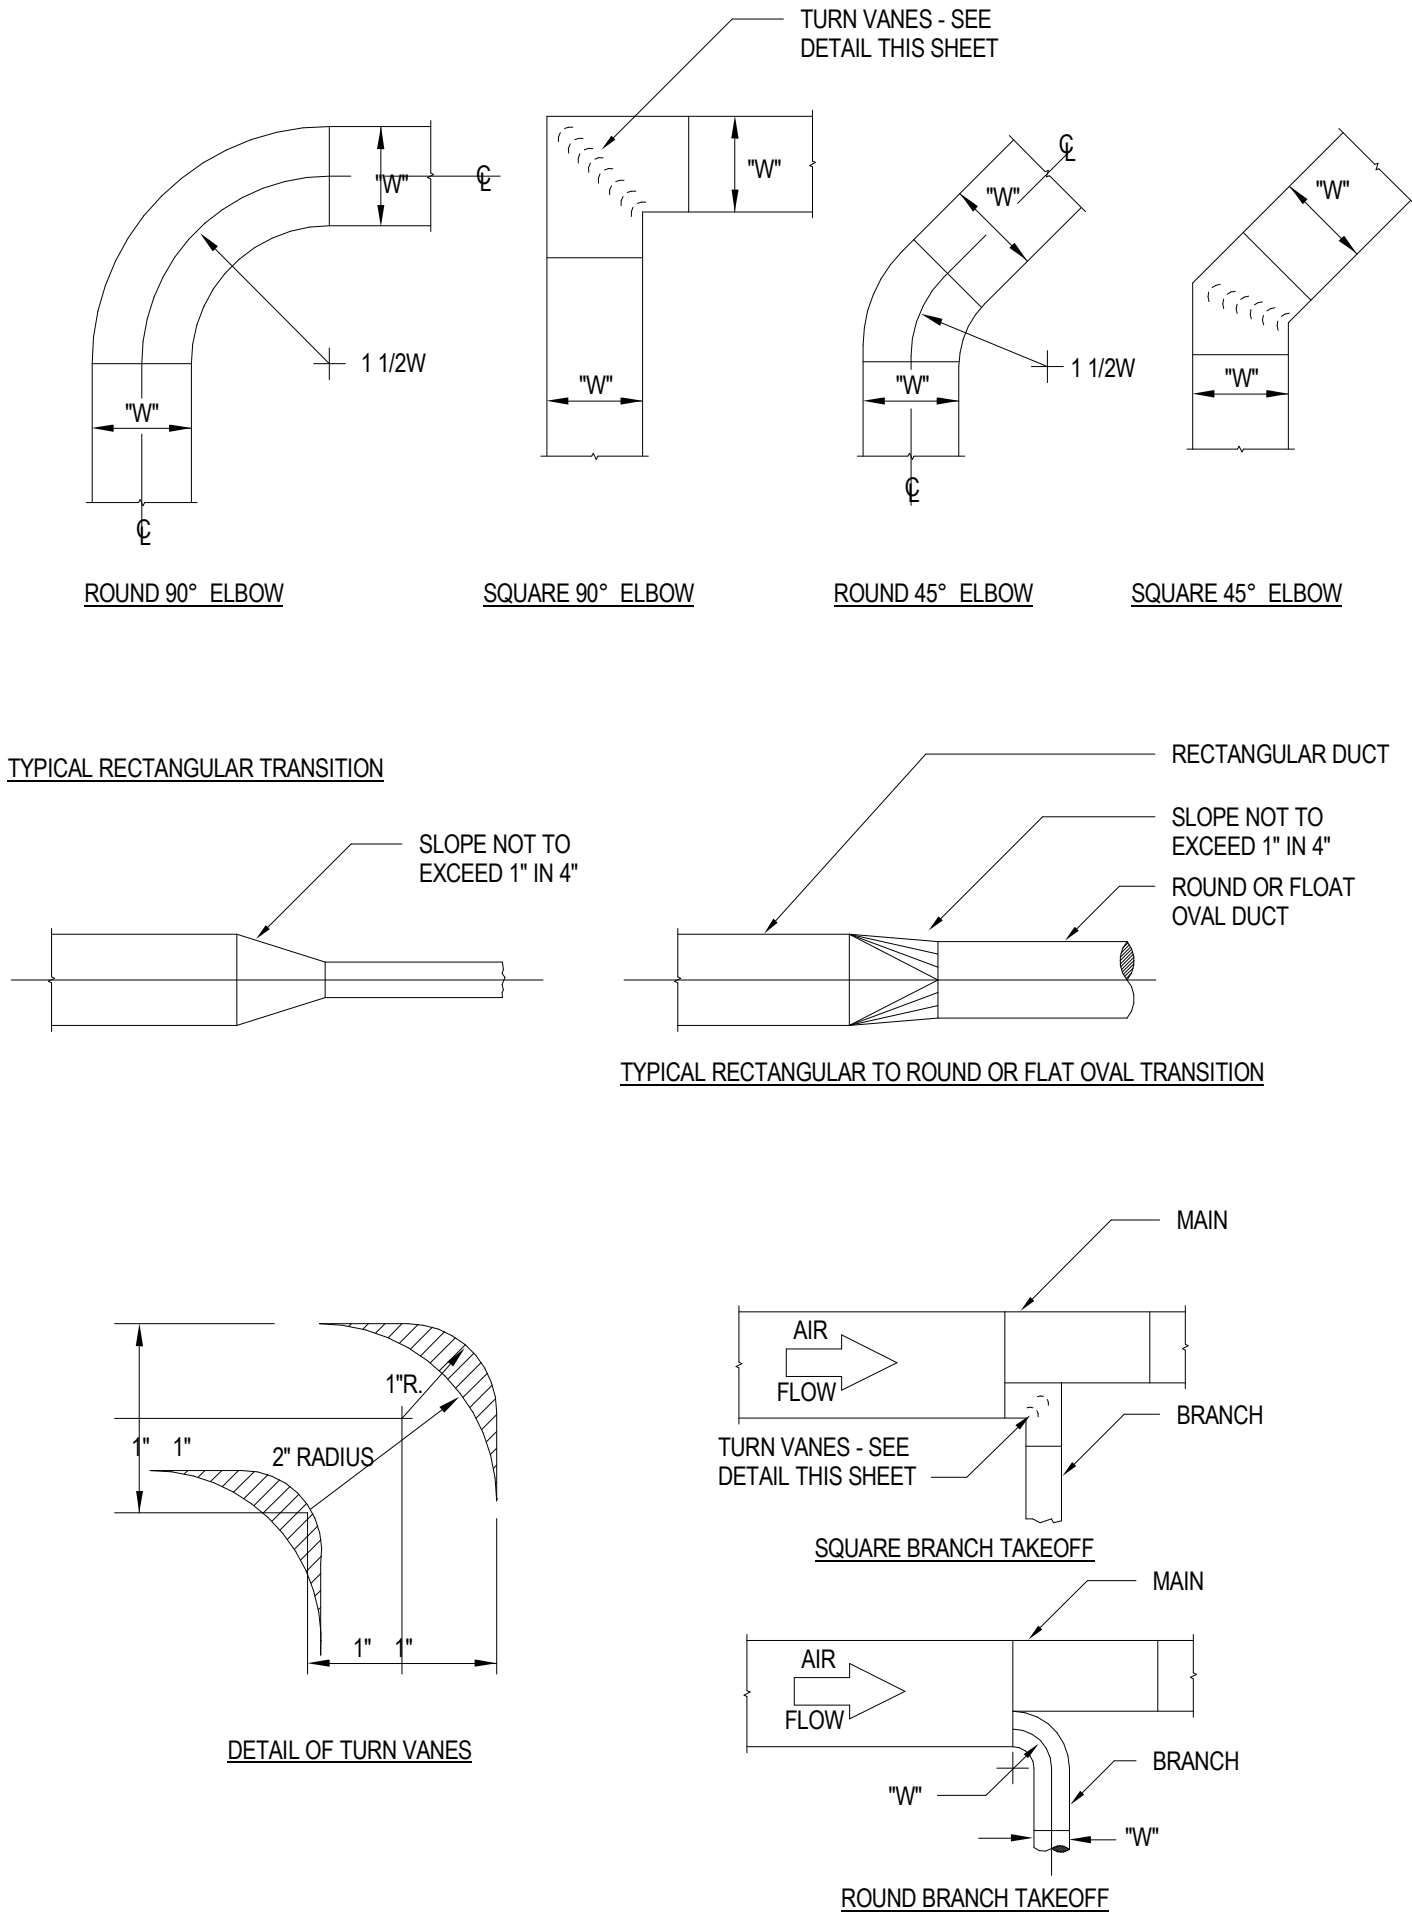

DUCT FITTINGS DETAIL

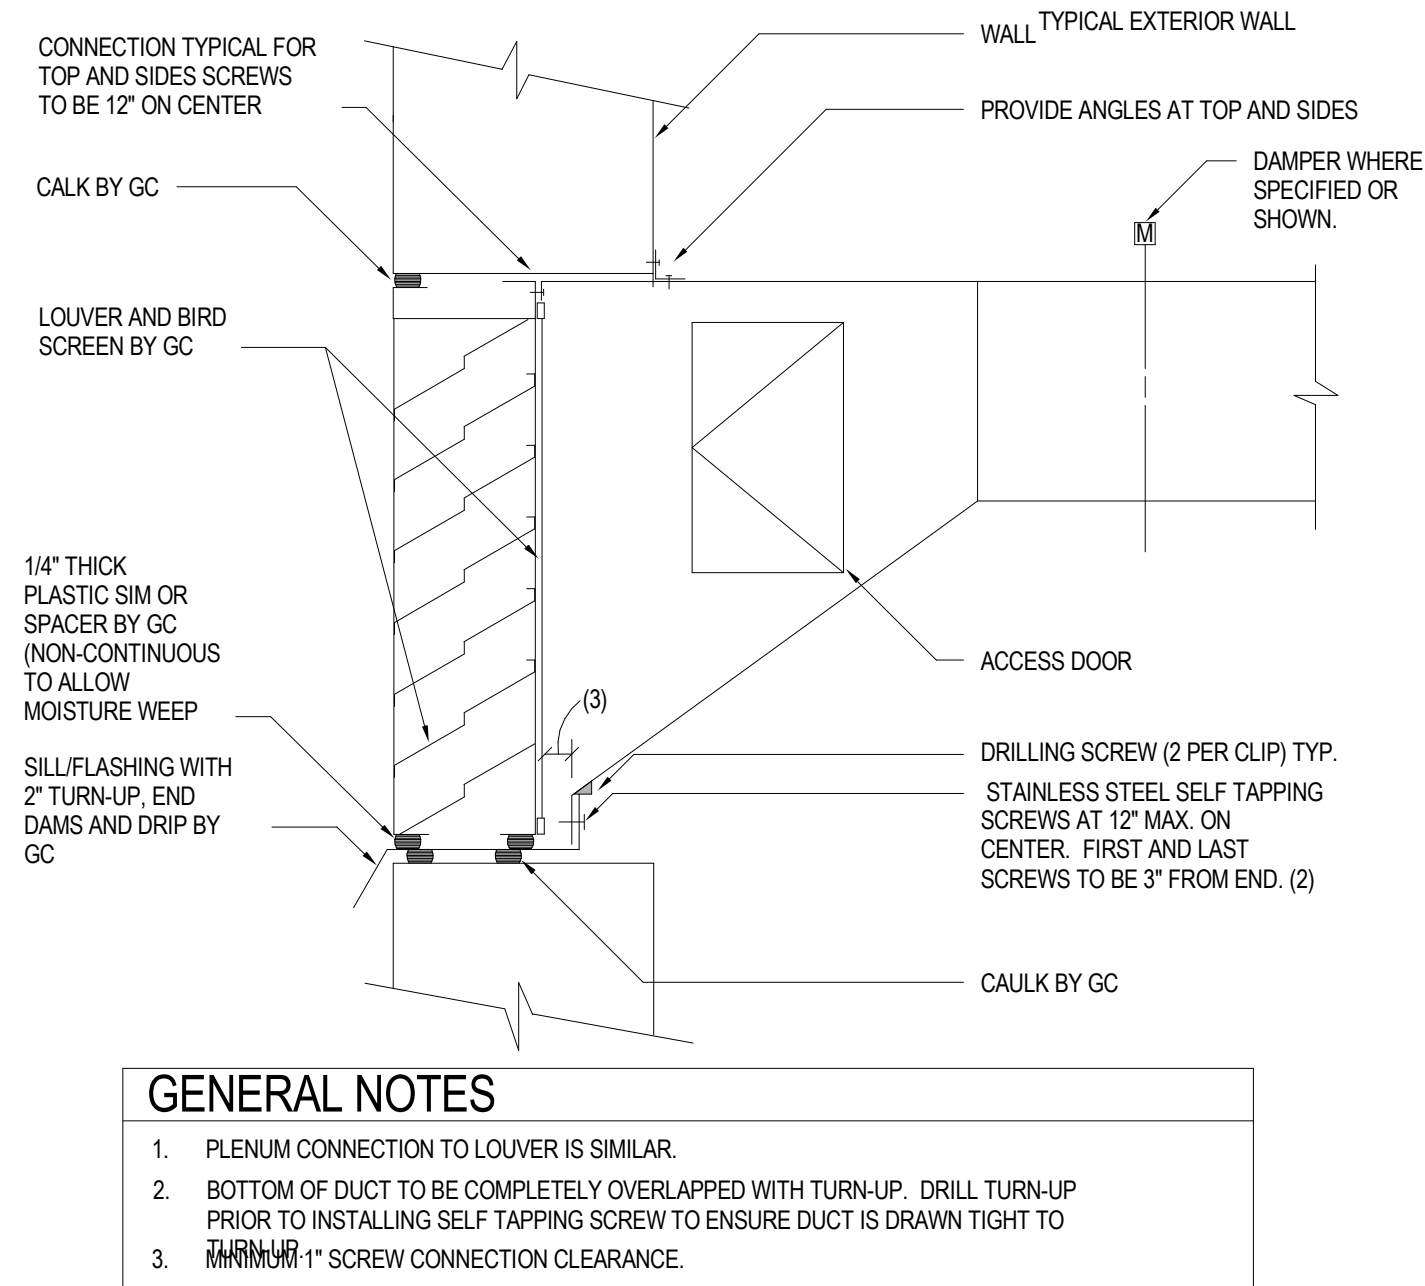

DUCT CONNECTION TO LOUVER

no.	description	date
	PERMIT SET	04.24.26

THE ARCHITECT'S COMMON LAW COPYRIGHT AND OTHER PROPERTY RIGHTS ARE HEREBY RESERVED IN THE IDEAS, DESIGNS, PLANS, DRAWINGS, AND SPECIFICATIONS SHALL NOT BE REPRODUCED OR CONVEYED IN ANY MANNER NOR ASSIGNED TO ANY THIRD PARTY WITHOUT FIRST OBTAINING THE EXPRESS WRITTEN PERMISSION OF THE ARCHITECT.

	System No. F-C-8014 F Rating — 1 Hr T Rating — 0 Hr 3. Through-Penetrants — Pipes, conduits, tubing and cables to be bundled and centered in the opening. The space between penetrants and the periphery of the opening shall be min 1/4 in. to max 3/4 in. Penetrants to be rigidly supported on both sides of the floor-ceiling assembly. A. Metallic Pipes — A max of two metallic pipes, conduits or tubing (one 3/4 in. diam and one 1/2 in. diam) to be installed within the firestop system. The following types and sizes of metallic pipes, conduits or tubing may be used: A1. Steel Pipe — Nom 3/4 in. diam (or smaller) Schedule 5 (or heavier) steel pipe. A2. Conduit — Nom 3/4 in. diam (or smaller) steel electrical metallic tubing or steel conduit. A3. Copper Tubing — Nom 3/4 in. diam (or smaller) Type L (or heavier) copper tubing. A4. Copper Pipe — Nom 3/4 in. diam (or smaller) Regular (or heavier) copper pipe. B. Nonmetallic Pipes — A max of one nonmetallic pipe to be installed within the firestop system. The following types and sizes of nonmetallic pipes may be used: B1. Polyvinyl Chloride (PVC) Pipe — Nom 1/2 in. diam (or smaller) Schedule 40 solid core PVC pipe for use in closed (process or supply) or vented (drain, waste or vent) piping systems. B2. Chlorinated Polyvinyl Chloride (CPVC) Pipe — Nom 1/2 in. diam (or smaller) SDR17 CPVC pipe for use in closed (process or supply) or vented (drain, waste or vent) piping systems. C. Cables — A max of two 4/C No. 18 AWG (or smaller) thermostat cables with PVC insulation and PVC/nylon jacketing material. D. Tube Insulation — Plastic — Nom 1/2 in. thick acrylonitrile butadiene/polyvinyl chloride (AB/PVC) flexible foam furnished in the form of tubing. Tube insulation to be installed on a max of one metallic pipe or tubing. See Plastics+ (CMFZ2) category in the Plastics Recognized Component Directory for names of manufacturers. Any Recognized Component tube insulation material meeting the above specifications and having a UL 94 Flammability Classification of 94-5VA may be used. 4. Fill, Void or Cavity Material — Sealant — Min 3/4 in. thickness of fill material applied within the annulus, flush with top surface of floor or sole plate. Min 5/8 in. thickness of fill material applied within the annulus, flush with the bottom surface of the ceiling or lower top plate. HILTI CONSTRUCTION CHEMICALS, DIV OF HILTI INC — FS — ONE Sealant *Bearing the UL Classification Marking +Bearing the UL Recognized Component Mark	FC-8014 
 Hilti Firestop Systems	Reproduced by HILTI, Inc. Courtesy of Underwriters Laboratories, Inc. September 18, 2007	Page: 2 of 2

FC 7013

System No. F-C-7013

2. Steel Duct — Nom 4 in. (102 mm) diam (or smaller) No. 28 gauge (or heavier) steel duct to be installed either concentrically or eccentrically within the firestop system. The annular space between duct and periphery of opening shall be min of 1/4 in. (6 mm) to max 3/4 in. (19 mm). Steel duct to be rigidly supported on both sides of floor-ceiling assembly.
3. Fill, Void or Cavity Materials—Sealant — Min 3/4 in. (19 mm) thickness of sealant applied within the annular space, flush with top surface of floor or sole plate, Min 5/8 in. (16 mm) thickness of sealant applied within annular space, flush with bottom surface of gypsum board or lower top plate, HILTI CONSTRUCTION CHEMICALS, DIV OF HILTI INC — FS-ONE Sealant or FS-ONE MAX Intumescent Sealant

* Indicates such products shall bear the UL or cUL Certification Mark for jurisdictions employing the UL or cUL Certification (such as Canada), respectively.



HilTI Firestop Systems

Reproduced by HILTI Inc. Courtesy of
Underwriters Laboratories, Inc.
January 20, 2015

Page: 2 of 2

OLD MEMORIAL

13600 National Golf Dr
Tampa, FL 33626

[illegible]

M6.04

DETAILS - MECHANICAL

CLASSIFIED




US

Classified by
Underwriters Laboratories, Inc.
to UL 1479 and CANULC-S115

System No. W-L-7042

ANSI/UL1479 (ASTM E814)	CAN/ULC S115
F Ratings - 1 and 2 Hr (See Items 1 and 3)	F Ratings - 1 and 2 Hr (See Items 1 and 3)
T Rating - 0 Hr	FT Rating - 0 Hr
	FH Ratings - 1 and 2 Hr (See Items 1 and 3)
	FTH Rating - 0 Hr

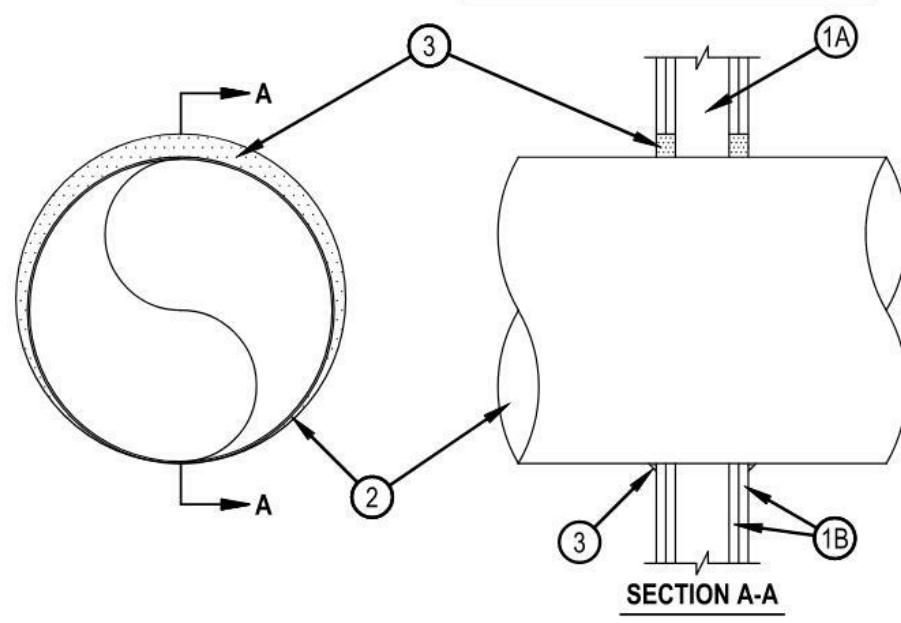

HILTI
Hilti Firestop Systems

Reproduced by HILTI, Inc. Courtesy of
Underwriters Laboratories, Inc.
October 12, 2017

Page: 1 of 2

CLASSIFIED



US

Classified by
Underwriters Laboratories, Inc.
to UL 1479 and CANULC-S115

System No. W-L-7042

1. Wall Assembly — The 1 or 2 hr fire rated wallboard/stud wall assembly shall be constructed of the materials and in the manner specified in the individual U300, U400, V400 or W400 Series Wall and Partition Designs in the UL Fire Resistance Directory and shall include the following construction features:

A. Studs — Wall framing may consist of either wood studs or steel channel studs. Wood studs to consist of nom 2 by 4 in. (51 by 102 mm) lumber spaced 16 in. (406 mm) OC. Steel studs to be min 2-1/2 in. (64 mm) wide and spaced 24 in. (610 mm) OC. Additional framing members shall be used to completely frame the opening for all ducts greater than 20 in. (502 mm) diam.

B. Gypsum Board — For 1 hr assembly, one layer of min 5/8 in. (16 mm) thick wallboard as required in the individual Wall and Partition Design. For 2 hr assembly, two layers of min 5/8 in. (16 mm) thick wallboard as required in the individual Wall and Partition Design. Max diam of opening is 14-1/2 in. (368 mm) for wood stud walls and 25-1/2 in. (648 mm) for steel stud walls.

The hourly F and FH Ratings of the firestop system are equal to the hourly fire rating of the wall assembly in which it is installed.

2. Through Penetrant — Galy steel duct to be installed concentrically or eccentrically within the firestop system. The annular space between the duct and periphery of opening shall be 0 in. (0 mm, point contact) and max 1-1/2 in. (64 mm) Duct to be rigidly supported on both sides of wall assembly.

A. Spiral Wound HVAC Duct — Nom 24 in. (610 mm) diam (or smaller) No. 28 MSG (or heavier) galv steel spiral wound duct.

B. Sheet Metal Duct — Nom 12 in. (305 mm) diam (or smaller) No. 28 MSG (or heavier) galv sheet steel duct.

3. Fill, Void or Cavity Material — Sealant — Min 5/8 in. (16 mm) and 1-1/4 in. (32 mm) thickness of fill material applied within annulus, flush with both surfaces of wall assembly for 1 and 2 hr F Ratings, respectively. When FS-ONE Max is used, min 5/8 in. (16mm) thickness for both 1 and 2 hr F Ratings. At the point contact location between duct and wallboard, a min 1/2 in. (13 mm) diam bead of sealant shall be applied at the wallboard/duct interface on both surfaces of wall assembly.

HILTI CONSTRUCTION CHEMICALS, DIV OF HILTI INC — CP601S Elastomeric Firestop Sealant, FS-ONE Sealant, FS-ONE MAX Intumescent Sealant or CP606 Flexible Firestop Sealant

* Indicates such products shall bear the UL or cUL Certification Mark for jurisdictions employing the UL or cUL Certification (such as Canada), respectively.

HILTI
Hilti Firestop Systems

Reproduced by HILTI, Inc. Courtesy of
Underwriters Laboratories, Inc.
October 12, 2017

Page: 2 of 2

CLASSIFIED




US

Classified by
Underwriters Laboratories, Inc.
to UL 1479 and CANULC-S115

System No. W-L-7153

ANSI/UL1479 (ASTM E814)	CAN/ULC S115
F Ratings - 1 and 2 Hr (See Item 1)	F Ratings - 1 and 2 Hr (See Item 1)
T Rating - 1/2 Hr	FT Rating - 1/2 Hr
	FH Ratings - 1 and 2 Hr (See Item 1)
	FTH Rating - 1/2 Hr

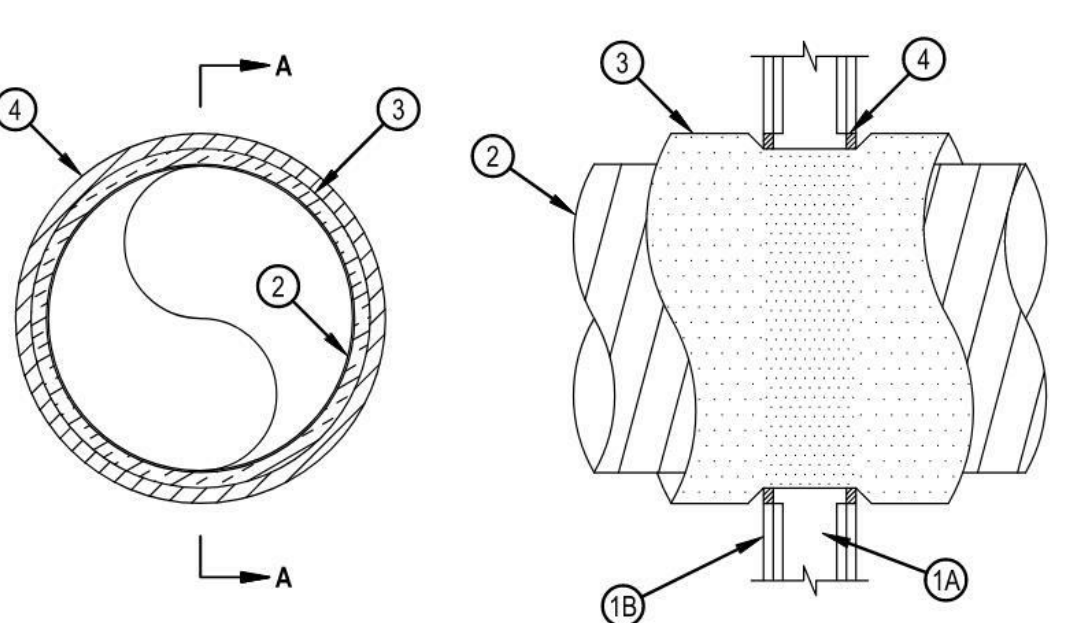


HILTI
Hilti Firestop Systems

Reproduced by HILTI, Inc. Courtesy of
Underwriters Laboratories, Inc.
November 15, 2017

Page: 1 of 2

 CLASSIFIED



US

Classified by
Underwriters Laboratories, Inc.
to UL 1479 and CANULC-S115

System No. W-L-7153

2. Steel Duct — Galv steel duct to be installed concentrically or eccentrically within the firestop system. Duct to be rigidly supported on both sides of wall assembly.

A. Spiral Wound HVAC Duct — Nom 20 in. (508 mm) diam (or smaller) No. 24 MSG (or heavier) galv steel spiral wound duct.

B. Sheet Metal Duct — Nom 12 in. (305 mm) diam (or smaller) No. 28 MSG (or heavier) galv sheet steel duct.

3. Duct Insulation — Nom 1-1/2 in. or 2 in. (38 or 51 mm) thick glass fiber batt or blanket (min 3/4 pcd or 56 kg/m3) jacketed on the outside with a foil-scrim-kraft facing. Longitudinal and transverse joints sealed with aluminum foil tape. During the installation of the fill material, the batt or blanket shall be compressed 50% such that the annular space within the firestop system shall be min 1/4 in. (6 mm) to max 1-1/2 in. (38 mm). See Batts and Blankets - (BKNV) category in the Building Materials Directory for names of manufacturers. Any batt or blanket meeting the above specifications and bearing the UL Classification Marking with a Flame Spread Index of 25 or less and a Smoke Developed Index 50 or less may be used.

4. Fill, Void or Cavity Material* — Sealant — Min 5/8 in. (16 mm) thickness of fill material applied within annulus, flush with both surfaces of wall. If voids develop after the fill materials cures, the voids shall be sealed with additional fill material.

HILTI CONSTRUCTION CHEMICALS, DIV OF HILTI INC — FS-ONE Sealant or FS-ONE MAX Intumescent Sealant

* Indicates such products shall bear the UL or cUL Certification Mark for jurisdictions employing the UL or cUL Certification (such as Canada), respectively.

HILTI
Hilti Firestop Systems

Reproduced by HILTI, Inc. Courtesy of
Underwriters Laboratories, Inc.
November 15, 2017

Page: 2 of 2

CLASSIFIED




US

Classified by
Underwriters Laboratories, Inc.
to UL 1479 and CANULC-S115

System No. W-L-7040

ANSI/UL1479 (ASTM E814)	CAN/ULC S115
F Ratings - 1 and 2 Hr (See Items 1 and 3)	F Ratings - 1 and 2 Hr (See Items 1 and 3)
T Rating - 0 Hr	FT Rating - 0 Hr
L Rating at Ambient - Less Than 1 CFM/sq ft	FH Ratings - 1 and 2 Hr (See Items 1 and 3)
L Rating at 400°F - Less Than 1 CFM/sq ft	FTH Rating - 0 Hr
	L Rating at Ambient - Less Than 1 CFM/sq ft
	L Rating at 400°F - Less Than 1 CFM/sq ft

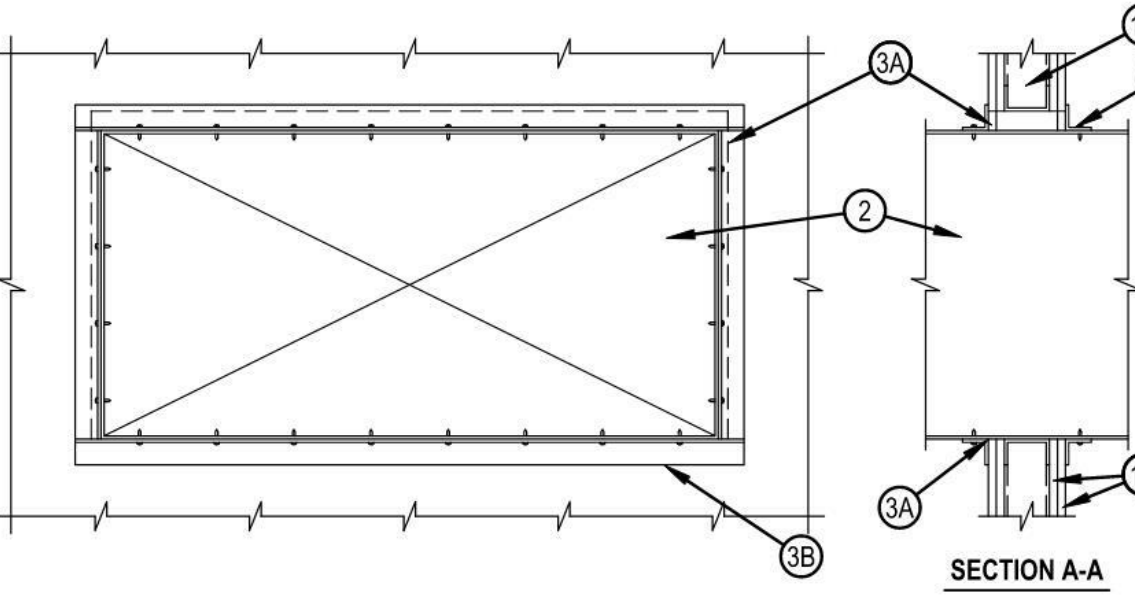

HILTI
Hilti Firestop Systems

Reproduced by HILTI, Inc. Courtesy of
Underwriters Laboratories, Inc.
September 16, 2015

Page: 1 of 2

CLASSIFIED



US

Classified by
Underwriters Laboratories, Inc.
to UL 1479 and CANULC-S115

System No. W-L-7040

3. Firestop System — The firestop system shall consist of the following:

A. Fill, Void or Cavity Material — Sealant — Min 5/8 in. (16 mm) thickness of fill material applied within annulus flush with both surfaces of wall. At point contact location, a min 1/2 in. (13 mm) diam bead of fill material shall be applied to the wall/duct interface on both surfaces of wall. HILTI CONSTRUCTION CHEMICALS, DIV OF HILTI INC — FS-ONE Sealant, FS-ONE MAX Intumescent Sealant, CP601S Elastomeric Firestop Sealant or CP606 Flexible Sealant

B. Steel Retaining Angle — No. 18 MSG (0.048 in.) galv steel angles cut to fit contour of duct with a 2 in. overlap on the duct and a min 1 in. overlap on the gypsum board assembly on both surfaces of wall. 2 in. leg of angle secured to duct with min No. 8 by 3/4 in. long sheet metal screws, spaced a max of 6 in. OC. When bead of fill material is used at joint contact locations, angles shall be installed prior to full material curing.

* Indicates such products shall bear the UL or cUL Certification Mark for jurisdictions employing the UL or cUL Certification (such as Canada), respectively.

HILTI
Hilti Firestop Systems

Reproduced by HILTI, Inc. Courtesy of
Underwriters Laboratories, Inc.
September 16, 2015

Page: 2 of 2

OLD MEMORIAL

13600 National Golf Dr
Tampa, FL 33626

no.	description	date
	PERMIT SET	04.24.26

M6.05
DETAILS -
MECHANICAL

WL 7059

System No. WL-7059

2. Steel Duct — Nom 24 In. by 12 In. (610 by 305 mm) or smaller No. 24 gauge (or heavier) steel duct to be installed eccentrically within the framed opening. The annular space shall be min 1 in. (25 mm) to max 1-3/4 in. (45 mm) Steel duct to be rigidly supported on both sides of wall assembly.
3. Batts and Blankets* — Max 1-1/2 In. (38 mm) thick glass fiber batt or blanket (min 3/4 pcf or 12 kg/m³) jacketed on the outside with a foil-faced kraft facing. Longitudinal and transverse joints sealed with aluminum foil tape. During the installation of the HILTI material, the batt or blanket shall be compressed 50% such that the annular space within the firestop system shall be min 1/4 in. (6 mm) to max 1 in. (25 mm). See Batts and Blankets - (BKNV) category in the Building Materials Directory for names of manufacturers. Any batt or blanket meeting the above specifications and bearing the UL Classification Marking with a Flame Spread Index of 25 or less and a Smoke Developed Index 50 or less may be used.
4. HILTI Void or Core Material* - Sealant — Min 5/8 in. or 1-1/4 in. (16 or 32 mm) thickness of HILTI material applied within annulus. Flush with both surfaces of wall for 1 or 2 hr walls, respectively. If voids develop after the HILTI materials cures, the voids shall be sealed with additional HILTI material.

HILTI CONSTRUCTION CHEMICALS, DIV OF HILTI INC — FS-ONE Sealant or FS-ONE MAX Intumescent Sealant

* Indicates such products shall bear the UL or cUL Certification Mark for jurisdictions employing the UL or cUL Certification (such as Canada), respectively.

WIL 7151

System No. W-L-7151

4. Firestop System — The firestop system shall consist of the following:

- A. Packing Material — Min 3-1/2 in. (89 mm) thickness of min 4.0 pcf (64 kg/m³) mineral wool batt insulation firmly packed into the opening as a permanent form. Packing material to be recessed from both sides of the wall to accommodate the required thickness of fill material.
- B. Fill, Void or Cavity Material — Sealant — Min 5/8 in. (16 mm) thickness of fill material applied within annulus flush with both surfaces of the wall.

C. Steel Retaining Angle — No. 18 MSG (or heavier) galv steel angles. When duct dimension exceeds 48 in. (1219 mm), angles shall be

- No. 16 MSG (or heavier). Angles cut to fit contour of duct with a 2 in. (51 mm) overlap on the duct and a min 1 in. (25 mm) overlap on the gypsum board assembly on both surfaces of wall. 2 in. (51 mm) leg of angle secured to duct with min No. 8 by 3/4 in. (19 mm) long sheet metal screws, spaced a max of 6 in. (152 mm) OC. Angles are optional for ducts 30 in. (762 mm) by 24 in. (610 mm) and smaller. In addition, see table below for additional conditions and options regarding retaining angles.

Max Duct Dimension	Duct Thickness	Max Insulation Thickness (Item 3)	Annular Space	Packing Material (Item 4A) Required	Angle (Item 4C) Required	T-Rating Hr
24 in. (610 mm)	24 ga or heavier	1-1/2 in. (38 mm)	1/4 in. min to 1 in. max (6 to 25 mm)	No	No	0
25 in. (635 mm) wide by 45 in. (1143 mm) high	24 ga or heavier	2 in. (51 mm)	1/4 in. min to 3-1/2 in. max (6 to 89 mm)	Yes	No	1 and 2 (Same as wall rating)

** Indicates that when max 1-1/2 in. (38 mm) thick insulation is used, steel angles are optional for those sides of the duct that do not exceed the dimension specified.

* Indicates such products shall bear the UL or cUL Certification Mark for jurisdictions employing the UL or cUL Certification (such as Canada), respectively.

HILTI
Hilti Firestop Systems

Reproduced by HILTI, Inc. Courtesy of
Underwriters Laboratories, Inc.
August 22, 2016

Page: 2 of 2

REFERENCE NOTES:

1

EXISTING SUMP PIT/PUMP TO REMAIN. EXTEND/MODIFY EXISTING SUMP PUMP DRAINAGE PIPING AS NECESSARY TO RECONNECT TO RELOCATED ESD WATER TREATMENT EQUIPMENT.

2

EXISTING RECYCLED WATER STORAGE TANK, EXPANSION TANK, MOTOR CONTROLLER AND PUMP SKID TO BE RELOCATED AS SHOWN.

3

EXISTING ESD WASTE2WATER RECYCLED WATER FILTRATION EQUIPMENT TO BE RELOCATED AS SHOWN. RECONNECT PIPING FROM SUMP DRAINAGE TO ESD AND SUPPLY WATER PIPING TO EXISTING STORAGE TANK. EXTEND HOSES FROM ESD TO CART WASH BAY AREAS. FINAL RECYCLED WATER HOSE LOCATIONS SHALL BE COORDINATED WITH OWNER.

4

EXISTING SANITARY HUB DRAIN ABOVE GRADE TO REMAIN.

5


3/4" POTABLE CW SUPPLY BELOW GRADE, FOR CONT. SEE CIVIL PLANS. SHUT-OFF VALVE IN CAST IRON ACCESS BOX FLUSH WITH GRADE.

6

PROVIDE 3/4" MAKE-UP WATER CONNECTION TO RECYCLED WATER STORAGE TANK. INSTALL RBPB-1 UPSTREAM OF TANK CONNECTION. COORDINATE EXACT LOCATION WITH EXITING EQUIPMENT.

7


EXISTING LINEAR TRENCH DRAIN TO BE REMOVED AND CONCRETE SLAB FILLED IN TO MATCH EXISTING.

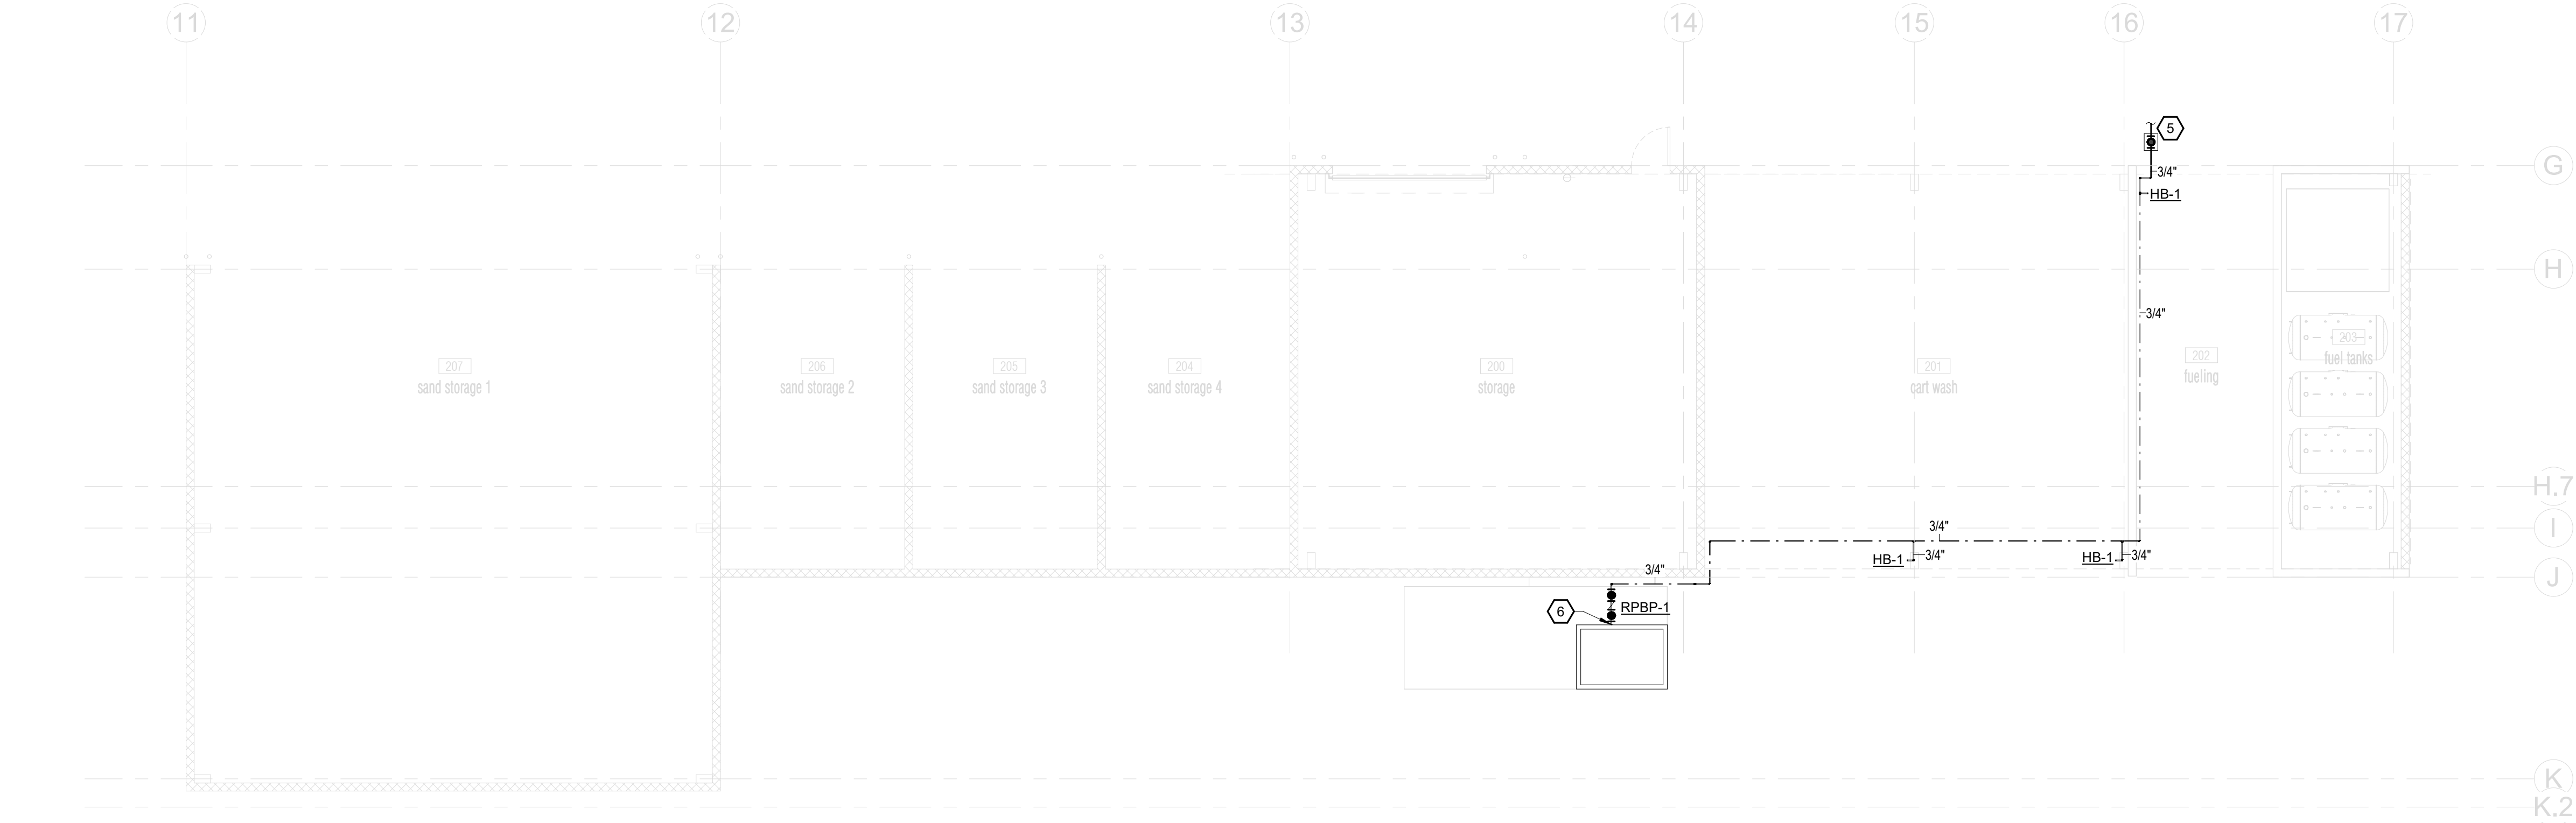

2

SAND AND CHEM STORAGE - DOMESTIC WATER - FLOOR PLAN - PLUMBING

1/8" = 1'-0"

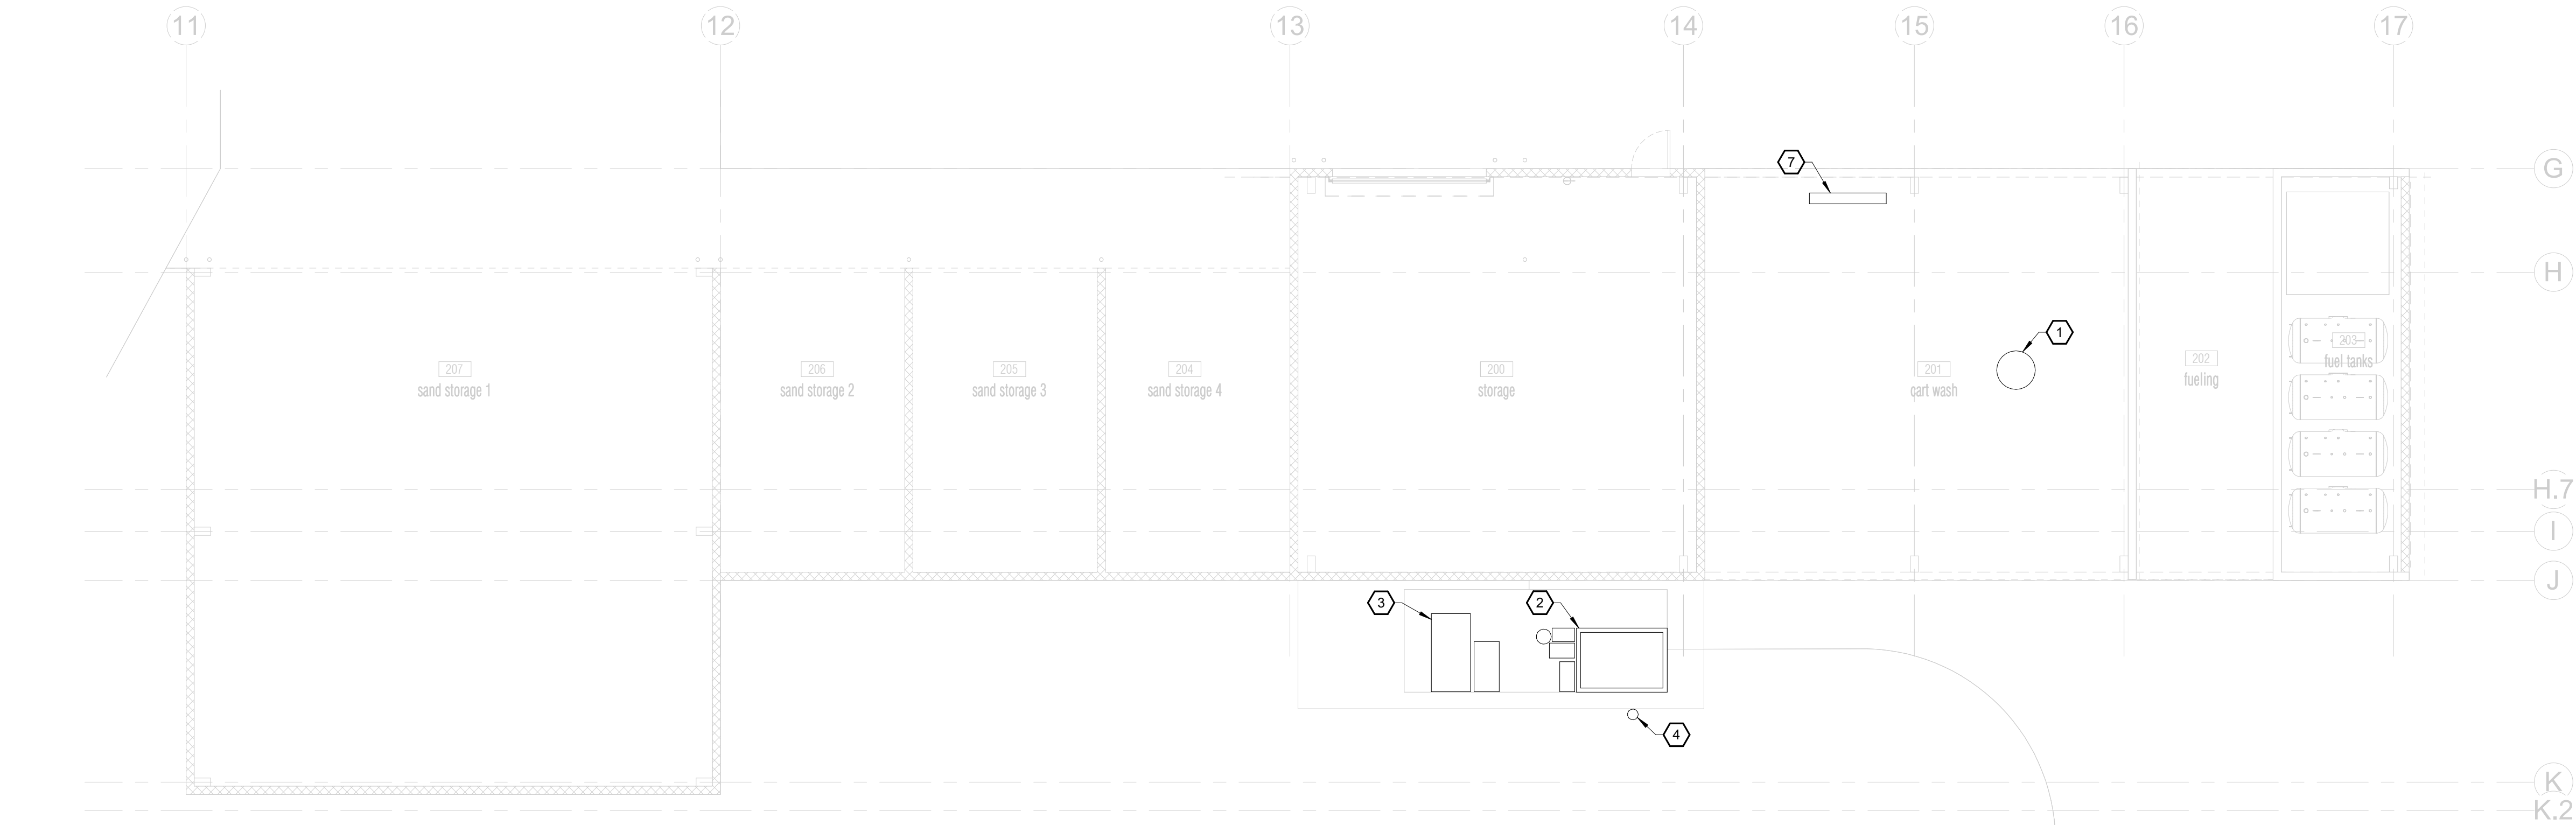

1

SAND AND CHEM STORAGE - SANITARY SEWER - FLOOR PLAN - PLUMBING

1/8" = 1'-0"


OLD MEMORIAL

13600 National Golf Dr
Tampa, FL 33626


no.	description	date
PERMIT SET		04.24.26

P1.02.0



BUILDING 2 - FLOOR
PLANS - PLUMBING

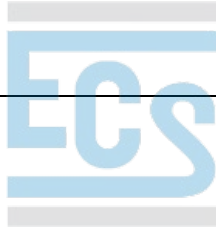


Electrical Review - Roger Sanders PX651 - Reviewed - 7/14/2026
Mechanical Review - Roger Sanders PX651 - Reviewed - 7/14/2026
Plumbing Review - Roger Sanders PX651 - Reviewed - 7/14/2026
Fire Review - Jay Traina - NA to Private Provider - 7/16/2026
Building Review - Roger Sanders PX651 - Reviewed - 7/14/2026

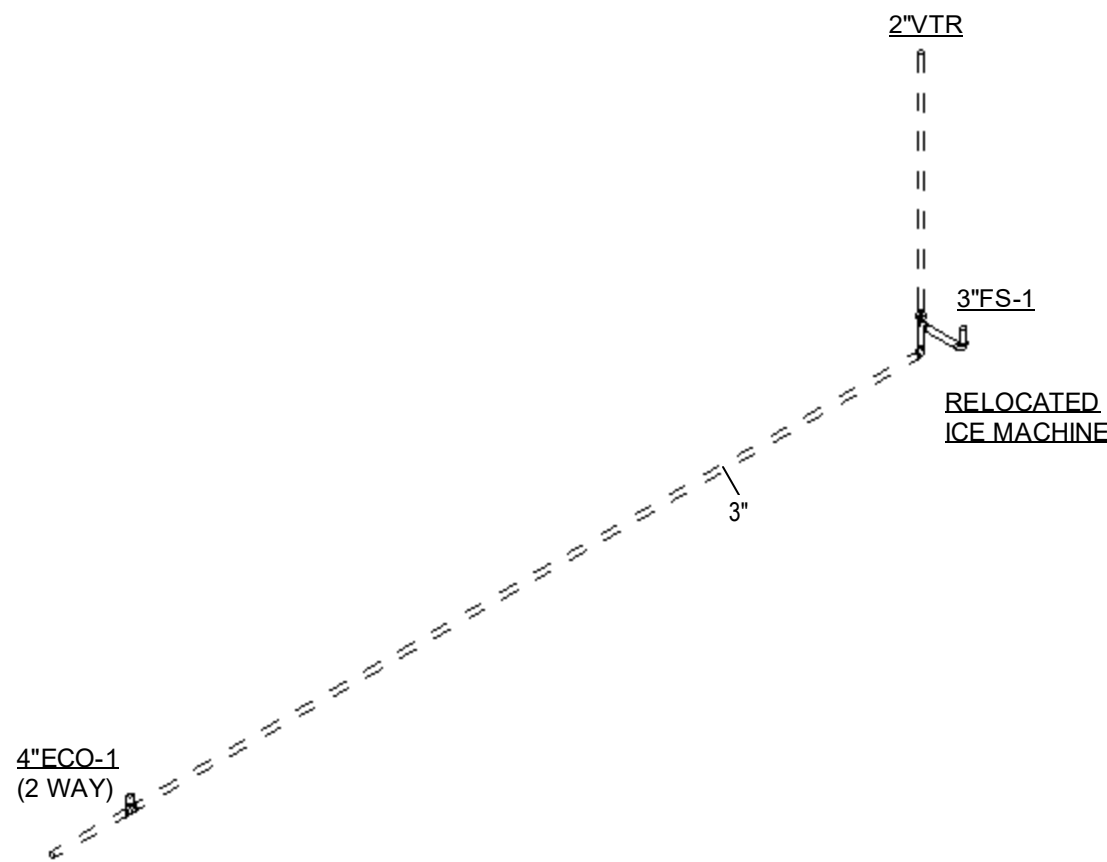


1 SANITARY RISER DIAGRAM - MAINTENANCE BUILDING

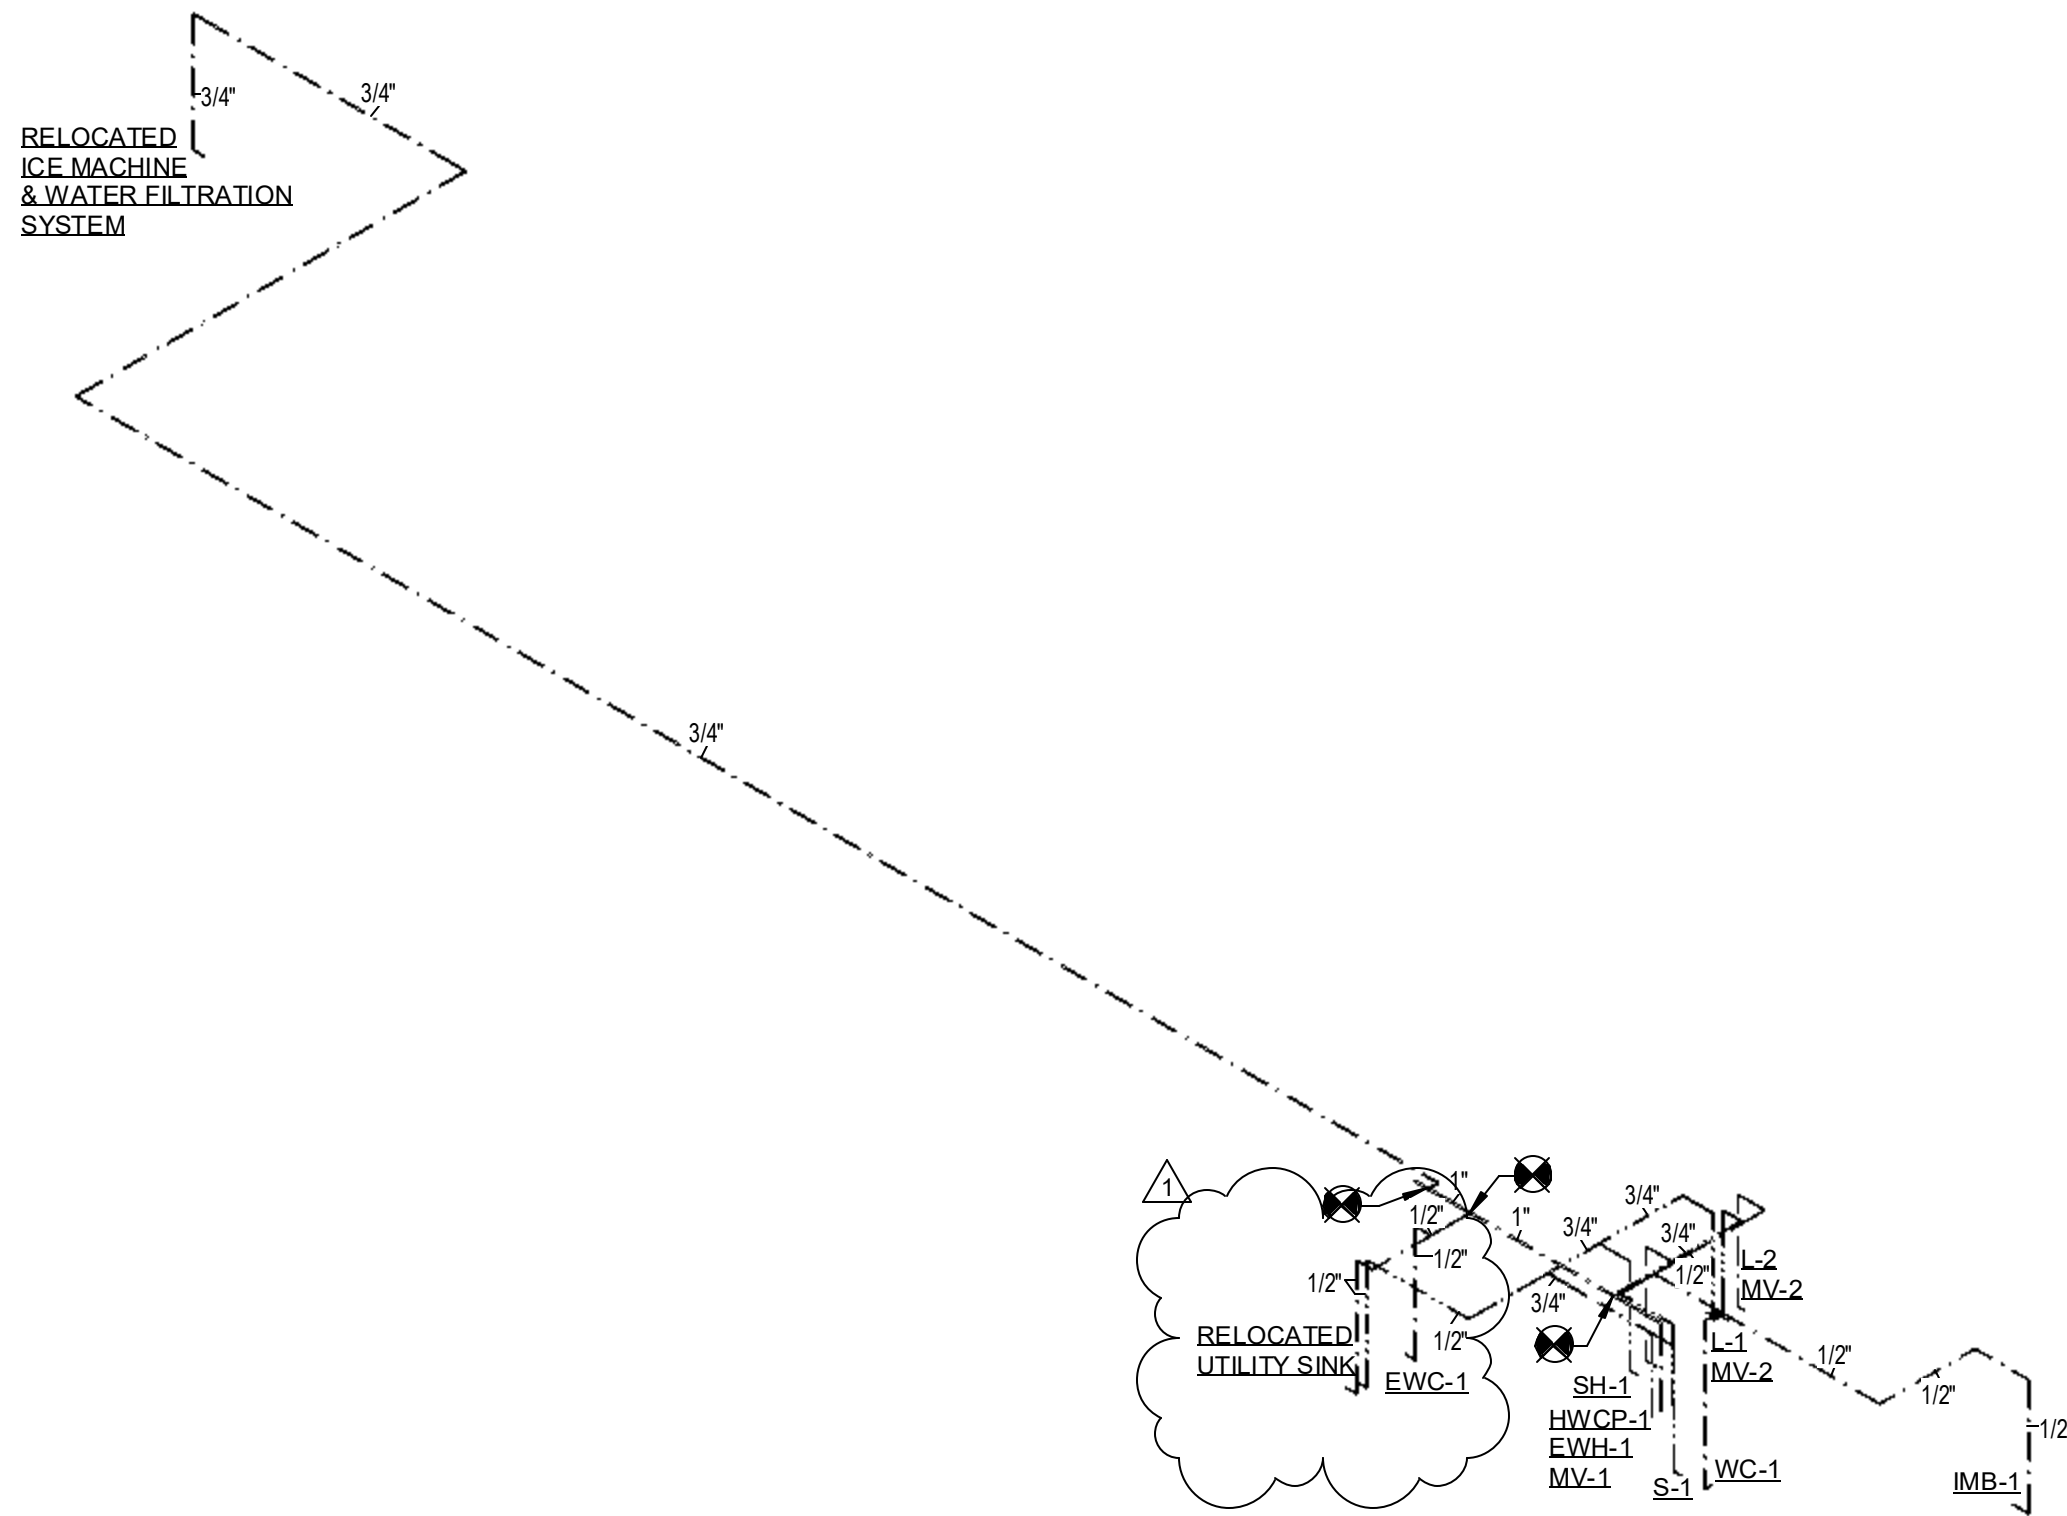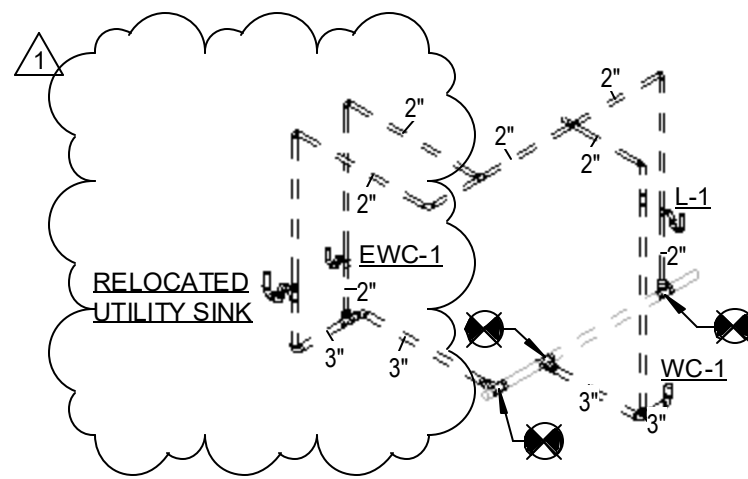

2 DOMESTIC WATER RISER DIAGRAM - MAINTENANCE BUILDING

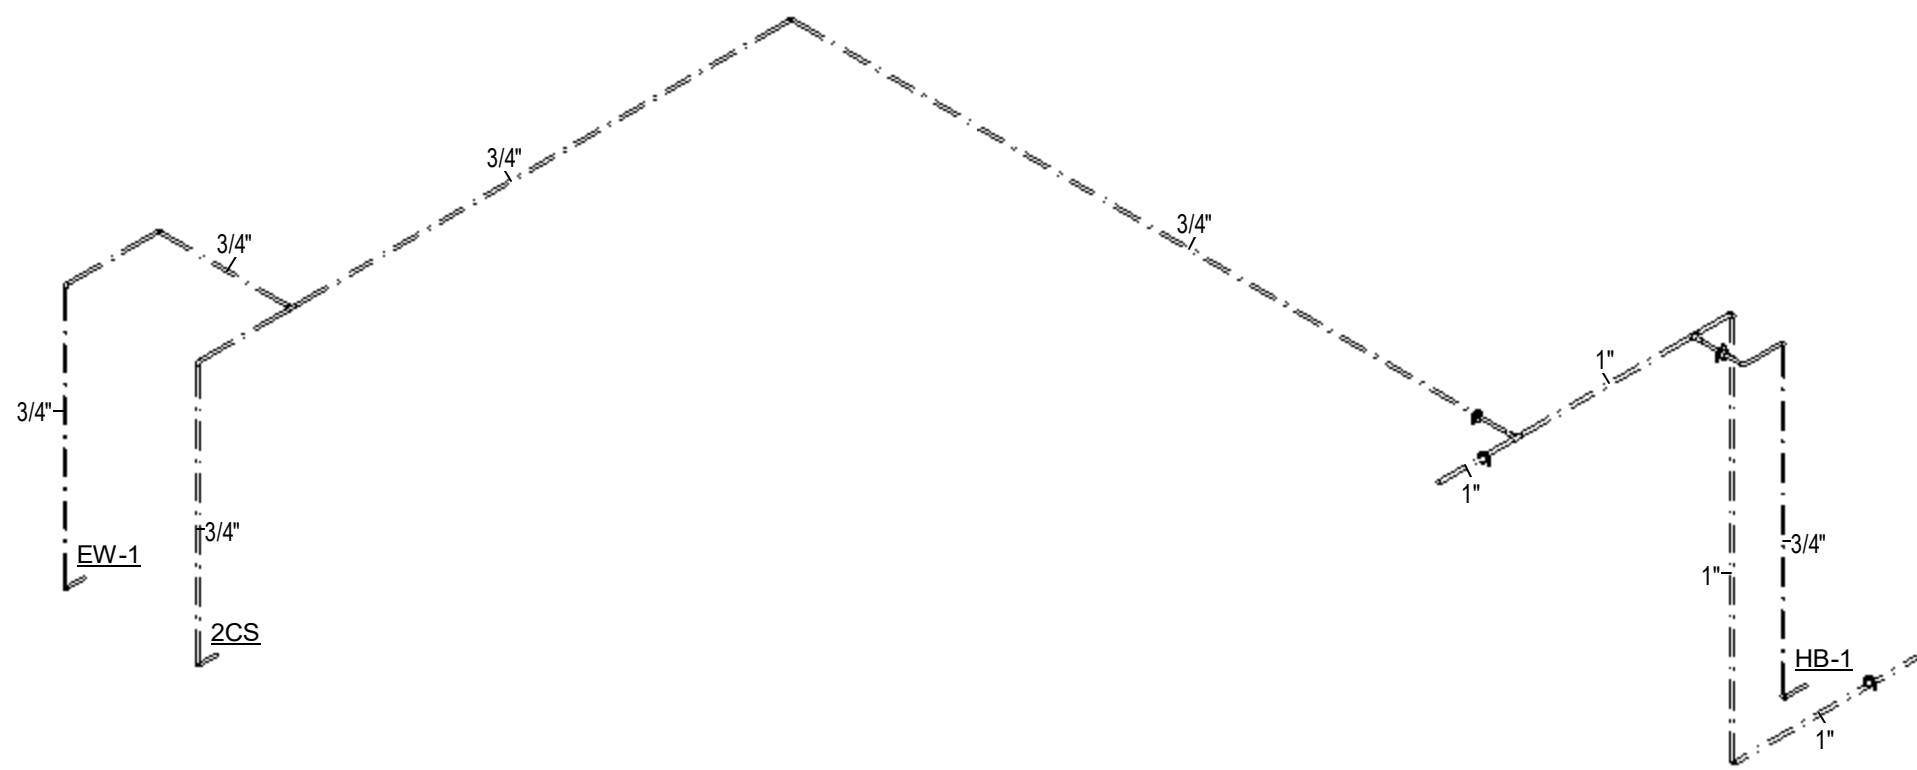

3 DOMESTIC WATER RISER DIAGRAM - CHEM STORAGE

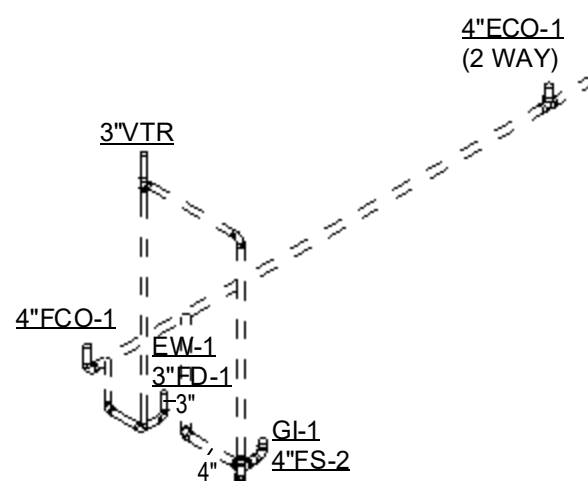


4 SANITARY RISER DIAGRAM - CHEM STORAGE


OLD MEMORIAL

13600 National Golf Dr
Tampa, FL 33626


no.	description	date
	PERMIT SET	04.24.26
1	PERMIT COMMENTS	06.19.26

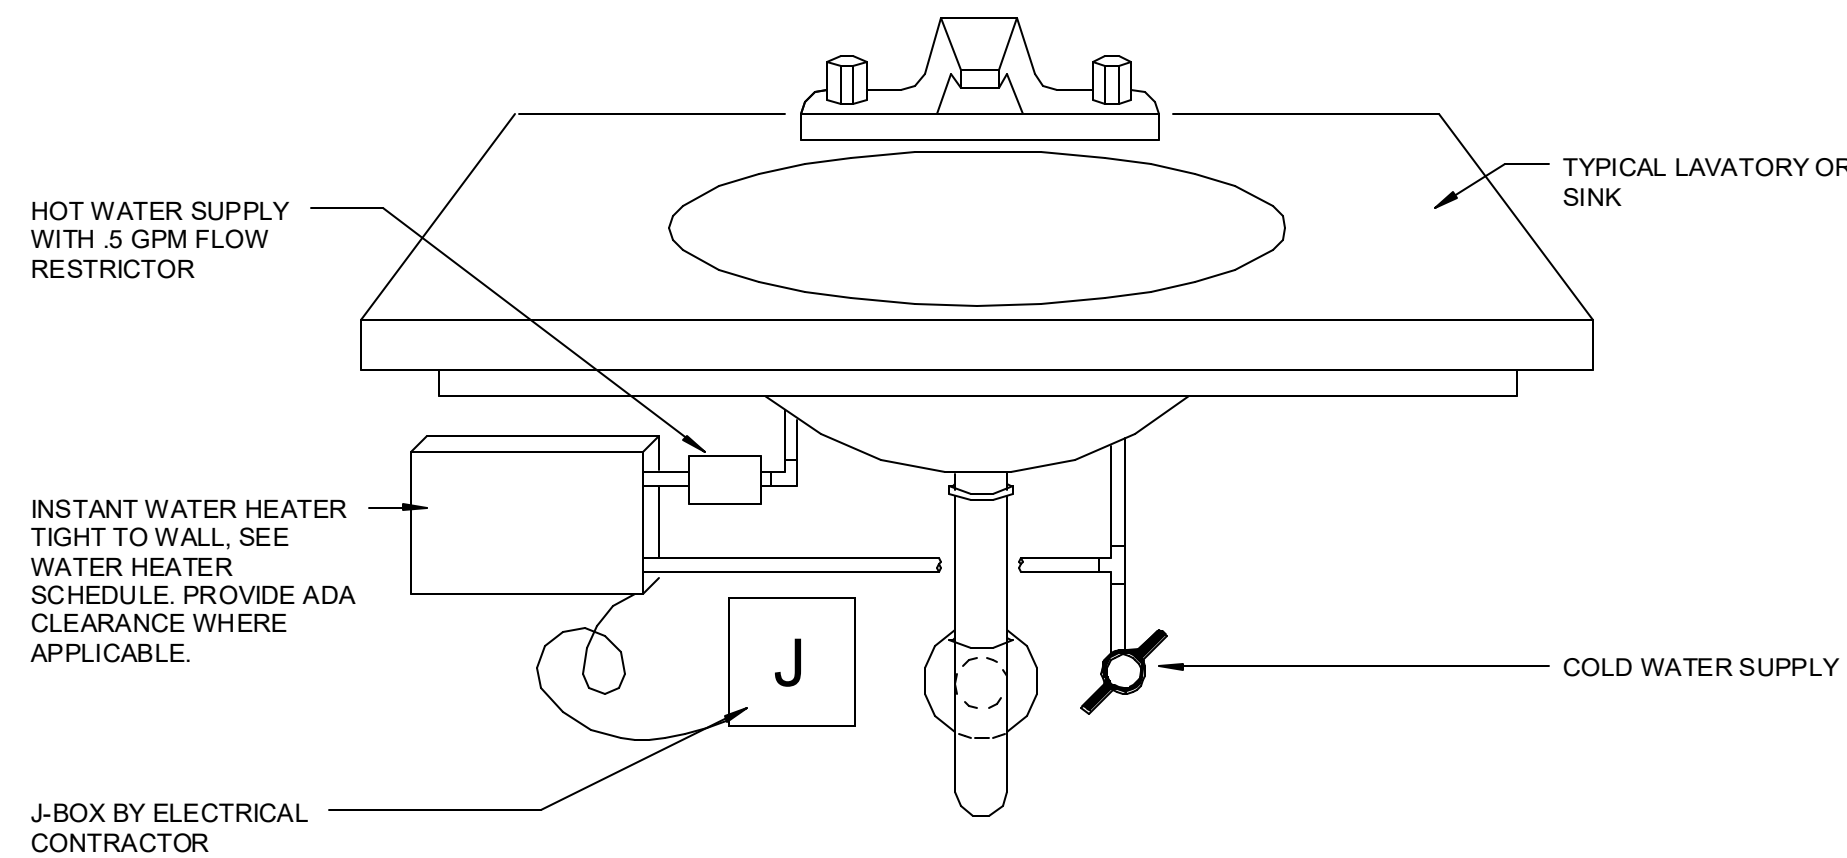


6 INSTANTANEOUS WATER HEATER DETAIL
12" = 1'-0"

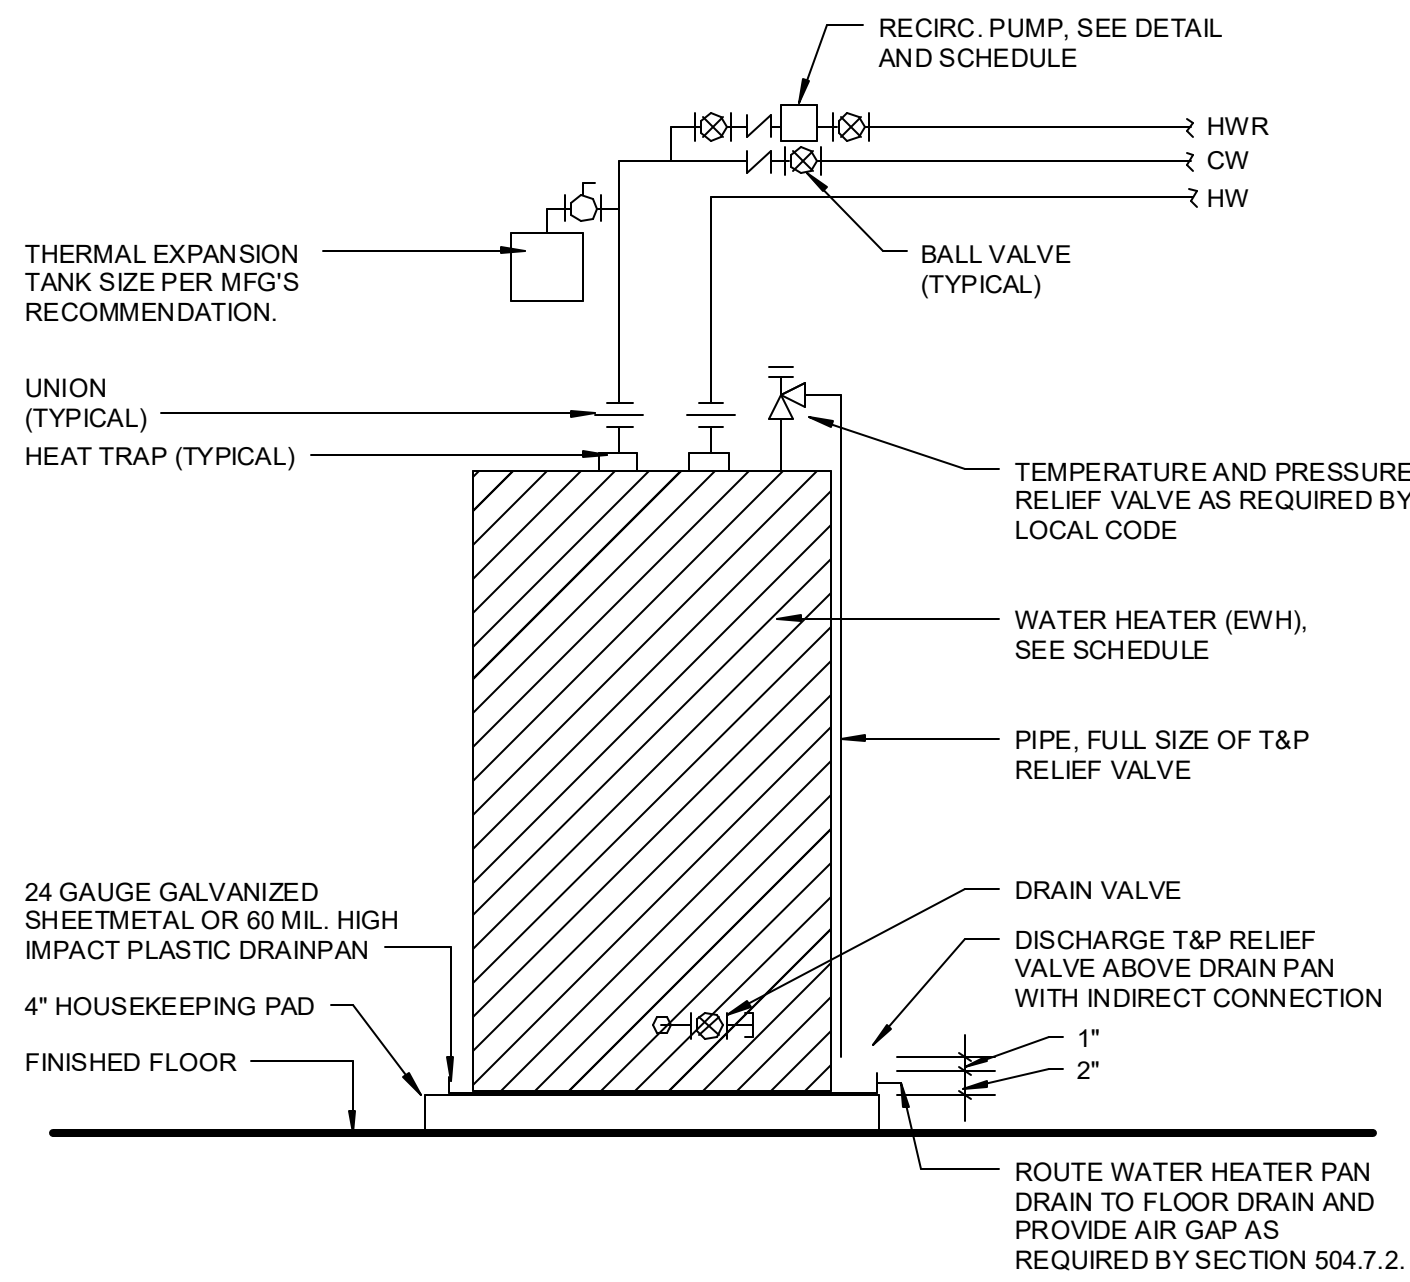


3 ELECTRIC WATER HEATER DETAIL
12" = 1'-0"

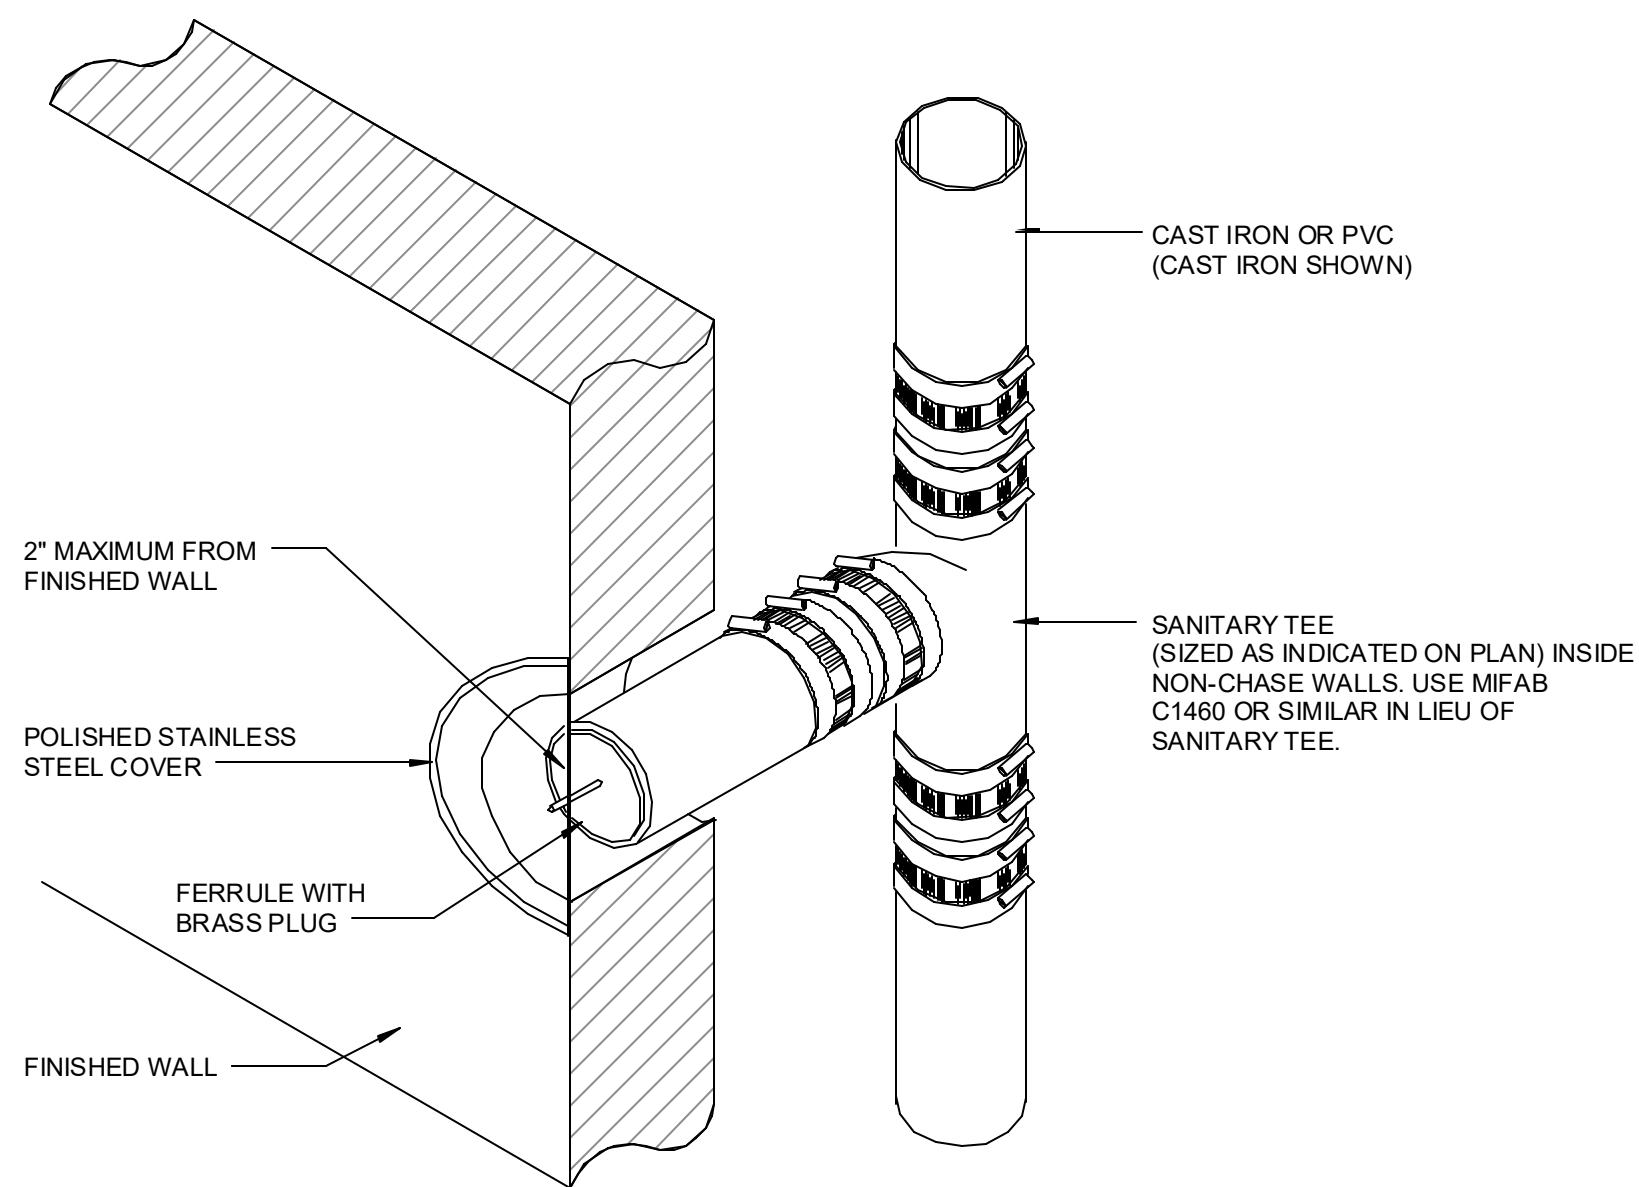


8 WALL CLEANOUT
12" = 1'-0"

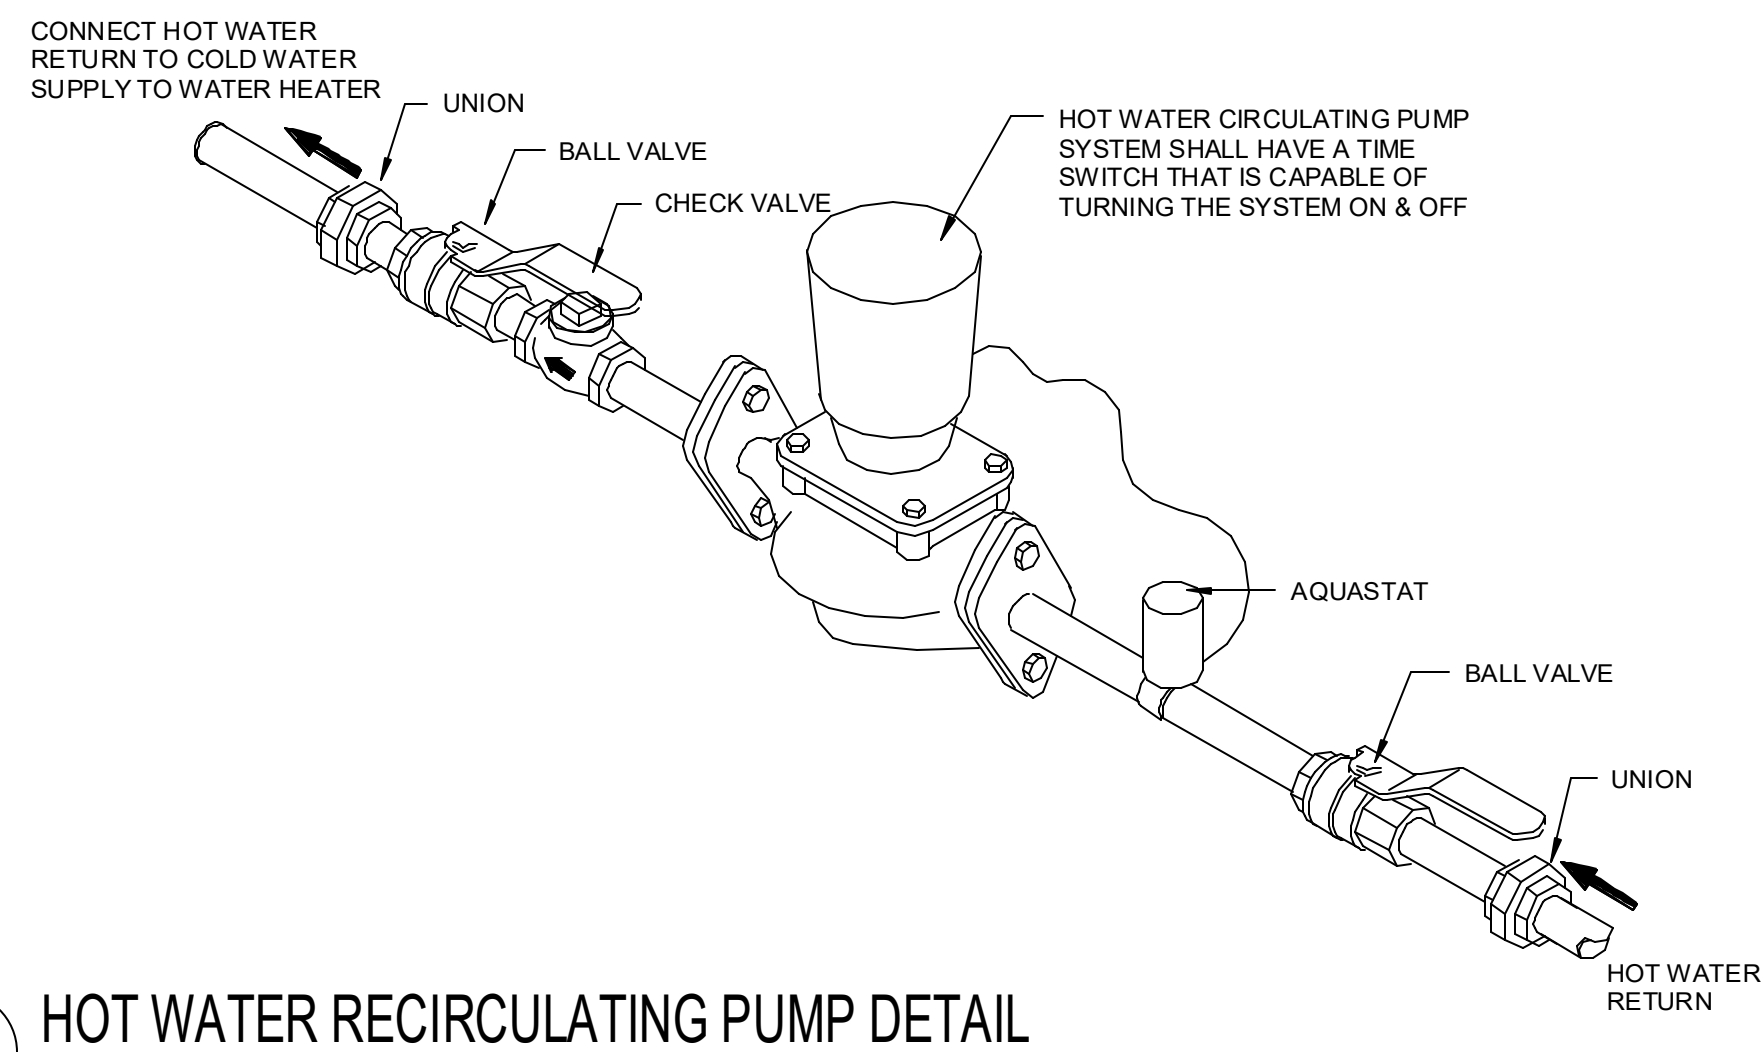


5 HOT WATER RECIRCULATING PUMP DETAIL
12" = 1'-0"

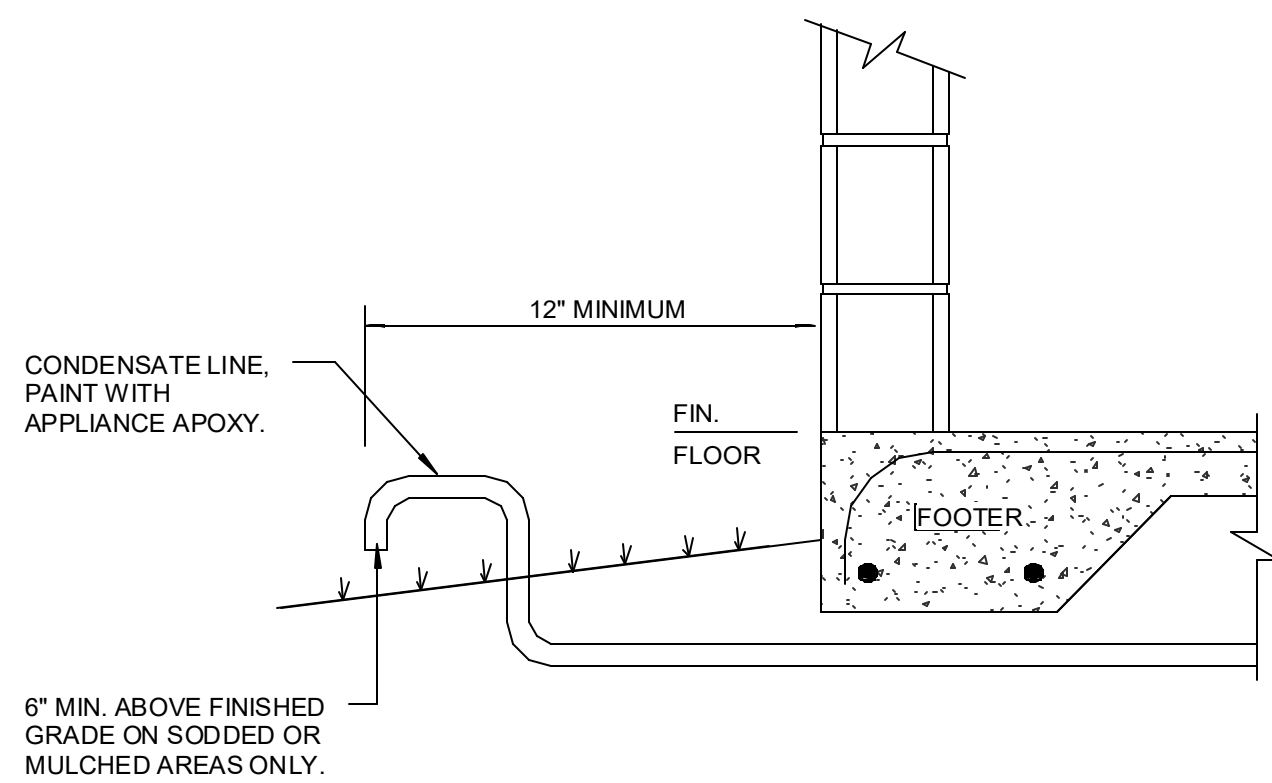


2 CONDENSATE / PAN DRAIN TERMINATION DETAIL
12" = 1'-0"

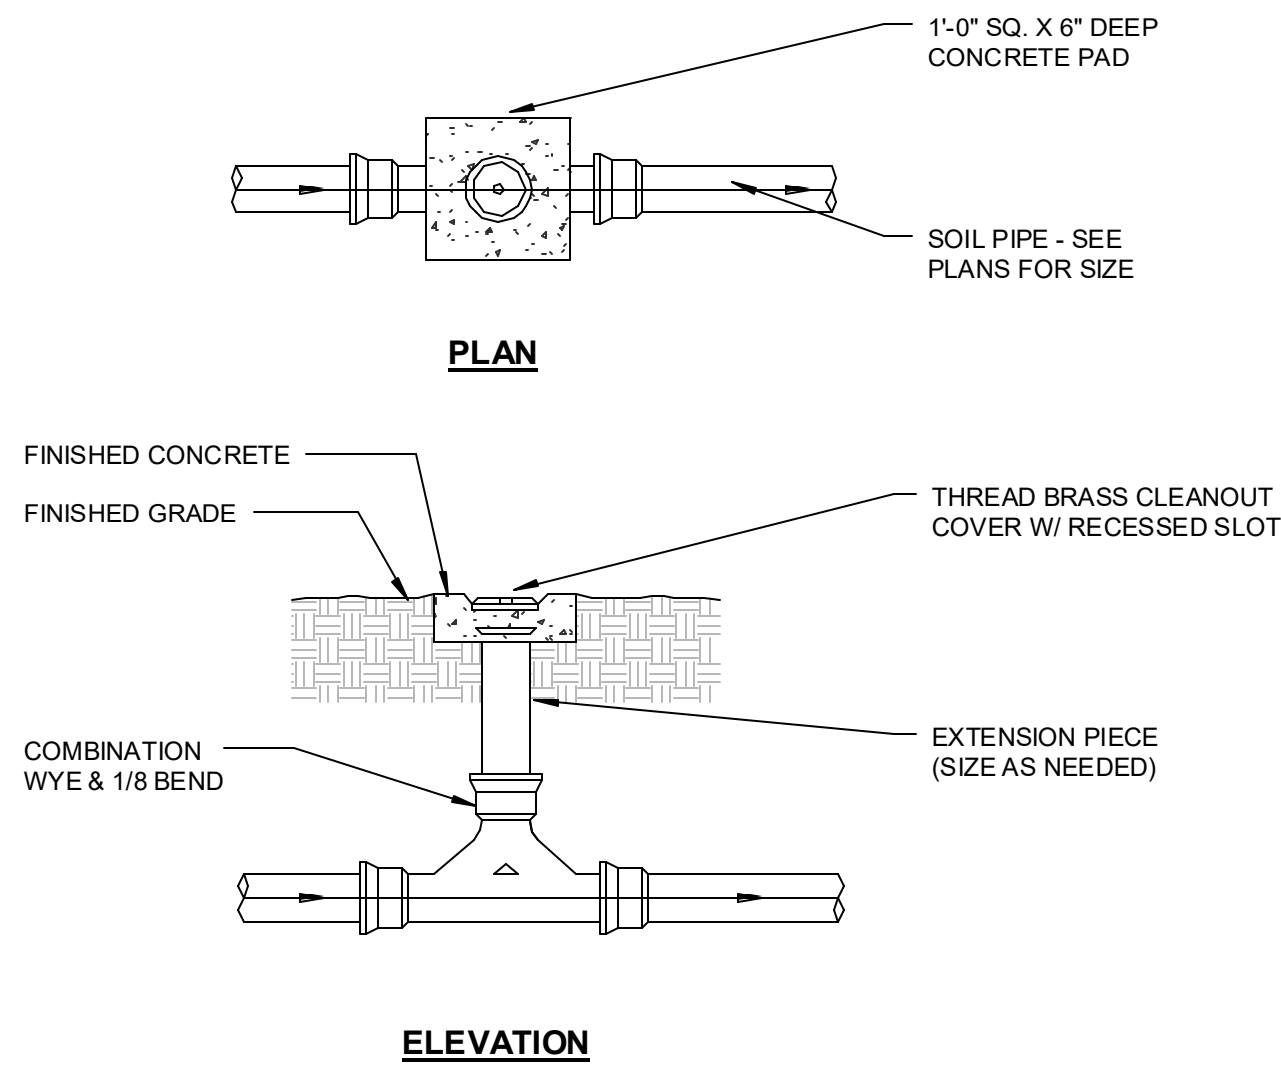

7 TWO WAY CLEANOUT
12" = 1'-0"

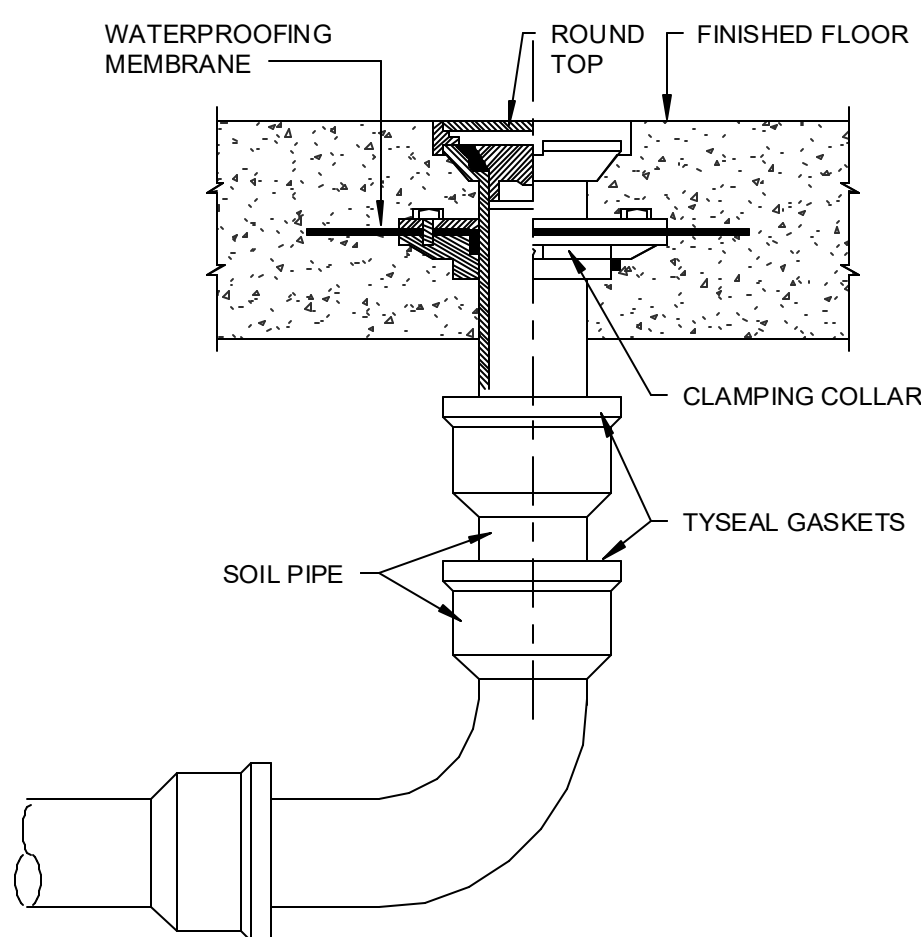

4 FLOOR CLEANOUT
12" = 1'-0"

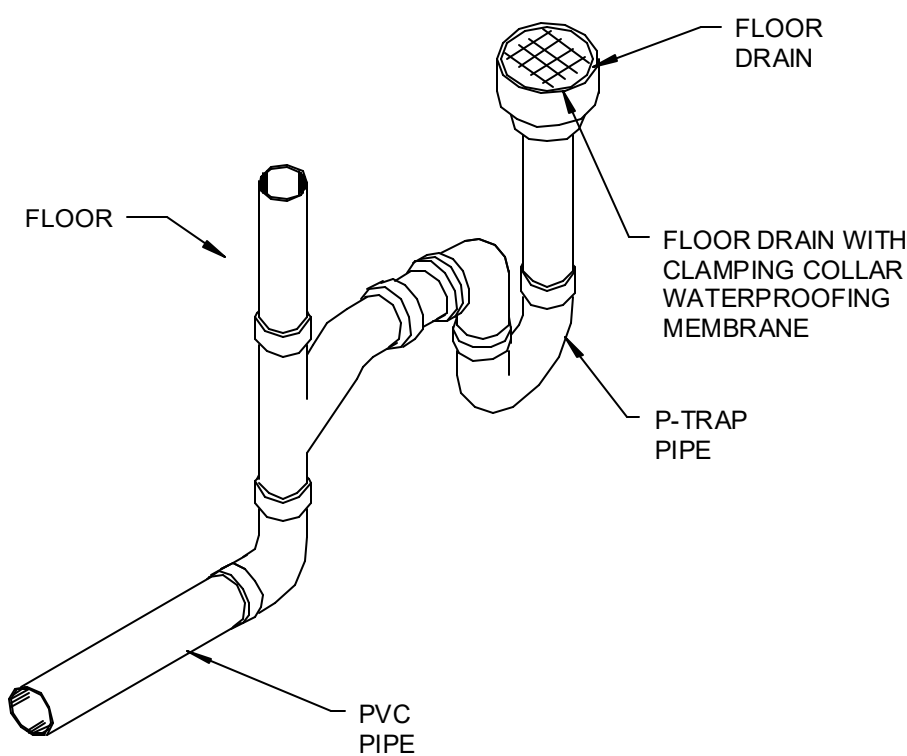

1 AHU CONDENSATE, DRAIN PAN & T&P VALVE HUB DRAIN
12" = 1'-0"

OLD MEMORIAL

13600 National Golf Dr
Tampa, FL 33626

no.	description	date
	PERMIT SET	04.24.26

P5.01
DETAILS -
PLUMBING

PLUMBING FIXTURE SCHEDULE								
MARK	FIXTURE	WASTE	TRAP	VENT	COLD WATER	HOT WATER	MANUFACTURER /MODEL #	DESCRIPTION
AAV-1	AIR ADMITTANCE VALVE	1-1/2"	-	-	-	-	STUDD TEC-VENT	Mount in accessible location for maintenance.
WHA-1	WATER HAMMER ARRESTOR	-	-	-	-	-	SIoux CHIEF 650 SERIES	SIZE PER MANUFACTURER'S RECOMMENDATIONS. PDI CERTIFIED. WHA-1: SIZE "A" WHA-2: SIZE "B" REFER TO RISER DIAGRAMS FOR ARRESTOR LOCATIONS. REFER TO SPECIFICATION FOR SELECTION METHOD.
ECO-1	EXTERIOR CLEAN-OUT	SIZE/ SEE DWG.	-	-	-	-	ZURN ZS1400-VP	"LEVEL-TROL" ADJUSTABLE FINISHED FLOOR CLEANOUT, DURA-COATED CAST IRON BODY WITH GAS AND WATERTIGHT ABS TAPERED THREADED PLUG, AND HEAVY DUTY CAST IRON TOP, VANDALPROOF SCREWS.
WCO-1	WALL CLEAN-OUT	SIZE/ SEE DWG.	-	-	-	-	ZURN Z1446	CAST IRON CLEAN-OUT TEE, DURA COATED BODY, GAS AND WATERTIGHT ABS TAPERED THREAD PLUG AND ROUND, SMOOTH STAINLESS STEEL WALL ACCESS COVER WITH SECURING SCREW.
FCO-1	FLOOR CLEAN-OUT	SIZE/ SEE DWG.	-	-	-	-	JOSAM 57000-31	PVC CLEAN-OUT WITH 2-WAY CLEAN-OUT TEE, COUNTER SUNK PLUG.
MV-1	MIXING VALVE	SIZE/ SEE DWG.	-	-	3/4"	3/4"	BRADLEY S59-4200T3	ASSE 1017 RATED, MIXING VALVE WITH INTEGRAL CHECKS.
MV-2	MIXING VALVE	SIZE/ SEE DWG.	-	-	3/4"	3/4"	BRADLEY S59-4000-A	ASSE 1070 RATED, MIXING VALVE WITH INTEGRAL CHECKS.
MV-3	MIXING VALVE	SIZE/ SEE DWG.	-	-	3/4"	3/4"	BRADLEY S59-9025	ASSE 1017 RATED, MIXING VALVE WITH INTEGRAL CHECKS.
INT-1	OILSAND INTERCEPTOR	3"	-	-	-	-	ZURN 1188-E-HD	100 GPM FLOW RATE, 110 GALLON CAPACITY, FABRICATED STEEL OIL INTERCEPTOR WITH INTEGRAL STORAGE TANK, ACID RESISTANT COATED INTERIOR AND EXTERIOR, FABRICATED STEEL EXTENSION AND HEAVY DUTY TRAFFIC RATED COVER. PROVIDE PLUG WRENCH.
RBPB-1	REDUCED PRESSURE BACKFLOW PREVENTER						WATTS NO. 9D, OR EQUAL	
1. FIXTURES FOR USE BY PEOPLE WITH DISABILITIES: A. INSTALL IN ACCORDANCE WITH A.D.A., STATE AND LOCAL REQUIREMENTS. B. THE FORCE REQUIRED TO ACTIVATE FLUSH VALVES SHALL BE 5 LBS MAXIMUM. C. FLUSH ACTIVATOR SHALL BE LOCATED ON WIDE SIDE OF THE STALL. D. THE FAUCET CONTROLS AND THE OPERATING MECHANISM (OPERABLE WITH ONE HAND) SHALL BE OF THE TYPE NOT REQUIRING AN OPERATING FORCE EXCEEDING 5 LBS, OR TIGHT GRASPING, PINCHING OR TWISTING OF THE WRIST.								

ELECTRIC WATER HEATER SCHEDULE										
UNIT #	TYPE	GALLONS	INPUT KW	EFF.	GPH REC. @ 70°F RISE	VOLT/PHASE CURRENT DRAW (PER PHASE)	WEIGHT (LBS.)	DIMENSIONS	MANUFACTURER	
									MANUFACTURER	MODEL #
EW1-1	ELECTRIC	40	4.5	95%	53	208V - 1Ø	473	48" H x 20"D	RHEEM	ELDS40-TB
EW1-2	ELECTRIC	40	4.5	95%	53	208V - 1Ø	473	48" H x 20"D	RHEEM	ELDS40-TB
EW1-3	ELECTRIC	40	4.5	95%	53	208V - 1Ø	473	48" H x 20"D	RHEEM	ELDS40-TB
NOTES: 1. PROVIDE WITH EXPANSION VALVE, T & P VALVE AND WATER HEATER DRAIN PAN. 2. COORDINATE WATER HEATER LOCATION AND PIPING WITH MECHANICAL AND ELECTRICAL PLANS.										

PUMP SCHEDULE														
UNIT #	DESCRIPTION	TYPE	GPM	FT HEAT	PUMP EFF. %	CONN. SIZE		MOTOR DATA				SELECTION BASED ON:		NOTES
						INLET	OUTLET	HP	RPM	VOLT	PH.	MANUFACTURER	MODEL	
HWCP-1	HOT WATER CIRCULATION PUMP	IN LINE PUMP	3	12	70	3/4"	3/4"	1/6	1750	120	1 PH	BELL & GOSSETT	SERIES 60	PROVIDE AQUASTAT AND TIME CLOCK.

ELECTRIC INSTANTANEOUS WATER HEATER SCHEDULE										
UNIT #	SERVING	TYPE	GALLONS	INPUT KW	RECOVERY (GPM)	VOLT/PHASE CURRENT DRAW (PER PHASE)	WEIGHT (LBS.)	DIMENSIONS	MANUFACTURER	
									MANUFACTURER	MODEL #
IWH-1	SINKS	ELECTRIC	INSTANTANEOUS	8.3	57 DEG RISE @ 1 GPM	208V - 1Ø	4.5	10"H x 5.5"W x 4"D	EEMAX	PA008208T
NOTES: 1. COORDINATE WATER HEATER SERVICES, PIPING AND LOCATION WITH MECHANICAL AND ELECTRICAL PLANS.										

PDI SIZING METHOD FOR GREASE TRAP	
EFFECTIVE CAPACITY OF GREASE INTERCEPTOR (GALLONS) 3 COMPARTMENT SINK @ 16"x20"x10" EA. x 2 = 6400	
CONTENTS IN GALLONS: CUBIC INCHES DIVIDED BY 231 = 27.7 GALLONS ACTUAL DRAINAGE LOAD 0.75 x 27.7 = 20.8 GALLONS	
CALCULATION FOR FLOW RATE FOR ONE MINUTE PERIOD: 14/1 = 14 GPM FLOW RATE	
FOR ONE MINUTE PERIOD 20 GPM REQUIRES ONE SCHIER GB-1 (20GPM/70LBS) GREASE TRAP (G1-1)	

PLUMBING FIXTURE SCHEDULE								
MARK	FIXTURE	WASTE	TRAP	VENT	COLD WATER	HOT WATER	MANUFACTURER /MODEL #	DESCRIPTION
WC-1	WATER CLOSET	3"	INTEG	2"	1/2"	-	KOHLER K-3998-0	TANK TYPE - RIM 14- ³ / ₄ " AFF. VITREOUS CHINA, 1.0 GPF, SIPHON JET, ELONGATED BOWL, FLOOR MOUNTED, CLOSED COUPLED COMBINATION; BOLT CAPS. ANGLE STOP SUPPLIES & ESCUTCHEONS. COORDINATE FINISH WITH ARCHITECT. SOLID PLASTIC, ELONGATED WHITE SEAT, KOHLER K-4636. FLUSH CONTROLS TO BE LOCATED ON THE OPEN SIDE OF THE WATER CLOSET.
WC-2	WATER CLOSET - ADA	3"	INTEG	2"	1/2"	-	KOHLER K-3493-0	TANK TYPE - RIM 17- ³ / ₄ " AFF. VITREOUS CHINA, 1.0 GPF, SIPHON JET, ELONGATED BOWL, FLOOR MOUNTED, CLOSED COUPLED COMBINATION; BOLT CAPS. ANGLE STOP SUPPLIES & ESCUTCHEONS. COORDINATE FINISH WITH ARCHITECT. SOLID PLASTIC, ELONGATED WHITE SEAT, KOHLER K-4636. FLUSH CONTROLS TO BE LOCATED ON THE OPEN SIDE OF THE WATER CLOSET.
WC-3	WATER CLOSET BREAKROOM	3"	INTEG	2"	1"	-	KOHLER K-98053-0 KOHLER K-76321	VITREOUS CHINA, 15- ³ / ₄ " MOUNTING HEIGHT INCLUDING SEAT, 1.28 GALLON, FLOOR MOUNTED, SIPHON JET, ELONGATED CLOSET BOWL WITH 1-1/2" TOP SPUD, 1.28 GALLON CHROME PLATED FLUSH VALVE(EXPOSED), 1-INCH I.P.S. SCREW DRIVER ANGLE STOP WITH PROTECTIVE CAP, ADJUSTABLE TAILPIECE, VACUUM BREAKER
WC-4	WATER CLOSET - ADA BREAKROOM	3"	INTEG	2"	1"	-	KOHLER K-96057-0 KOHLER K-76321	VITREOUS CHINA, 16- ³ / ₄ " MOUNTING HEIGHT INCLUDING SEAT, 1.28 GALLON, FLOOR MOUNTED, SIPHON JET, ELONGATED CLOSET BOWL WITH 1-1/2" TOP SPUD, 1.28 GALLON CHROME PLATED FLUSH VALVE(EXPOSED), 1-INCH I.P.S. SCREW DRIVER ANGLE STOP WITH PROTECTIVE CAP, ADJUSTABLE TAILPIECE, VACUUM BREAKER
L-1	LAVATORY	1-1/2"	1-1/4"	1-1/2"	1/2"	1/2"	KOHLER K-2882-0 BRADLEY S53-3700	18- ³ / ₄ " RECTANGULAR UNDERMOUNT BATHROOM SINK, VITREOUS CHINA, SINGLE HOLE PUNCH, WHITE, OVERFLOW DRAIN. COMPLETE WITH RAP AND TRIM RINGS.
L-2	LAVATORY - ADA	1-1/2"	1-1/4"	1-1/2"	1/2"	1/2"	DURAVIT 07054500002 BRADLEY S53-3700	BARRIER FREE - 17- ³ / ₄ " x 13- ³ / ₄ " WALL MOUNTED, VITREOUS CHINA SINK, BRASSCRAFT ¹ / ₄ " TURN ANGLE STOP SUPPLIES W/SUPPLY TUBES AND ESCUTCHEONS. PROVIDE CHAIR-CARRIER AND FLOOR DRAIN TRAP GUARDS.
L-3	LAVATORY DORIS	1-1/2"	1-1/4"	1-1/2"	1/2"	1/2"	KOHLER K-2983-0 BRADLEY S53-3700	15- ³ / ₄ " ROUND UNDERMOUNT BATHROOM SINK, VITREOUS CHINA, SINGLE HOLE PUNCH, WHITE, OVERFLOW DRAIN. COMPLETE WITH RAP AND TRIM RINGS.
S-1	SINGLE COMPARTMENT SINK	2"	2"	1-1/2"	1/2"	1/2"	AMERICAN STANDARD 18S96252211.075 7074100.002	25"x22" 18-GAUGE STAINLESS STEEL, TOP MOUNT SINK, SINGLE HOLE, SINGLE BOWL, SUPPLY WITH MOUNTING CLIPS AND COLONY PRO SINGLE-HANDLE PULL-OUT SPRAY KITCHEN FAUCET.
SH-1	SHOWER	2"	2"	1-1/2"	1/2"	1/2"	STERLING OC-SS-39 CLEVELAND FAUCET 46302CGR	39-3/8" x 39-3/8" VIKRELL SHOWER BASE, TEXTURED FLOOR, INTEGRATED TILING FLANGE, CENTER DRAIN, PRESSURE BALANCE SHOWER, METAL LEVER HANDLE, 1.75 GPM SINGLE FUNCTION SHOWER HEAD. PROVIDE WITH KOHLER RITE-TEMP/KP8304-KS.
SH-2	SHOWER	2"	2"	1-1/2"	1/2"	1/2"	- CLEVELAND FAUCET 46302CGR	60" x 36" VIKRELL SHOWER BASE, TEXTURED FLOOR, INTEGRATED TILING FLANGE, CENTER DRAIN, PRESSURE BALANCE SHOWER, METAL LEVER HANDLE, 1.75 GPM SINGLE FUNCTION SHOWER HEAD. PROVIDE WITH KOHLER RITE-TEMP/KP8304-KS.
SH-3	SHOWER	2"	2"	1-1/2"	1/2"	1/2"	- CLEVELAND FAUCET 46302CGR	60" x 60" VIKRELL SHOWER BASE, TEXTURED FLOOR, INTEGRATED TILING FLANGE, CENTER DRAIN, PRESSURE BALANCE SHOWER, METAL LEVER HANDLE, 1.75 GPM SINGLE FUNCTION SHOWER HEAD. PROVIDE WITH KOHLER RITE-TEMP/KP8304-KS.
SH-4	SHOWER DORIS	2"	2"	1-1/2"	1/2"	1/2"	- CLEVELAND FAUCET 46302CGR	62" x 36" VIKRELL SHOWER BASE, TEXTURED FLOOR, INTEGRATED TILING FLANGE, CENTER DRAIN, PRESSURE BALANCE SHOWER, METAL LEVER HANDLE, 1.75 GPM SINGLE FUNCTION SHOWER HEAD. PROVIDE WITH KOHLER RITE-TEMP/KP8304-KS.
UR-1	URINAL	2"	INTEG	2"	3/4"	-	AMERICAN STANDARD 6561017.020 6063101.002	LIP +17" VITREOUS CHINA, WHITE, WALL HUNG SIPHON JET FLUSH URINAL COMPLETE WITH 3/4" TOP SPUD AND WALL HANGERS. PROVIDE AMERICAN STANDARD SELECTRONIC TOUCHLESS FLUSH VALVE, DC POWER FOR ALL URINALS.
UR-2	URINAL - ADA	2"	INTEG	2"	3/4"	-	AMERICAN STANDARD 6561017.020 6063101.002	LIP +17" VITREOUS CHINA, WHITE, WALL HUNG SIPHON JET FLUSH URINAL COMPLETE WITH 3/4" TOP SPUD AND WALL HANGERS. PROVIDE AMERICAN STANDARD SELECTRONIC TOUCHLESS FLUSH VALVE, DC POWER FOR ALL URINALS.
2CS	2 COMPARTMENT SINK	SIZE/ SEE DWG.	1-1/2"	1-1/2"	3/4"	3/4"	BK RESOURCES BK3-2-1620-10-18TS KROWN 14-810L	TWO 16"x20"x10" COMPARTMENT SINK STAINLESS STEEL LEG 18" DRAINBOARD LAR, 10" SWING SPOUT FAUCET SPLASH MOUNT 8" CENTER LOW LEAD
IMB-1	ICE MAKER BOX	-	-	-	1/2"	-	OATEY 38491	BULK MOLDED COMPOUND, FIRE-RATED BOX W/ DIMENSION OF 8.63" HIGH x 8.13" WIDE, ¹ / ₄ " TURN BRASS BALL VALVE WITH WATER HAMMER ARRESTOR.
WB-1	WASHER BOX	3"	2"	1-1/2"	3/4"	3/4"	OATEY 36247 FLUMBCRAFT 7639500T	VALVE 36" AFF. HIGH IMPACT PLASTIC BOX W/ DIMENSION OF 7" HIGH x 9.89" WIDE. TWO ¹ / ₄ " TURN ANGLE VALVES WITH WATER HAMMER ARRESTORS, ³ / ₄ " DIA. SUPPLY CONNECTION. NYLON LINT TRAP FOR WASHING MACHINE DRAIN SYSTEM.
HB-1	HOSE BIBB	-	-	-	3/4"	-	WOODFORD B24	SANITARY, AUTO DRAINING, WITH VACUUM BREAKER, BACKFLOW PROTECTED. SEE PLANS FOR WALL THICKNESS AND MOUNTING HEIGHT.
FD-1	FLOOR DRAIN	SIZE/ SEE DWG.	-	-	-	-	ZURN ZN415S	DURA-COATED CAST IRON BODY WITH BOTTOM OUTLET, COMBINATION INVERTIBLE MEMBRANE CLAMP AND ADJUSTABLE COLLAR WITH SEEPAGE SLOTS AND SQUARE TYPE 'B' POLISHED NICKEL BRONZE STRAINER.
FD-2	FLOOR DRAIN	SIZE/ SEE DWG.	-	-	-	-	ZURN ZN415SH	DURA-COATED CAST IRON BODY WITH BOTTOM OUTLET, COMBINATION INVERTIBLE MEMBRANE CLAMP AND ADJUSTABLE COLLAR WITH SEEPAGE SLOTS AND SQUARE TYPE 'SH' POLISHED NICKEL BRONZE, SQUARE HINGED, LIGHT DUTY STRAINER.
FS-1	FLOOR SINK	SIZE/ SEE DWG.	-	-	-	-	ZURN Z1900	DURA-COATED CAST IRON 12"x12"x6" BODY WITH BOTTOM OUTLET, COMBINATION INVERTIBLE MEMBRANE CLAMP AND ADJUSTABLE COLLAR WITH SEEPAGE SLOTS AND SQUARE TYPE 'B' POLISHED NICKEL BRONZE HALF GRATE. PROVIDE 1/2" COLD WATER TRAP PRIMER CONNECTION.
FS-2	FLOOR SINK	SIZE/ SEE DWG.	-	-	-	-	ZURN Z1901	DURA-COATED CAST IRON 12"x12"x8" BODY WITH BOTTOM OUTLET, COMBINATION INVERTIBLE MEMBRANE CLAMP AND ADJUSTABLE COLLAR WITH SEEPAGE SLOTS AND SQUARE TYPE 'E' POLISHED NICKEL BRONZE HALF GRATE. PROVIDE 1/2" COLD WATER TRAP PRIMER CONNECTION.
EW-1	EYE WASH STATION	SIZE/ SEE DWG.	-	-	3/4"	-	BRADLEY S19-212	PEDESTAL MOUNT EYE/FACE WASH UNIT WITH PLASTIC BOWL.
EW-1	ELECTRIC WATER COOLER HILOW W/ BOTTLE FILLER	2"	1-1/2"	1-1/2"	1/2"	-	ELKAY LZ35TL8WSLK	LOWER BUBBLER 32- ³ / ₄ " AFF, UPPER 38- ³ / ₄ " AFF. BOTTLE FILLING STATION WITH ELECTRONIC BOTTLE FILLER SENSOR WITH ELECTRONIC FRONT AND SIDE BUBBLER PUSHBAR ACTIVATION, WALL MOUNTED CAPACITY TO DELIVER 8 GPH OF 50°F WATER WITH INLET TEMP. OF 80°F AND ROOM TEMP. OF 90°F, STAINLESS STEEL BASIN & PEWTER VINYL W/ 1/5 HP., 120V/1Ø.
1. FIXTURES FOR USE BY PEOPLE WITH DISABILITIES: A. INSTALL IN ACCORDANCE WITH A.D.A., STATE AND LOCAL REQUIREMENTS. B. THE FORCE REQUIRED TO ACTIVATE FLUSH VALVES SHALL BE 5 LBS MAXIMUM. C. FLUSH ACTIVATOR SHALL BE LOCATED ON WIDE SIDE OF THE STALL. D. THE FAUCET CONTROLS AND THE OPERATING MECHANISM (OPERABLE WITH ONE HAND) SHALL BE OF THE TYPE NOT REQUIRING AN OPERATING FORCE EXCEEDING 5 LBS, OR TIGHT GRASPING, PINCHING OR TWISTING OF THE WRIST.								

OLD MEMORIAL		
13600 National Golf Dr Tampa, FL 33626		
no.	description	date
	PERMIT SET	04.24.26
1	PERMIT COMMENTS	06.19.26